


PLOTTED DATE: 9/19/2011 1:33:52 PM
 SAVED DATE: 9/19/2011 2:38:34 PM
 C:\NET\145120-3000-C-B000W\KAC

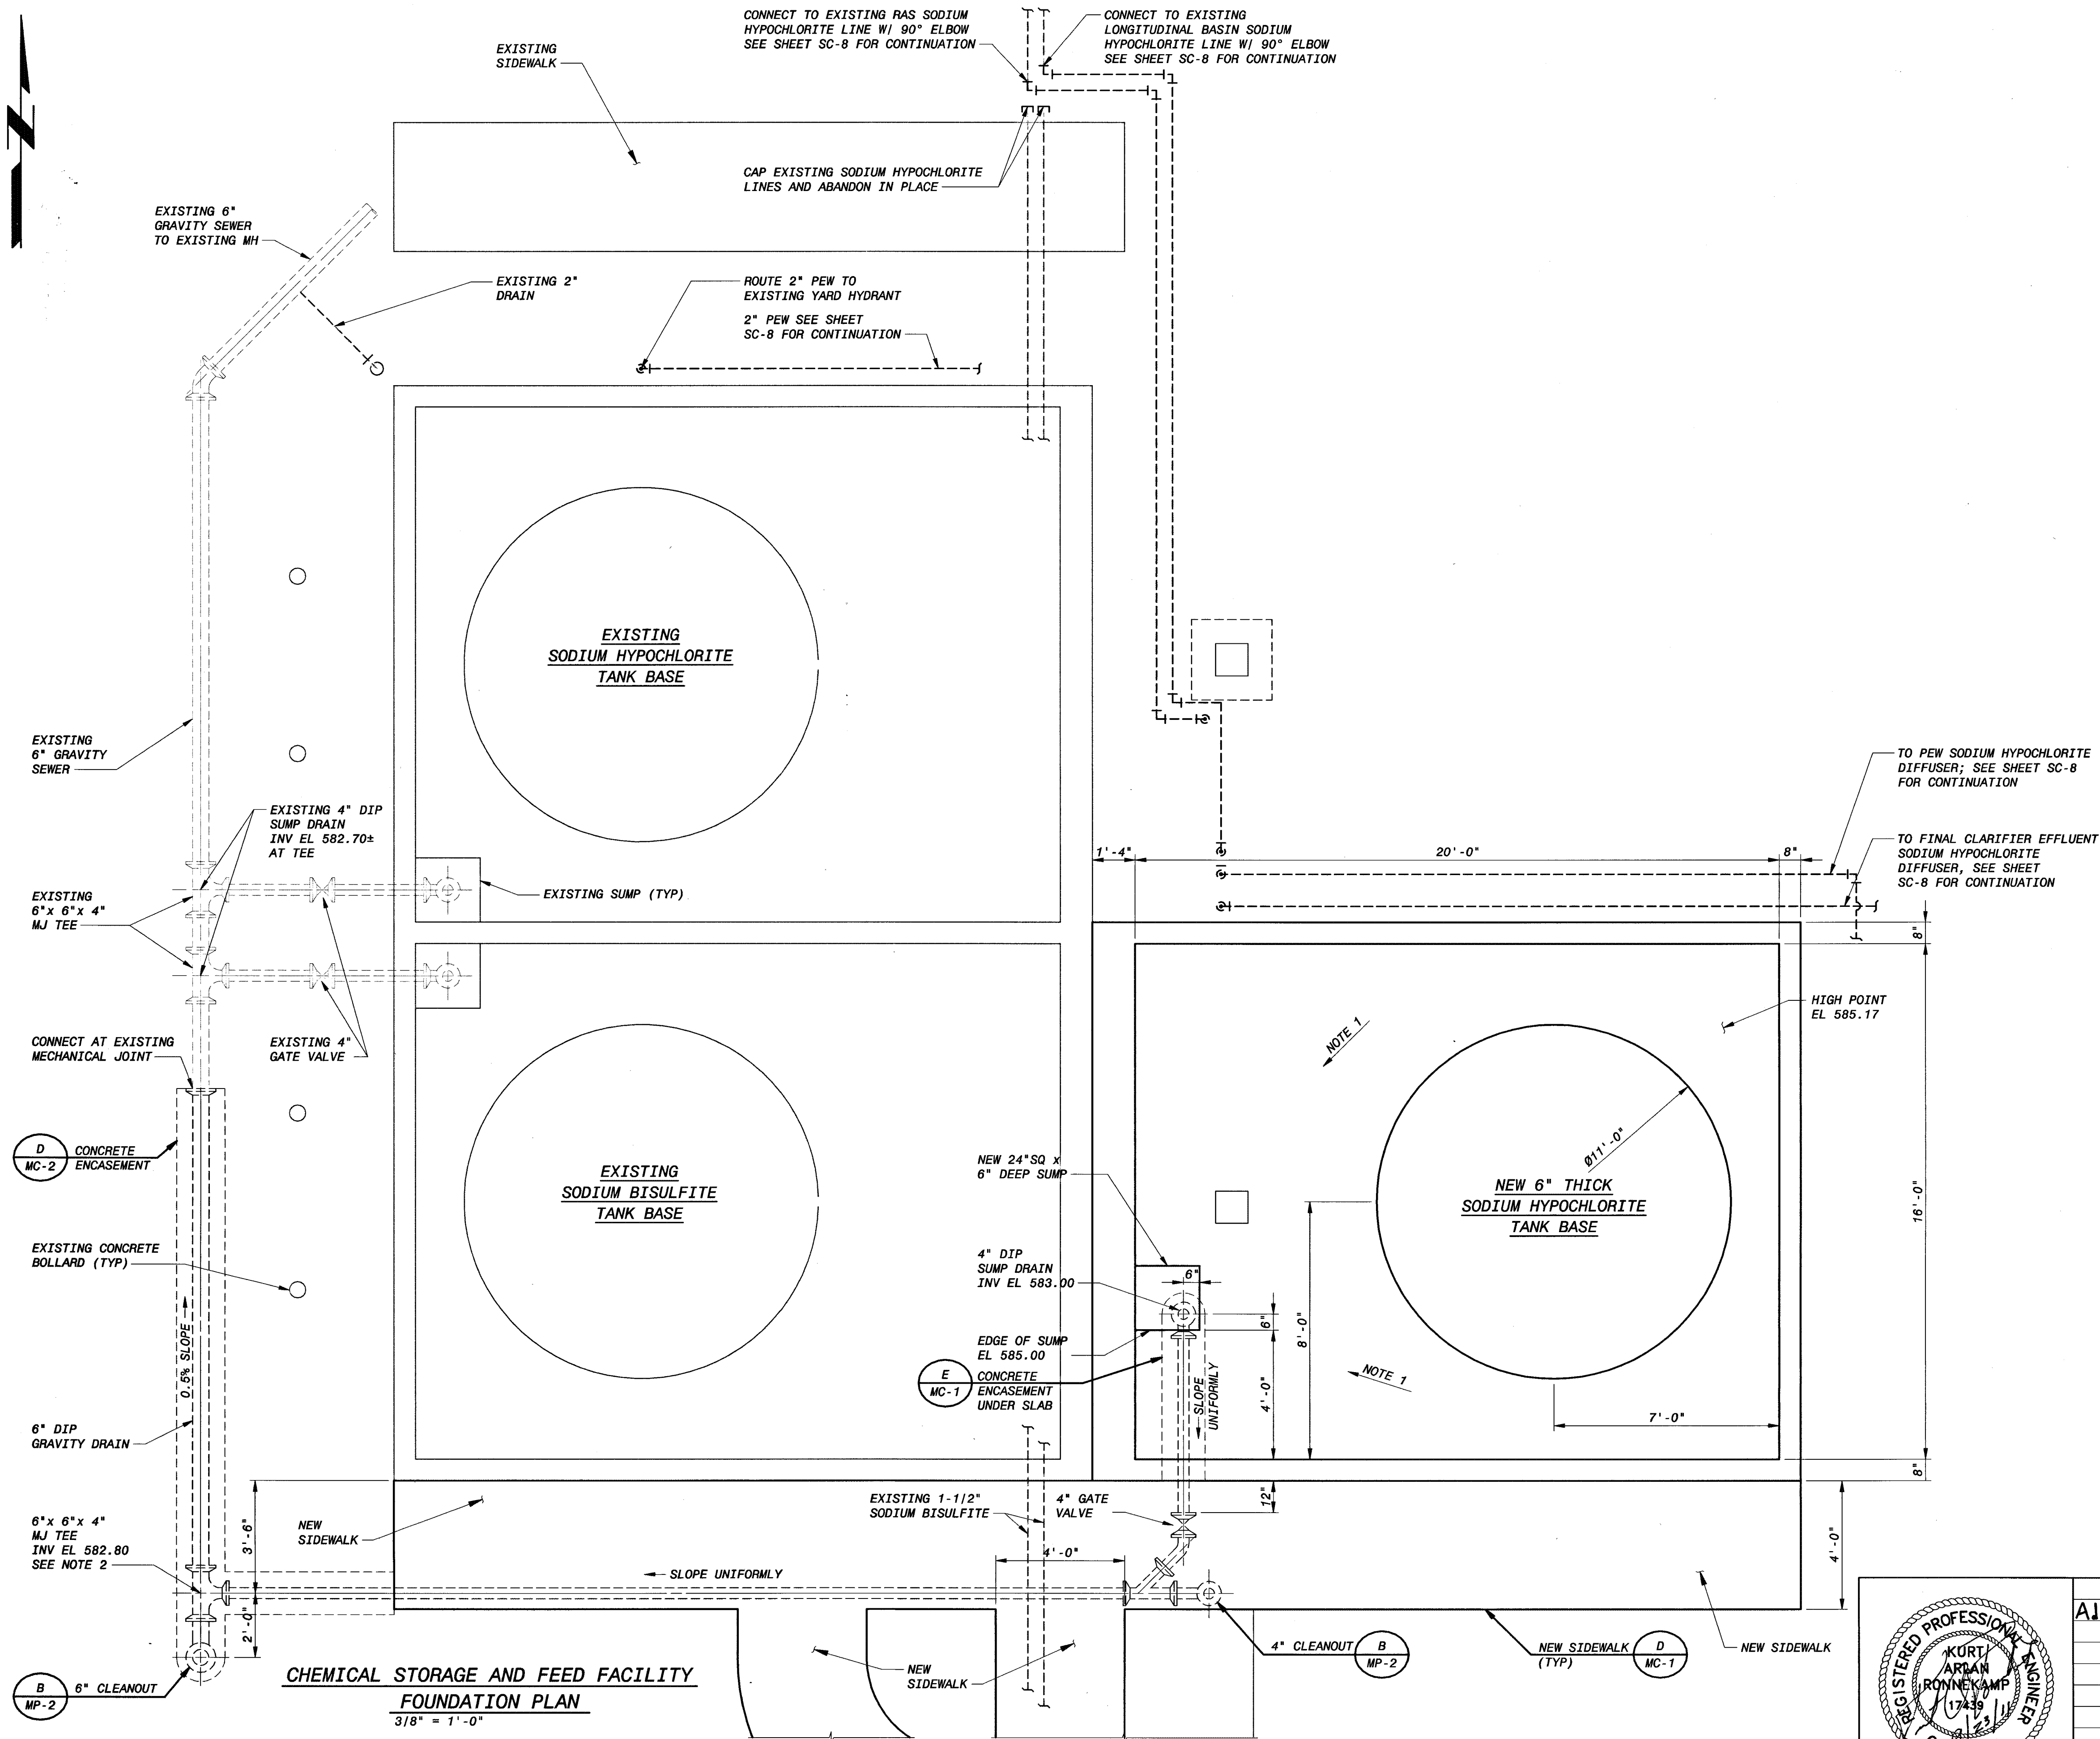

NOTES:

1. SLOPE FLOOR 1/8" PER FOOT TOWARDS NEW SUMP.
2. TEE SHALL BE ROTATED AS NECESSARY TO MATCH CONNECTING ELEVATIONS FROM DRAIN TO SEWER.

3. AT LOCATIONS WHERE TWO SODIUM HYPOCHLORITE LINES ARE ADJACENT TO EACH OTHER, LINES SHALL BE ENCASED USING DETAIL A ON SHEET SC-25. AT LOCATIONS WITH SINGLE SODIUM HYPOCHLORITE LINE, DETAIL B ON SHEET SC-25 SHALL BE USED.

LOWER BIRD CREEK WWTP EXPANSION
 TMUA PROJECT NO. ES 2006-01
 CONTRACT 1B

CHEMICAL STORAGE AND FEED FACILITY
 CIVIL / STRUCTURAL
 FOUNDATION PLAN

CITY OF TULSA, OKLAHOMA
 TULSA METROPOLITAN UTILITY AUTHORITY
 ENGINEERING SERVICES DEPARTMENT

PLANS AND ESTIMATES PREPARED BY:

BLACK & VEATCH
 Building a world of difference
 Black & Veatch Corporation
 Kansas City, Missouri

Holloway, Updike and Bolton
 Consulting Engineers
 Muskogee - Broken Arrow
 OKLAHOMA

APPROVED:
 DATE 10/28/2011



FILE: DRAWING: CC-2
 ATLAS PAGE NO:

SHEET 152 OF 261 SHEETS


B&V PROJECT NO. 145120

9-25-11

PLOTTED DATE: 9/19/2011 2:05:06 PM
SAVED DATE: 9/22/2011 2:46:01 PM
C:\NET ID: 145120-3000-C-60000483

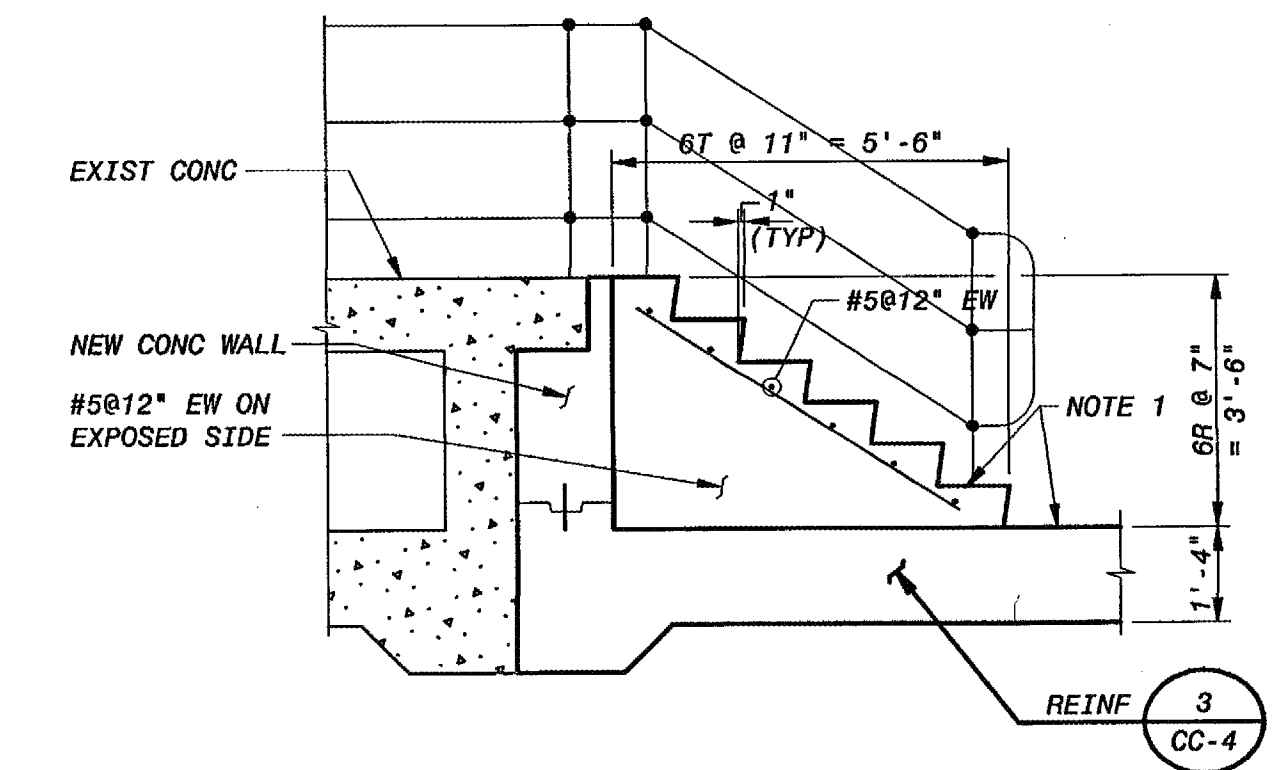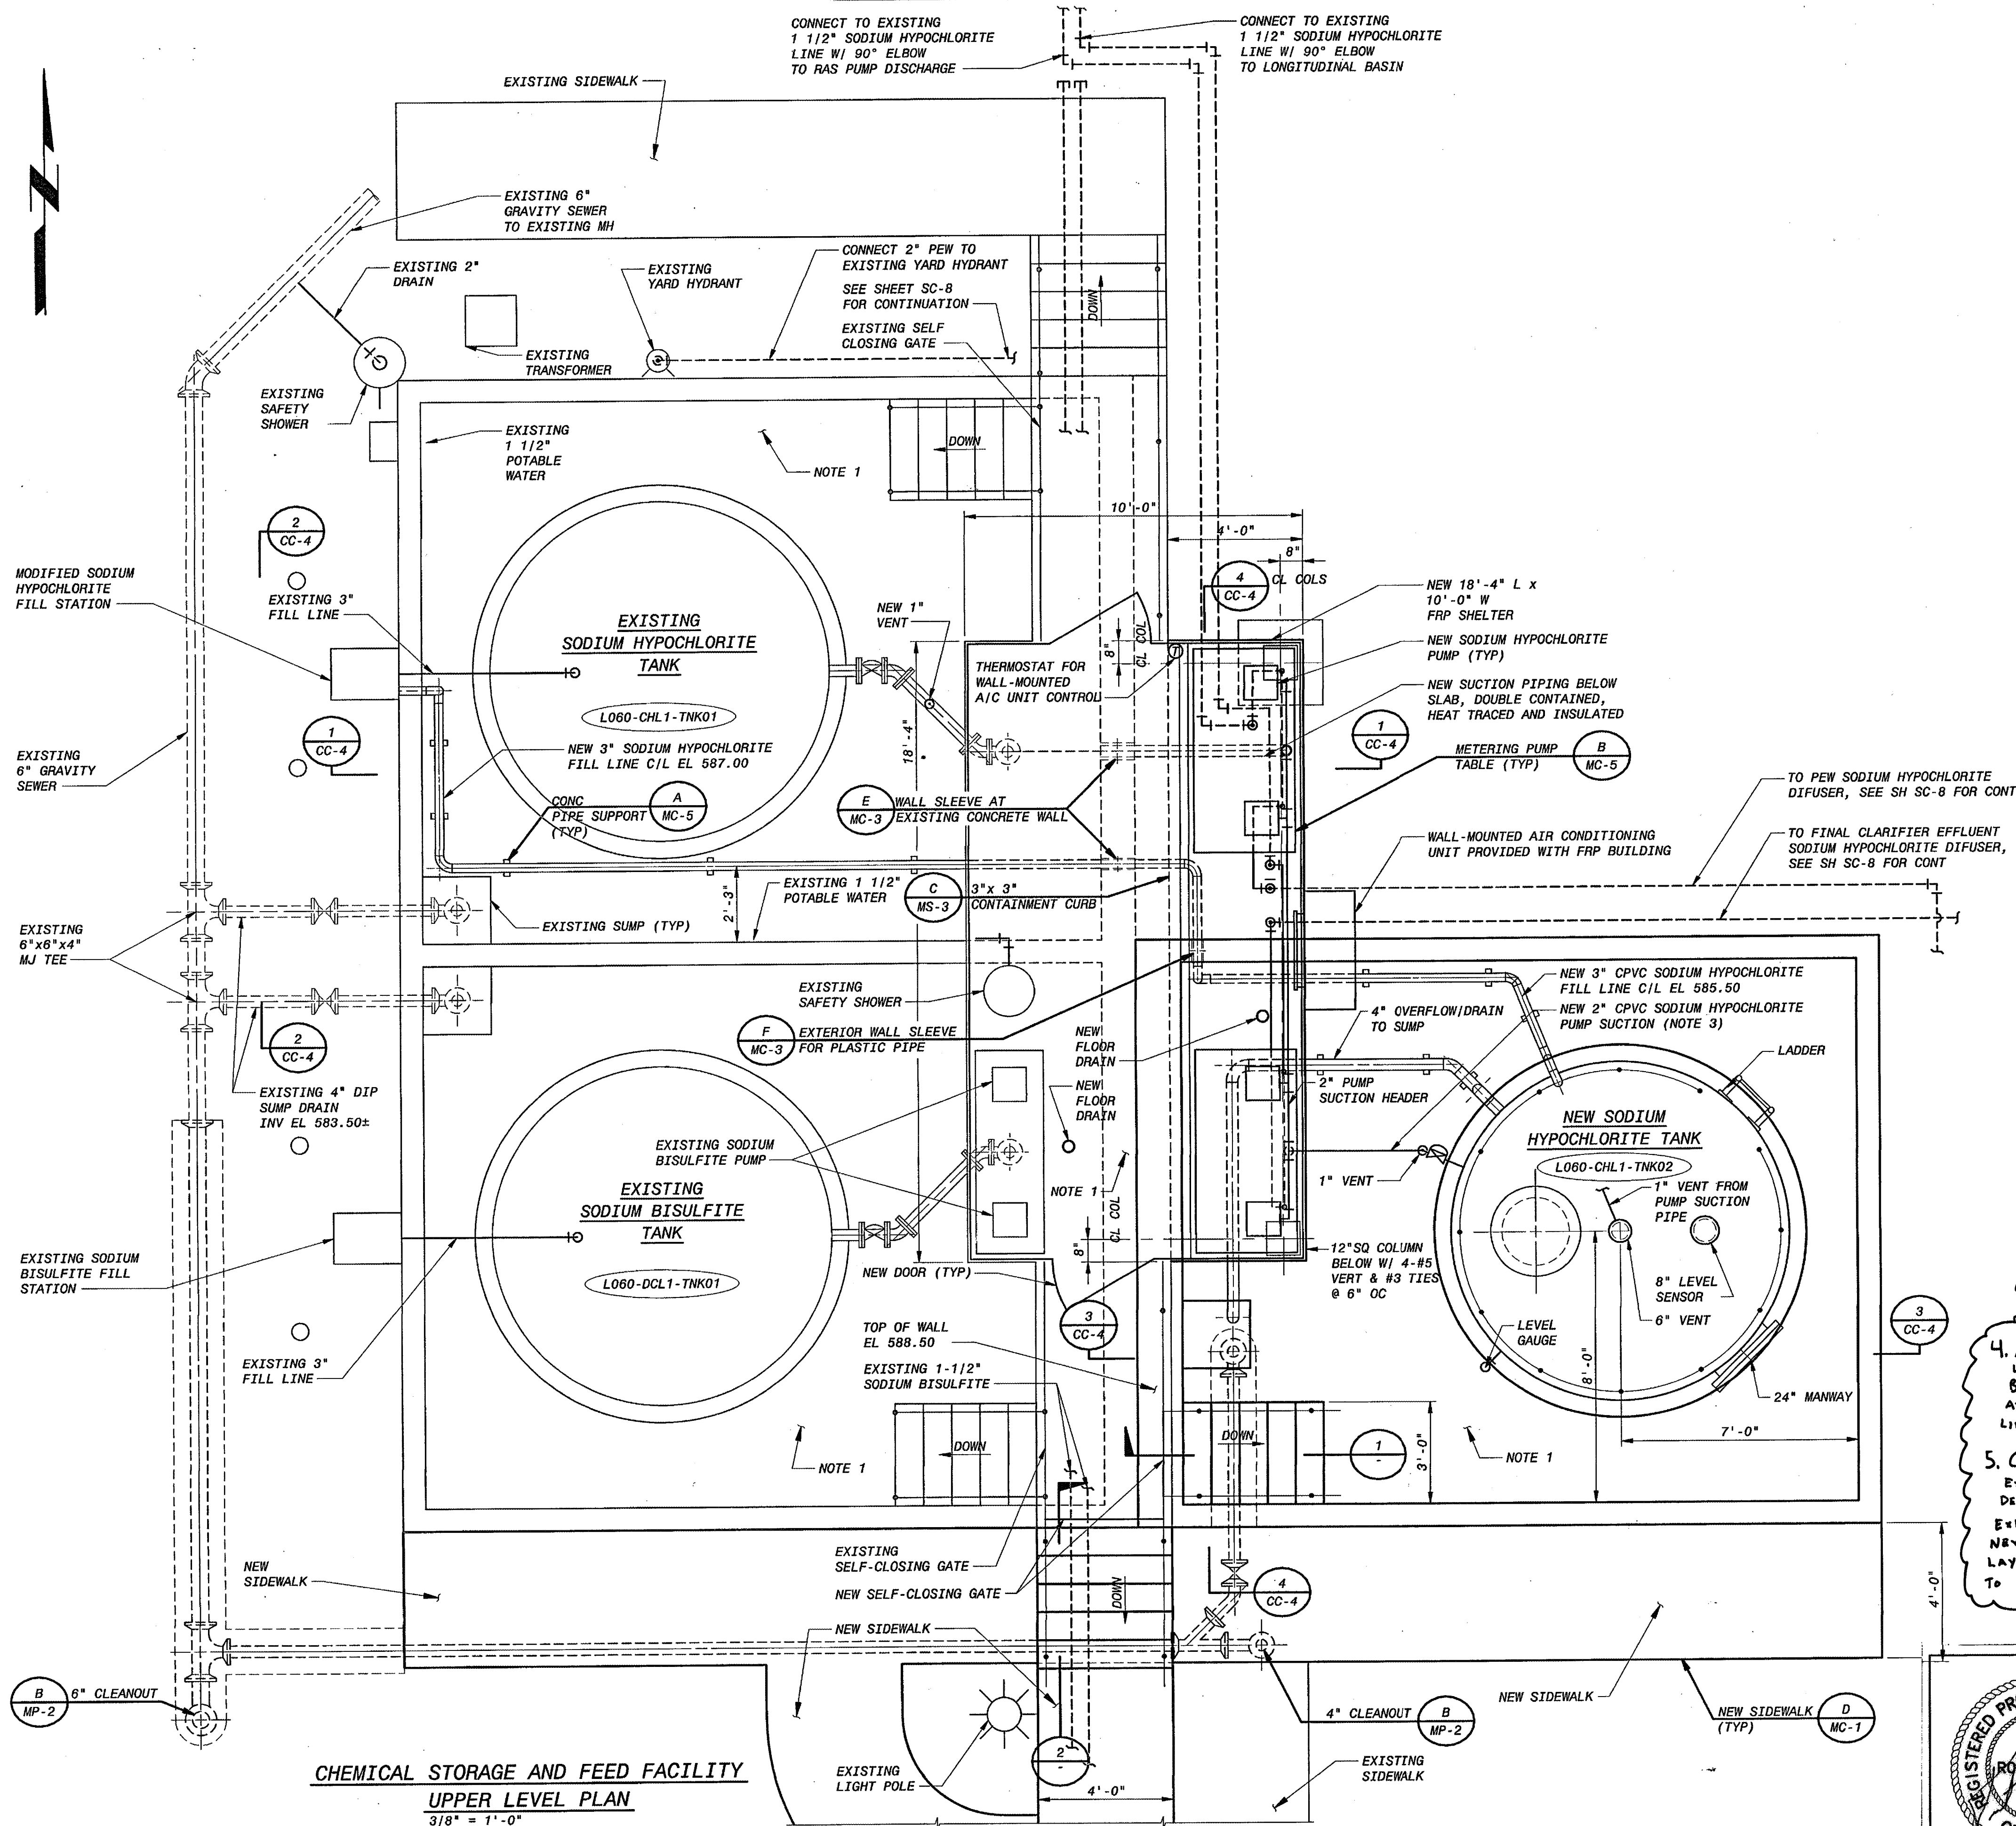

SECTION 1
3/8\"/>

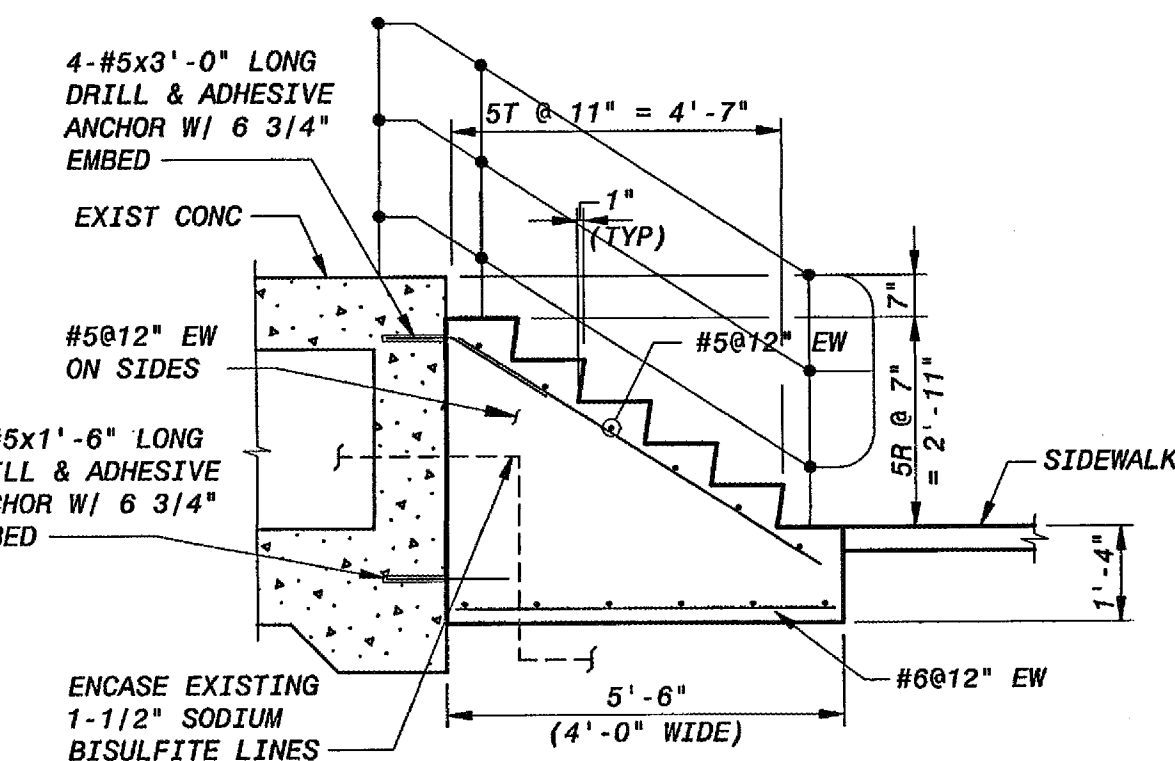

SECTION 2
3/8\"/>

NOTES:

1. VINYL ESTER WITH GRAPHITE FILLER PROTECTION SYSTEM TO COAT CONCRETE SURFACES OF CONTAINMENT AREA AND SLAB INSIDE FRP BUILDING INCLUDING CONCRETE CURBS, NEW AND EXISTING FLOORS, SUMPS, PIPE SUPPORTS, EQUIPMENT BASES, AND STAIRS (ALL EXPOSED CONCRETE) PER SPECIFICATION 09880. COATING SHALL EXTEND TO TOP OF CONTAINMENT WALL.
2. SEE P&ID'S FOR CHEMICAL PIPING VALVES AND PIPING DEVICES.
3. HEAT TRACE AND INSULATE.

4. AT LOCATIONS WHERE TWO SODIUM HYPOCHLORITE LINES ARE ADJACENT TO EACH OTHER, LINES SHALL BE ENCASED USING DETAIL A ON SHEET SC-25. AT LOCATIONS WITH SINGLE SODIUM HYPOCHLORITE LINE, DETAIL B ON SHEET SC-25 SHALL BE USED.

5. CONTRACTOR SHALL PROVIDE A TABLE FOR THE EXISTING BISULFITE PUMPS IN ACCORDANCE WITH DETAIL B ON SHEET MC-5. CONTRACTOR SHALL MODIFY EXISTING PIPING AS NECESSARY TO ACCOMMODATE NEW SODIUM BISULFITE PANELS AND TABLES. PIPING LAYOUTS AND CONFIGURATION SHALL BE SIMILAR TO SODIUM HYPOCHLORITE SYSTEM.

CHEMICAL STORAGE AND FEED FACILITY
UPPER LEVEL PLAN
3/8\"/>




REVISION			BY	DATE
Addendum No. 2			PSB	1-13-12


PLAN SCALE:		DRAWN	JKS	APPROVED:
DESIGNED		JMS		
SURVEY				
PROFILE SCALE:		FIELD MGR.	JOS 10/11	
HORIZONTAL:		SECT. MGR.		
1\"/>		PROJ. MGR.	PSB 10/31/11	
VERTICAL		RECOMMENDED:		
1\"/>				
FILE:		DRAWING: CC-3		DATE 10/28/2011
ATLAS PAGE NO:				SHEET 153 OF 261 SHEETS

LOWER BIRD CREEK WWTP EXPANSION
TMUA PROJECT NO. ES 2006-01
CONTRACT 1B
CHEMICAL STORAGE AND FEED FACILITY
CIVIL / STRUCTURAL
UPPER LEVEL PLAN
CITY OF TULSA, OKLAHOMA
TULSA METROPOLITAN UTILITY AUTHORITY
ENGINEERING SERVICES DEPARTMENT

PLANS AND ESTIMATES PREPARED BY:
BLACK & VEATCH
Building a world of difference
Holloway, Updell and Gellum
Consulting Engineers
Mankins - Broken Arrow
Black & Veatch Corporation
Kansas City, Missouri

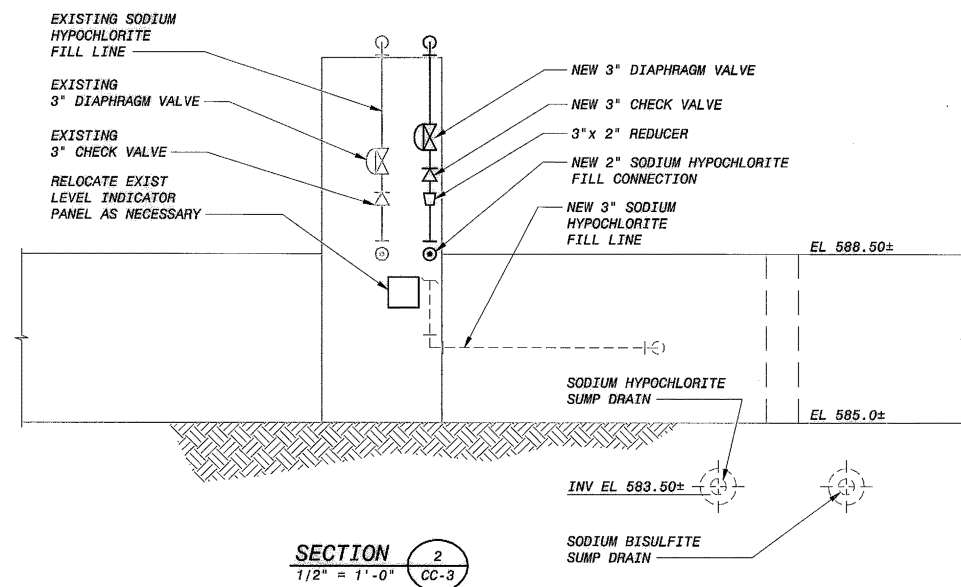

SECTION 1
3/8" = 1' - 0"

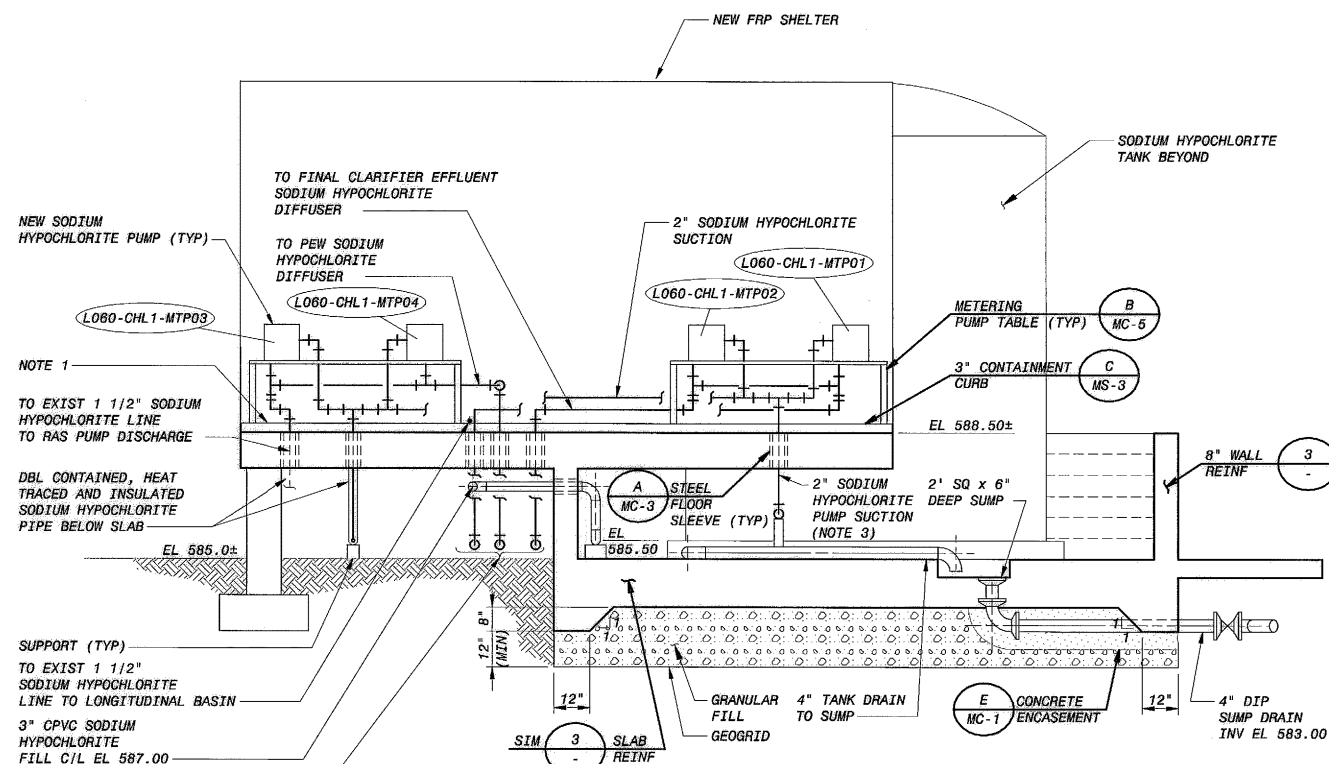

SECTION 3
3/8" = 1' - 0" CC-3

SECTION 4
3/8" = 1'-0" CC-3

- | |
|---|
| <p>LOWER BIRD CREEK WWTP EXPANSION
 TMUA PROJECT NO. ES 2006-01
 CONTRACT 1B</p> |
| <p>CHEMICAL STORAGE AND FEED FACILITY
 CIVIL / STRUCTURAL
 SECTIONS</p> |
| <p>CITY OF TULSA, OKLAHOMA
 TULSA METROPOLITAN UTILITY AUTHORITY
 ENGINEERING SERVICES DEPARTMENT</p> |


PLANS AND ESTIMATES PREPARED BY:



Black & Veatch Corporation
Kansas City, Missouri

PLAN SCALE:	DRAWN	JKS	APPROVED:
	DESIGNED	JMS	
	SURVEY		
PROFILE SCALE:	FIELD MGR.	705 10/11	 DIRECTOR
HORIZONTAL: 1" =	SECT. MGR.		
	PROJ. MGR.	10/13/11	
VERTICAL: 1" =	RECOMMENDED:	HAS 10/13/11	
FILE:	DRAWING: CC-4	DATE 10/28/2011	
ATLAS PAGE NO:		SHEET 154 OF 261 SHEETS	

B&V PROJECT NO. 145120

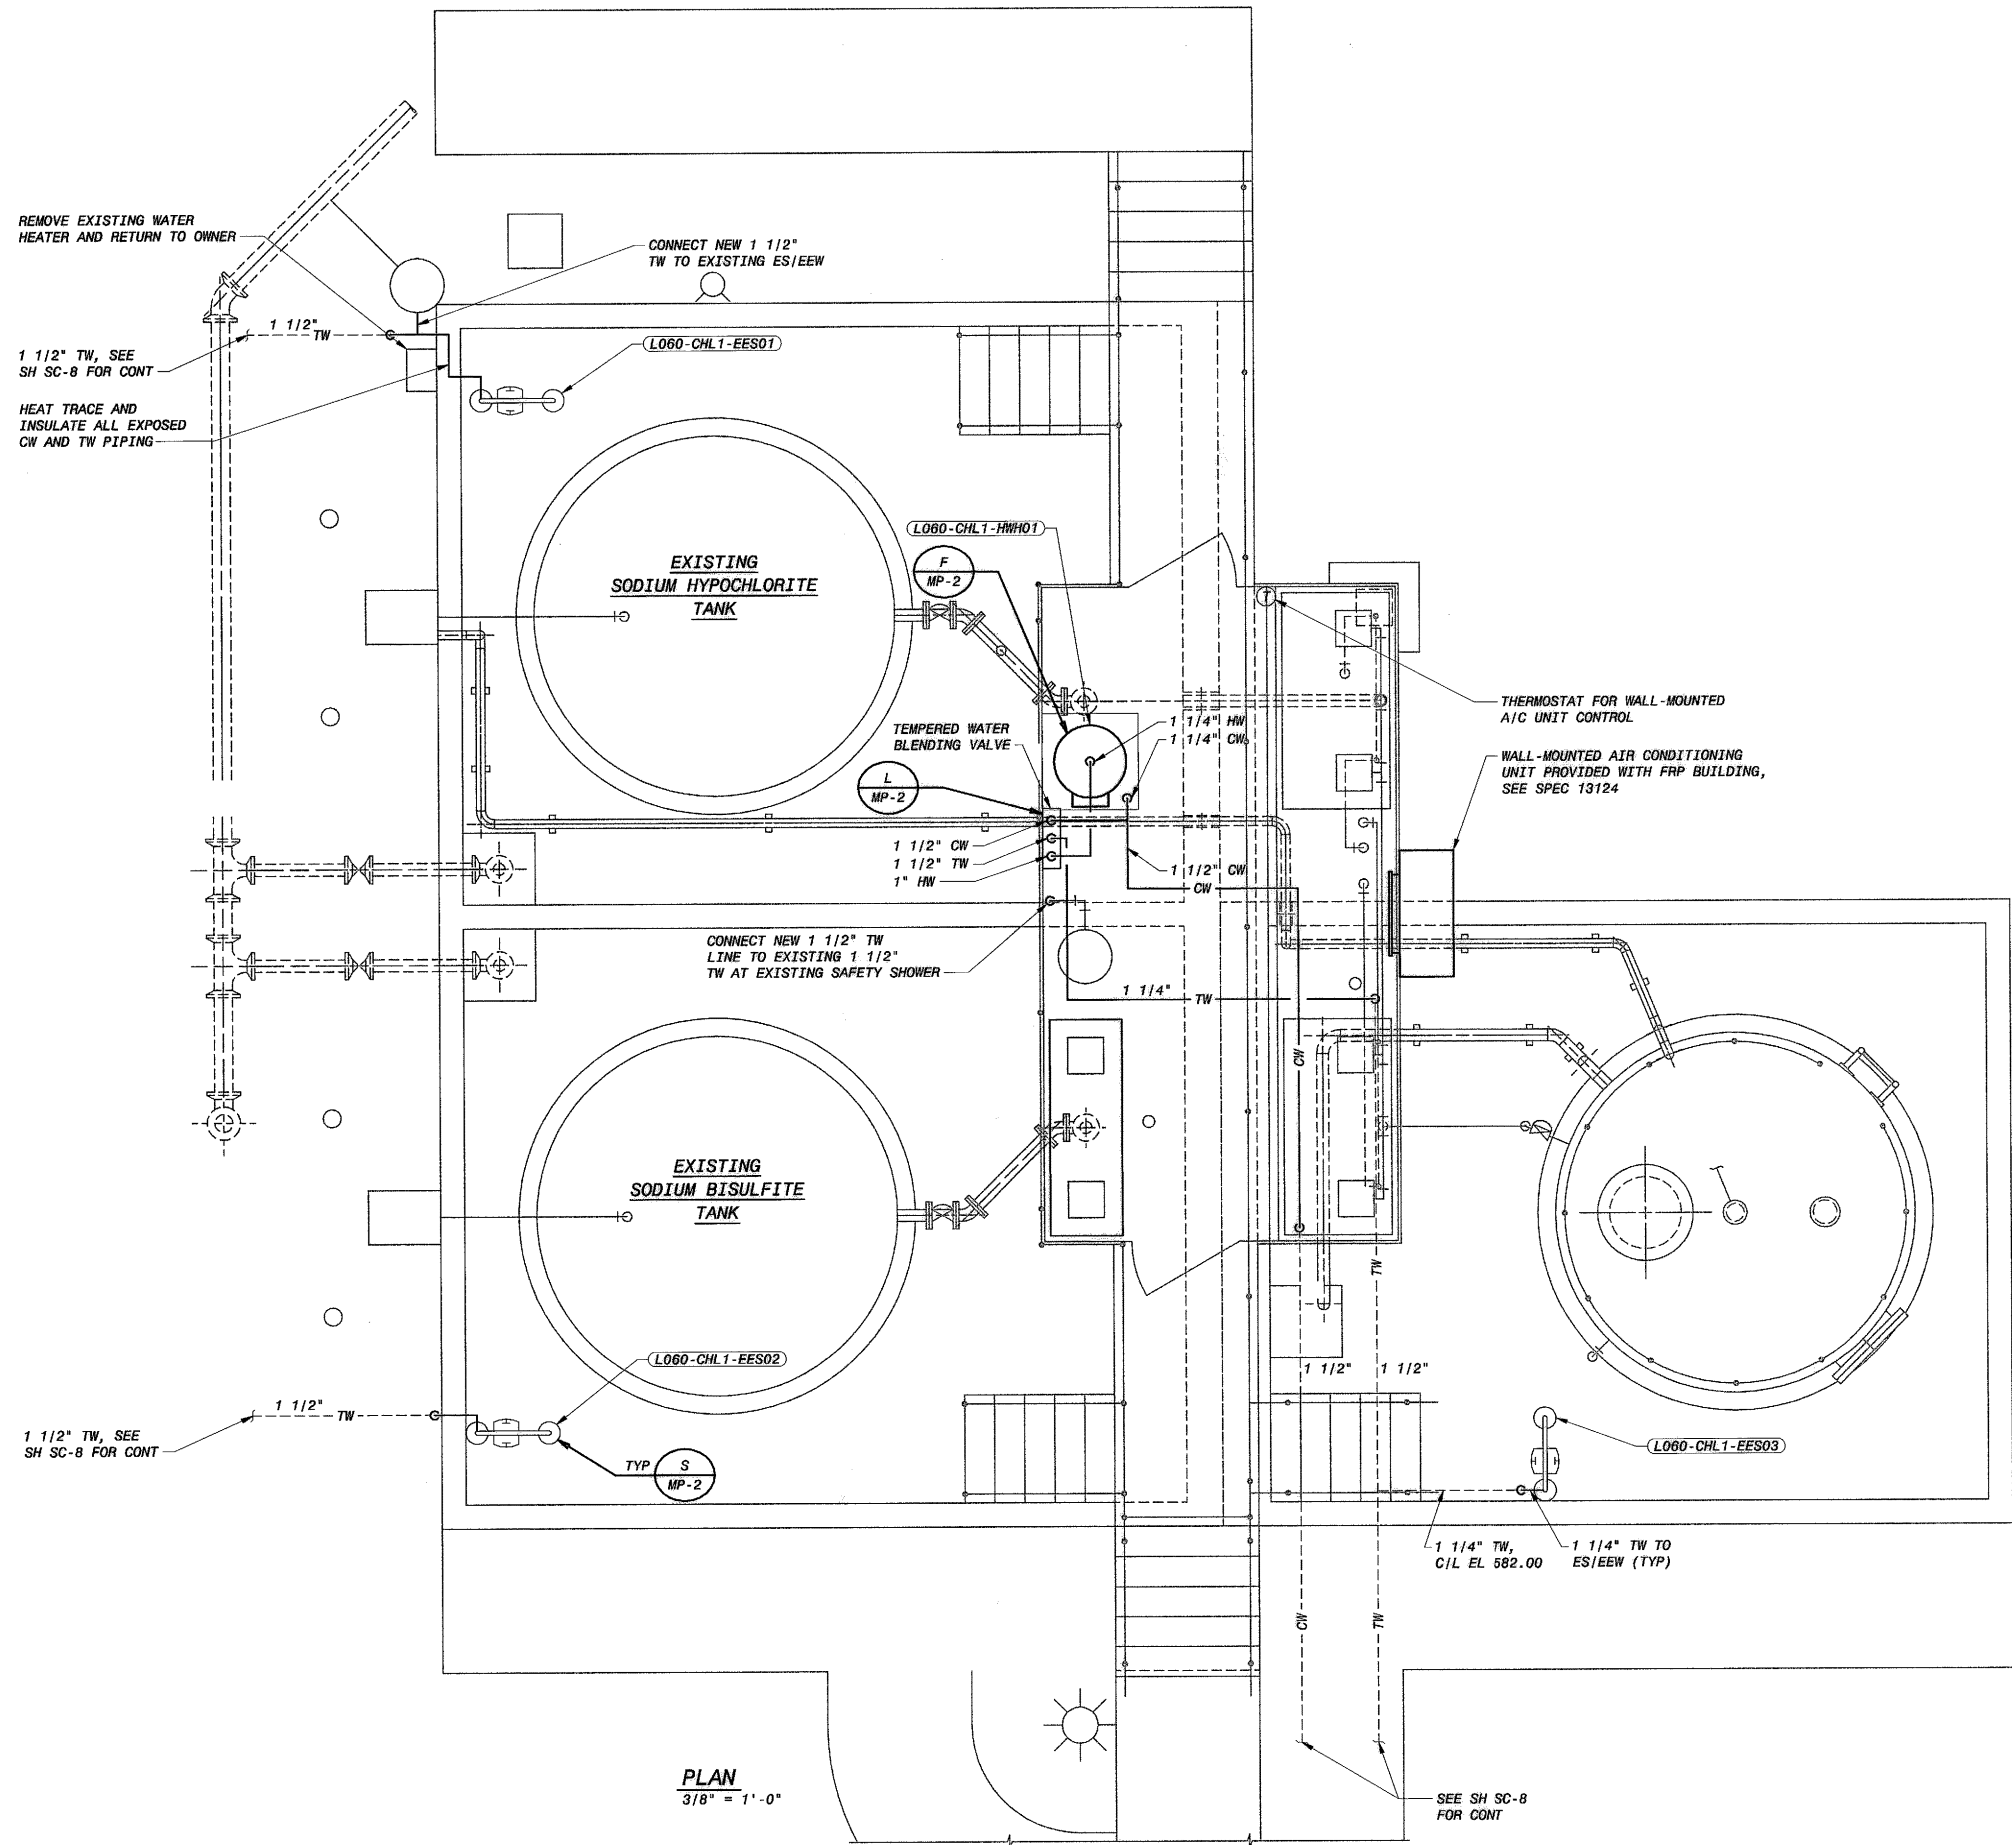

LOWER BIRD CREEK WWTP EXPANSION
TMUA PROJECT NO. ES 2006-01
CONTRACT 1B

CHEMICAL STORAGE AND FEED FACILITY
PLUMBING/HVAC
PLAN

CITY OF TULSA, OKLAHOMA
TULSA METROPOLITAN UTILITY AUTHORITY
ENGINEERING SERVICES DEPARTMENT

PLANS AND ESTIMATES PREPARED BY:
 BLACK & VEATCH
Building a world of difference
Serving City, Municipal

DAVID WILLIAM NELSON
REGISTERED PROFESSIONAL ENGINEER
OKLAHOMA


REVISION	BY	DATE

PLAN SCALE: DRAWN BDL
3/8" = 1'-0" DESIGNED TRD
PROFILE SCALE: FIELD MGR. **708** 10/11
HORIZONTAL: SECT. MGR.
1" = PROJ. MGR. **BW** 10/11
VERTICAL: RECOMMENDED: **HAS** 10/11
1" =
FILE: CP-01.DWG DRAWING: CP-1
ATLAS PAGE NO: 9-28-11

APPROVED:

DIRECTOR
DATE 10/28/2011
SHEET 155 OF 261 SHEETS

FD 145120
D:\145120\B
PLOTTED DATE: 9/22/2011 5:41:35 AM, Batch Plot
SHEET 155 OF 261 SHEETS
C:\145120\145120-3000-PS0000WSEF

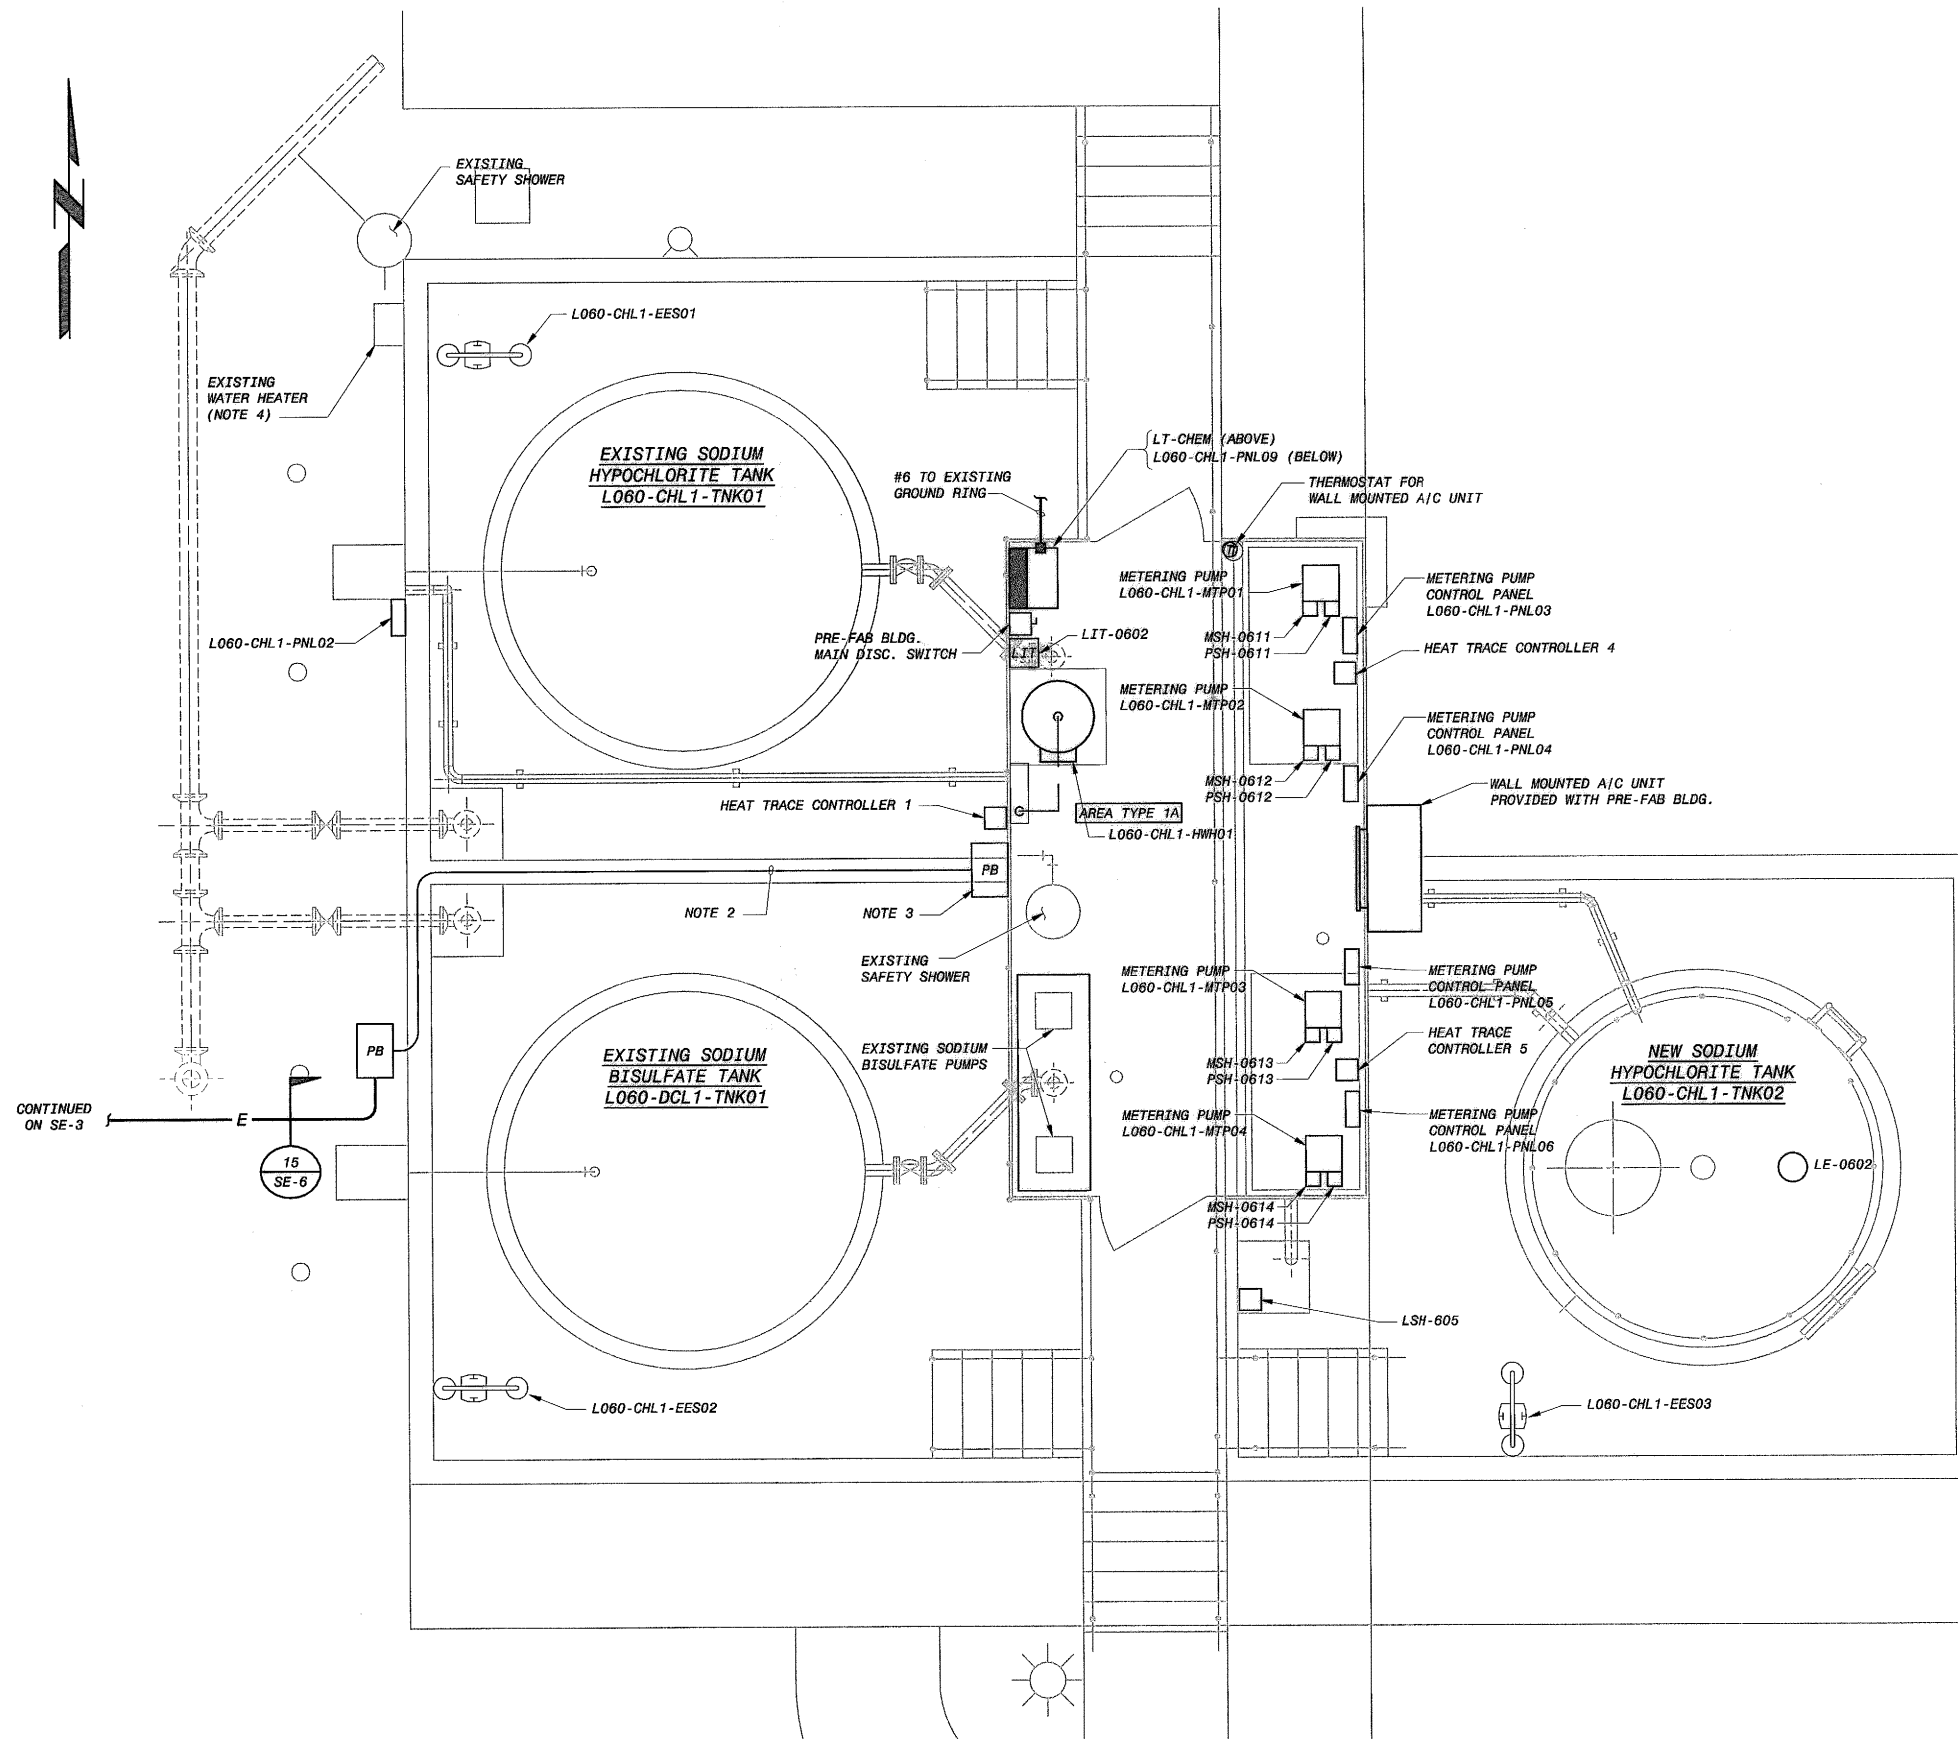


- NOTES:**
1. SEE DRAWING GE-1 FOR ELECTRICAL LEGEND & ABBREVIATIONS AND GENERAL REQUIREMENTS.
 2. CONTRACTOR SHALL ROUTE CIRCUITS TO PULL BOX AT PRE-FAB BUILDING CONSOLIDATING SIMILAR CIRCUITS TO REDUCE THE QUANTITY OF RACEWAYS ROUTED ON THE CONCRETE SLAB.
 3. CONTRACTOR SHALL PROVIDE SEPARATE PULL BOXES FOR CONTROL AND INSTRUMENT CIRCUITS. THE MAIN 480VAC CIRCUIT CAN BE ROUTED DIRECTLY TO THE PRE-FAB BUILDING MAIN DISCONNECT SWITCH.
 4. CONTRACTOR SHALL REMOVE EXISTING WATER HEATER AND SALVAGE TO OWNER. CONTRACTOR SHALL REMOVE CABLE AND EXPOSED CONDUIT BACK TO SOURCE.


CHEMICAL STORAGE AND FEED FACILITY
UPPER LEVEL POWER AND LIGHTING PLAN
 3/8" = 1'-0"

LOWER BIRD CREEK WWTP EXPANSION
 TMUA PROJECT NO. ES 2006-01
 CONTRACT 1B
 CHEMICAL STORAGE AND FEED FACILITY
 ELECTRICAL
 UPPER LEVEL POWER AND LIGHTING PLAN
 CITY OF TULSA, OKLAHOMA
 TULSA METROPOLITAN UTILITY AUTHORITY
 ENGINEERING SERVICES DEPARTMENT


PLANS AND ESTIMATES PREPARED BY:
BLACK & VEATCH
 Building a world of difference
 Black & Veatch Corporation
 Kansas City, Missouri
Holloway, Updike and Betten
 Consulting Engineers
 Muskogee - Broken Arrow
DINGATE
 Tulsa, Oklahoma

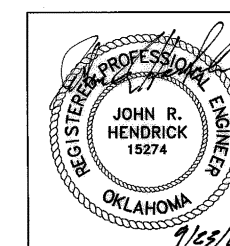


REVISION	BY	DATE	PLAN SCALE:	DRAWN	KMA	APPROVED:
				DESIGNED	SDS	
				SURVEY		
			PROFILE SCALE:	FIELD MGR.	7/31/11	
			HORIZONTAL:	SECT. MGR.	7/31/11	
			1" =	PROJ. MGR.	7/31/11	
			VERTICAL:	RECOMMENDED:	7/31/11	
			1" =			
			FILE:	DRAWING: CE-1		
			ATLAS PAGE NO:			

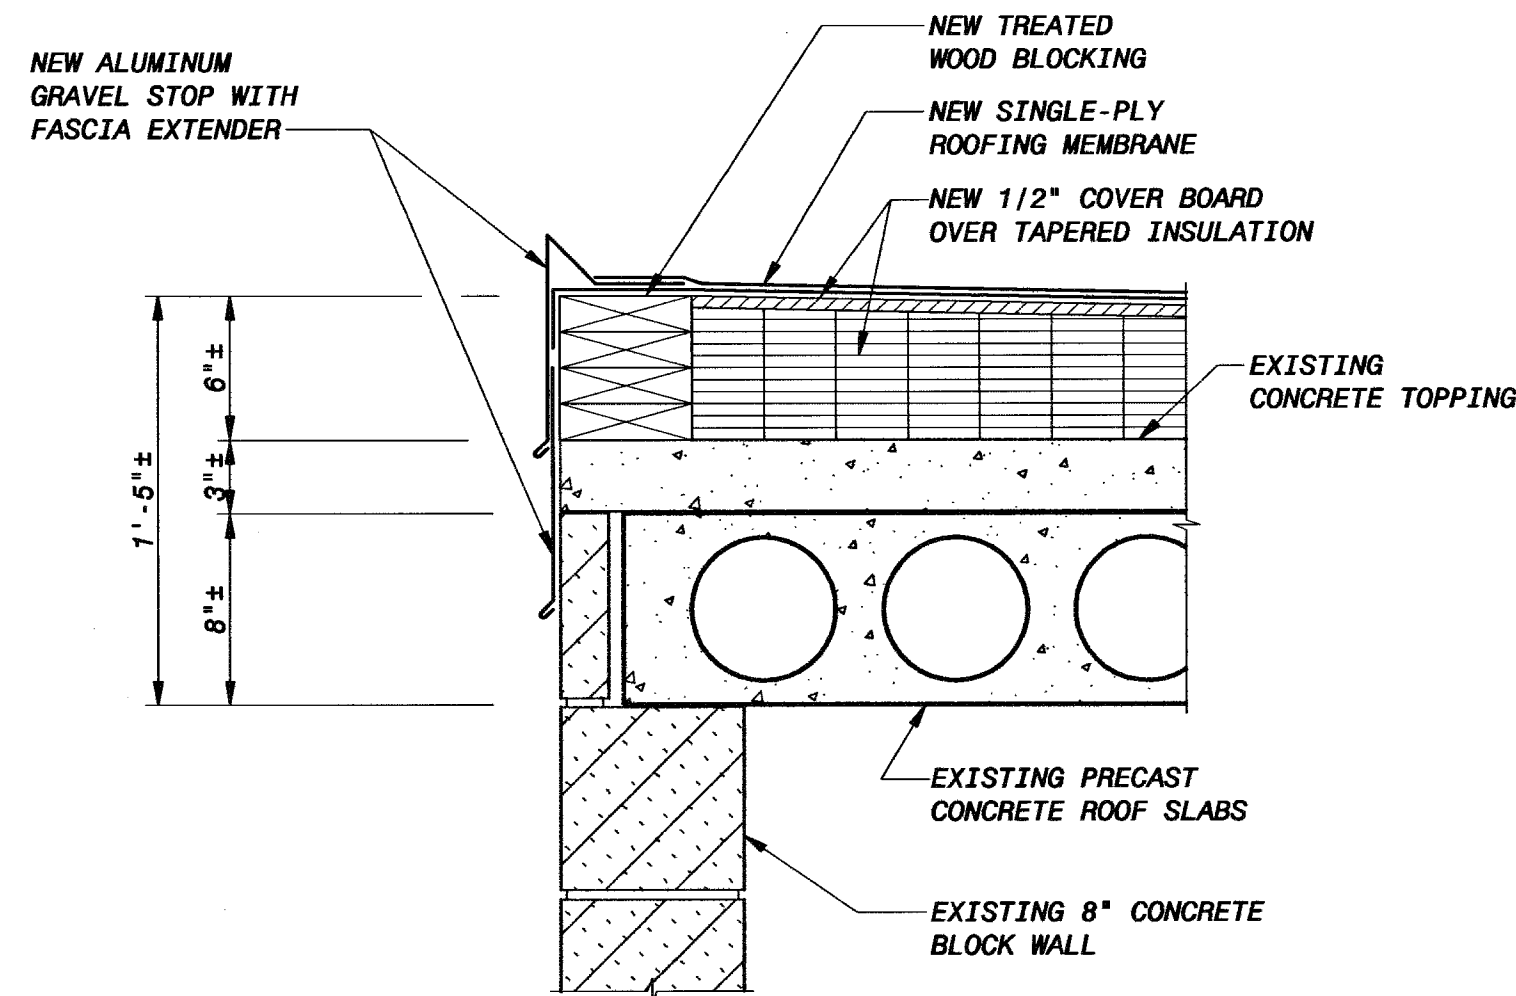

DETAIL A
1 1/2" = 1'-0"

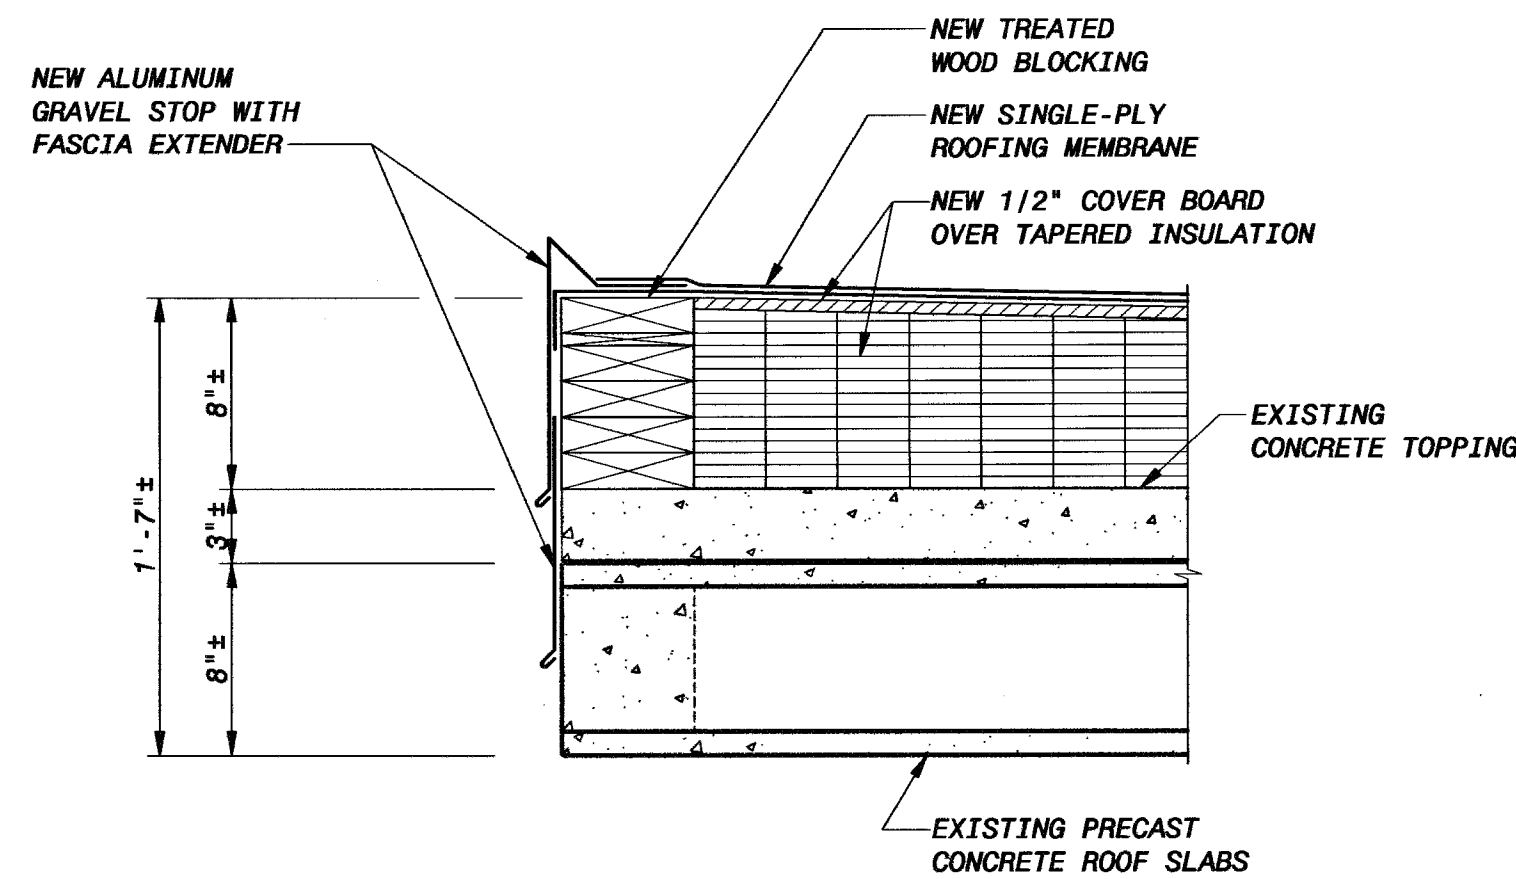


DETAIL B
1 1/2" = 1'-0"

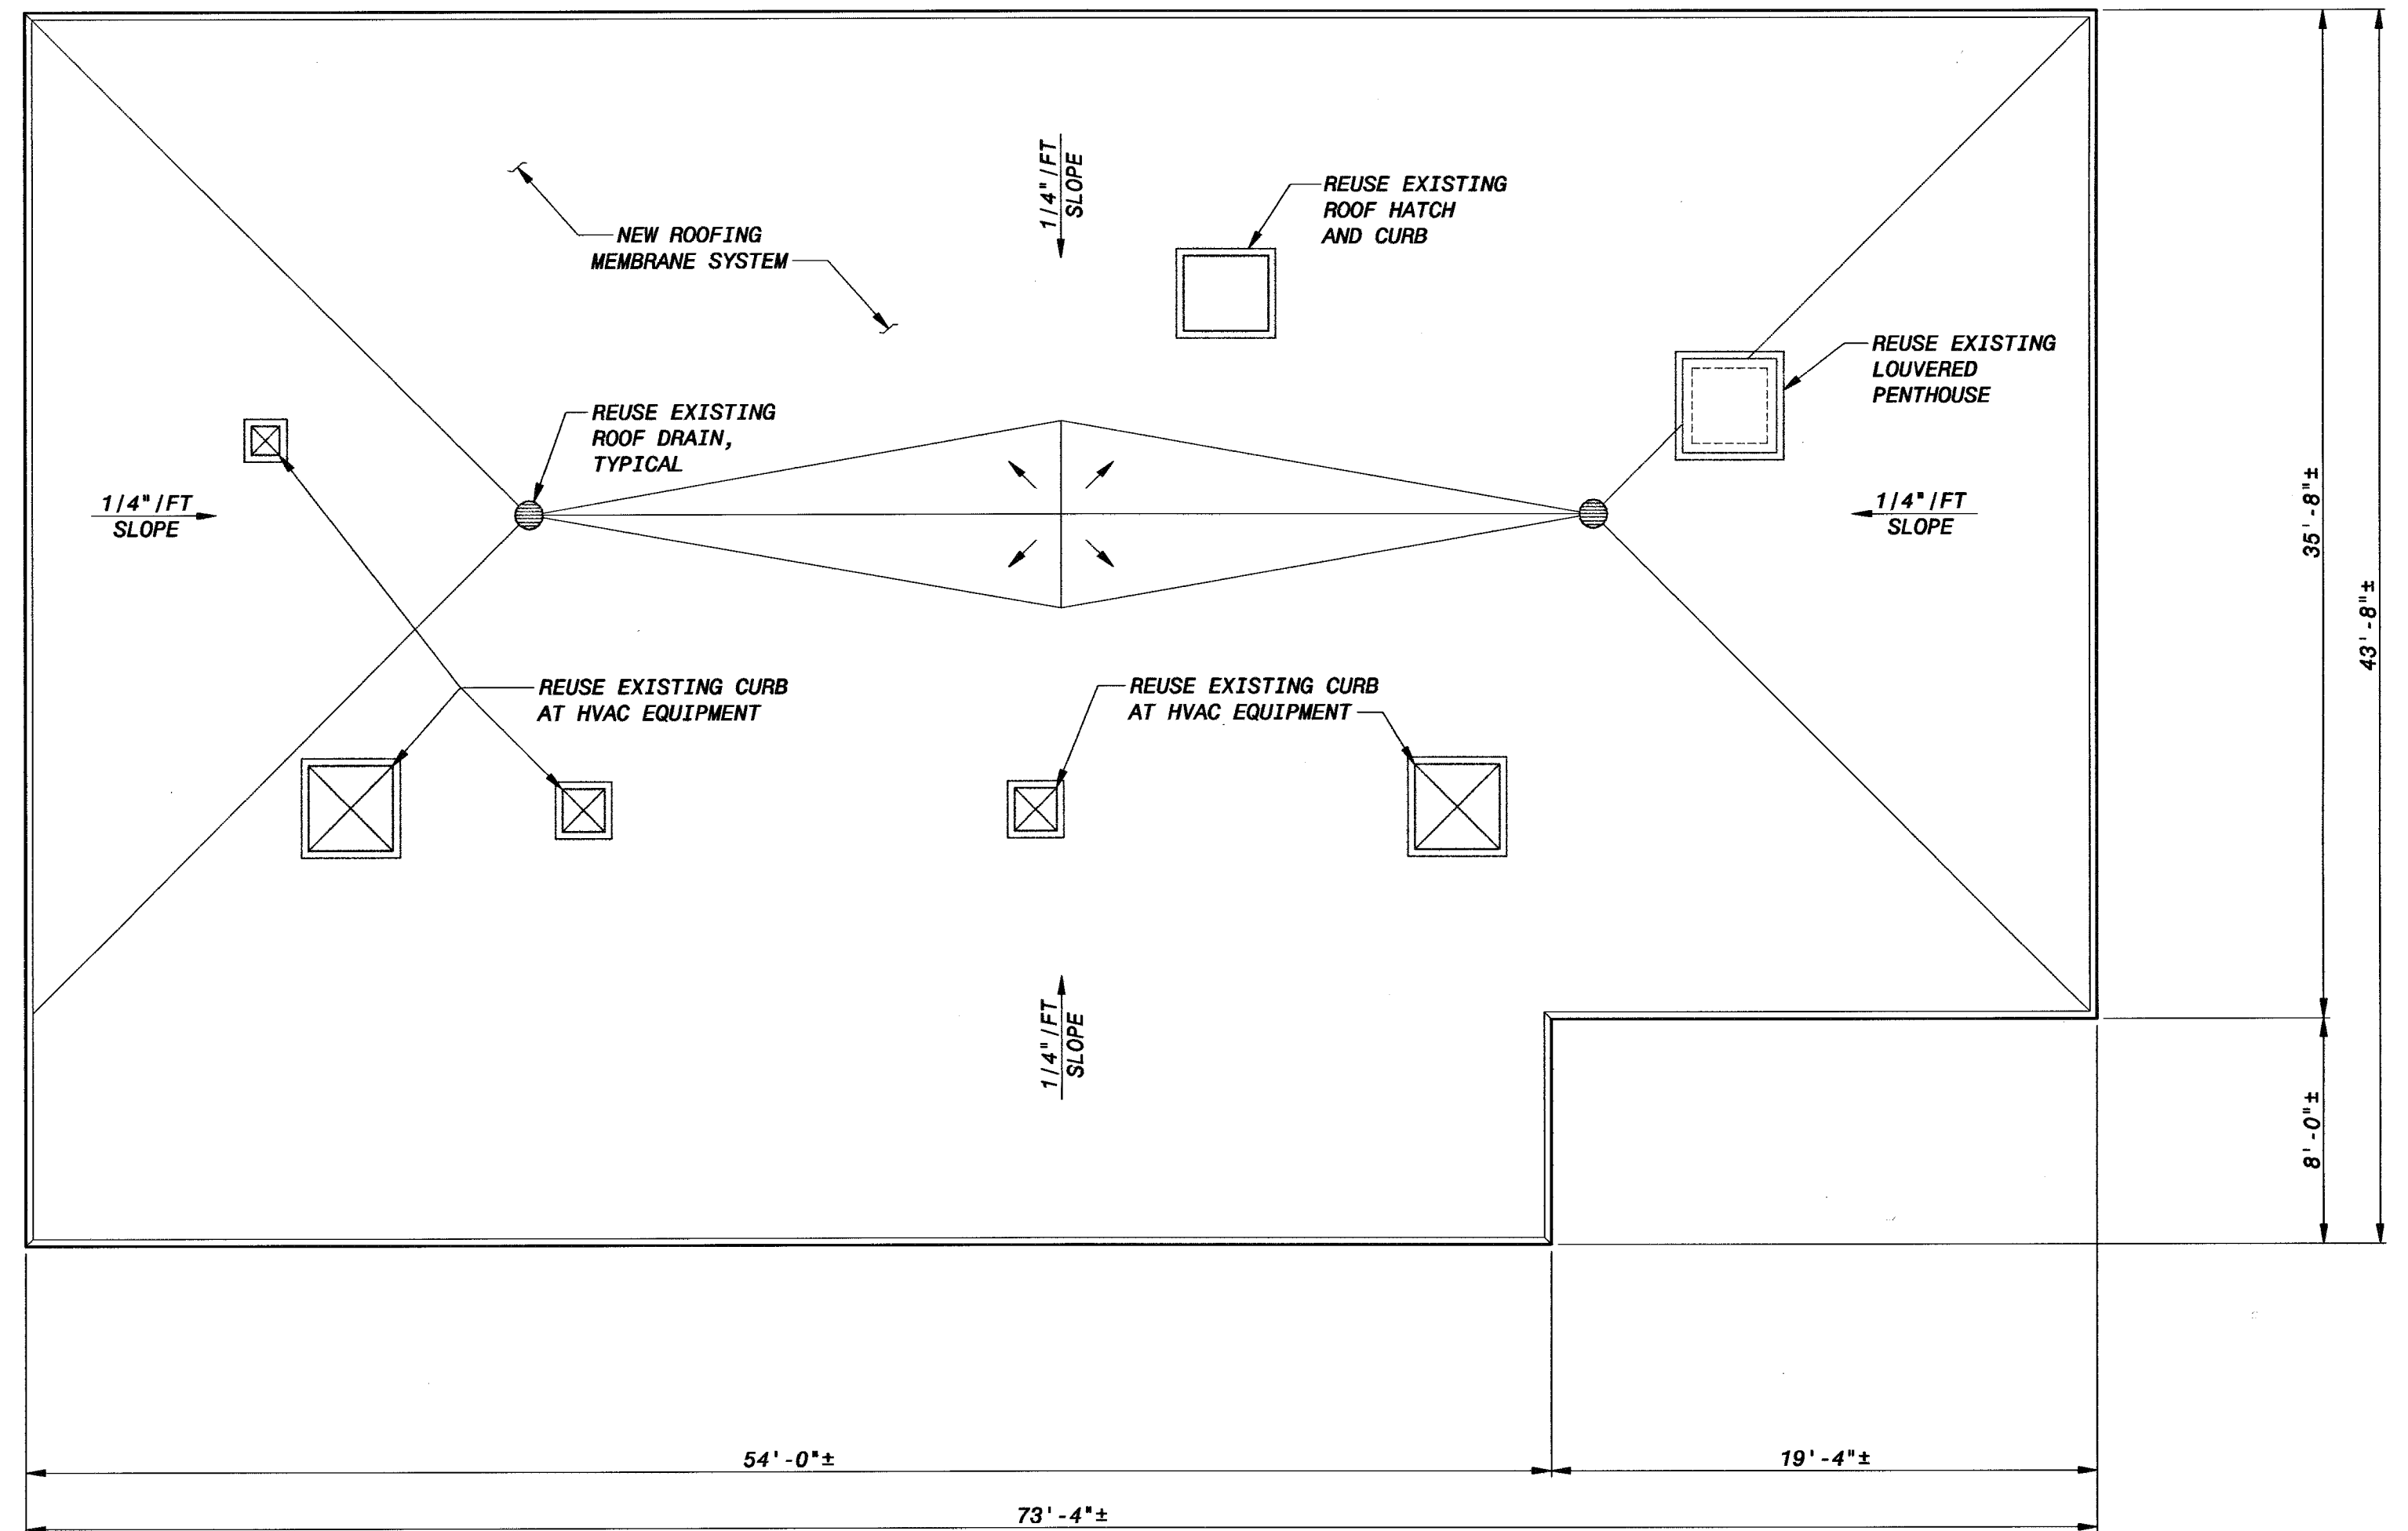

ROOF PLAN
3/16" = 1'-0"

NOTES:

1. PRIOR TO INSTALLATION OF NEW INSULATION AND MEMBRANE SYSTEM, EXISTING INSULATION AND MEMBRANE SYSTEM SHALL BE REMOVED. EXISTING ROOF CURB HATCHES, DRAINS, AND ALL STRUCTURAL COMPONENTS SHALL BE PROTECTED FROM DAMAGE DURING REMOVAL.

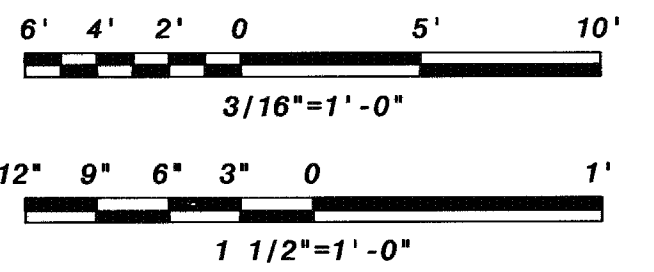

LOWER BIRD CREEK WWTP EXPANSION
TMUA PROJECT NO. ES 2006-01
CONTRACT 1B

RETURN SLUDGE PUMP STATION
ARCHITECTURAL
ROOF PLAN AND DETAILS

CITY OF TULSA, OKLAHOMA
TULSA METROPOLITAN UTILITY AUTHORITY
ENGINEERING SERVICES DEPARTMENT


PLANS AND ESTIMATES PREPARED BY:

BLACK & VEATCH
Building a world of difference

Holloway, Uptake and Ballen
Consulting Engineers
Montague - Broken Arrow

OWGATES
Engineering Services

	REVISION	BY	DATE	PLAN SCALE:	DRAWN	MDE	APPROVED:
	Addendum No. 1	PSB	1-6-12		DESIGNED	PDR	
					SURVEY		
				PROFILE SCALE:	FIELD MGR.	AS 10/11	
				HORIZONTAL:	SECT. MGR.		
				1" =	PROJ. MGR.	PSB 10/11	 DIRECTOR
				VERTICAL	RECOMMENDED:	HAS 10/11	
				1" =			
				FILE: BA-01	DRAWING: BA-1		DATE 10/28/2011
				ATLAS PAGE NO:			SHEET 157 OF 261 SHEETS

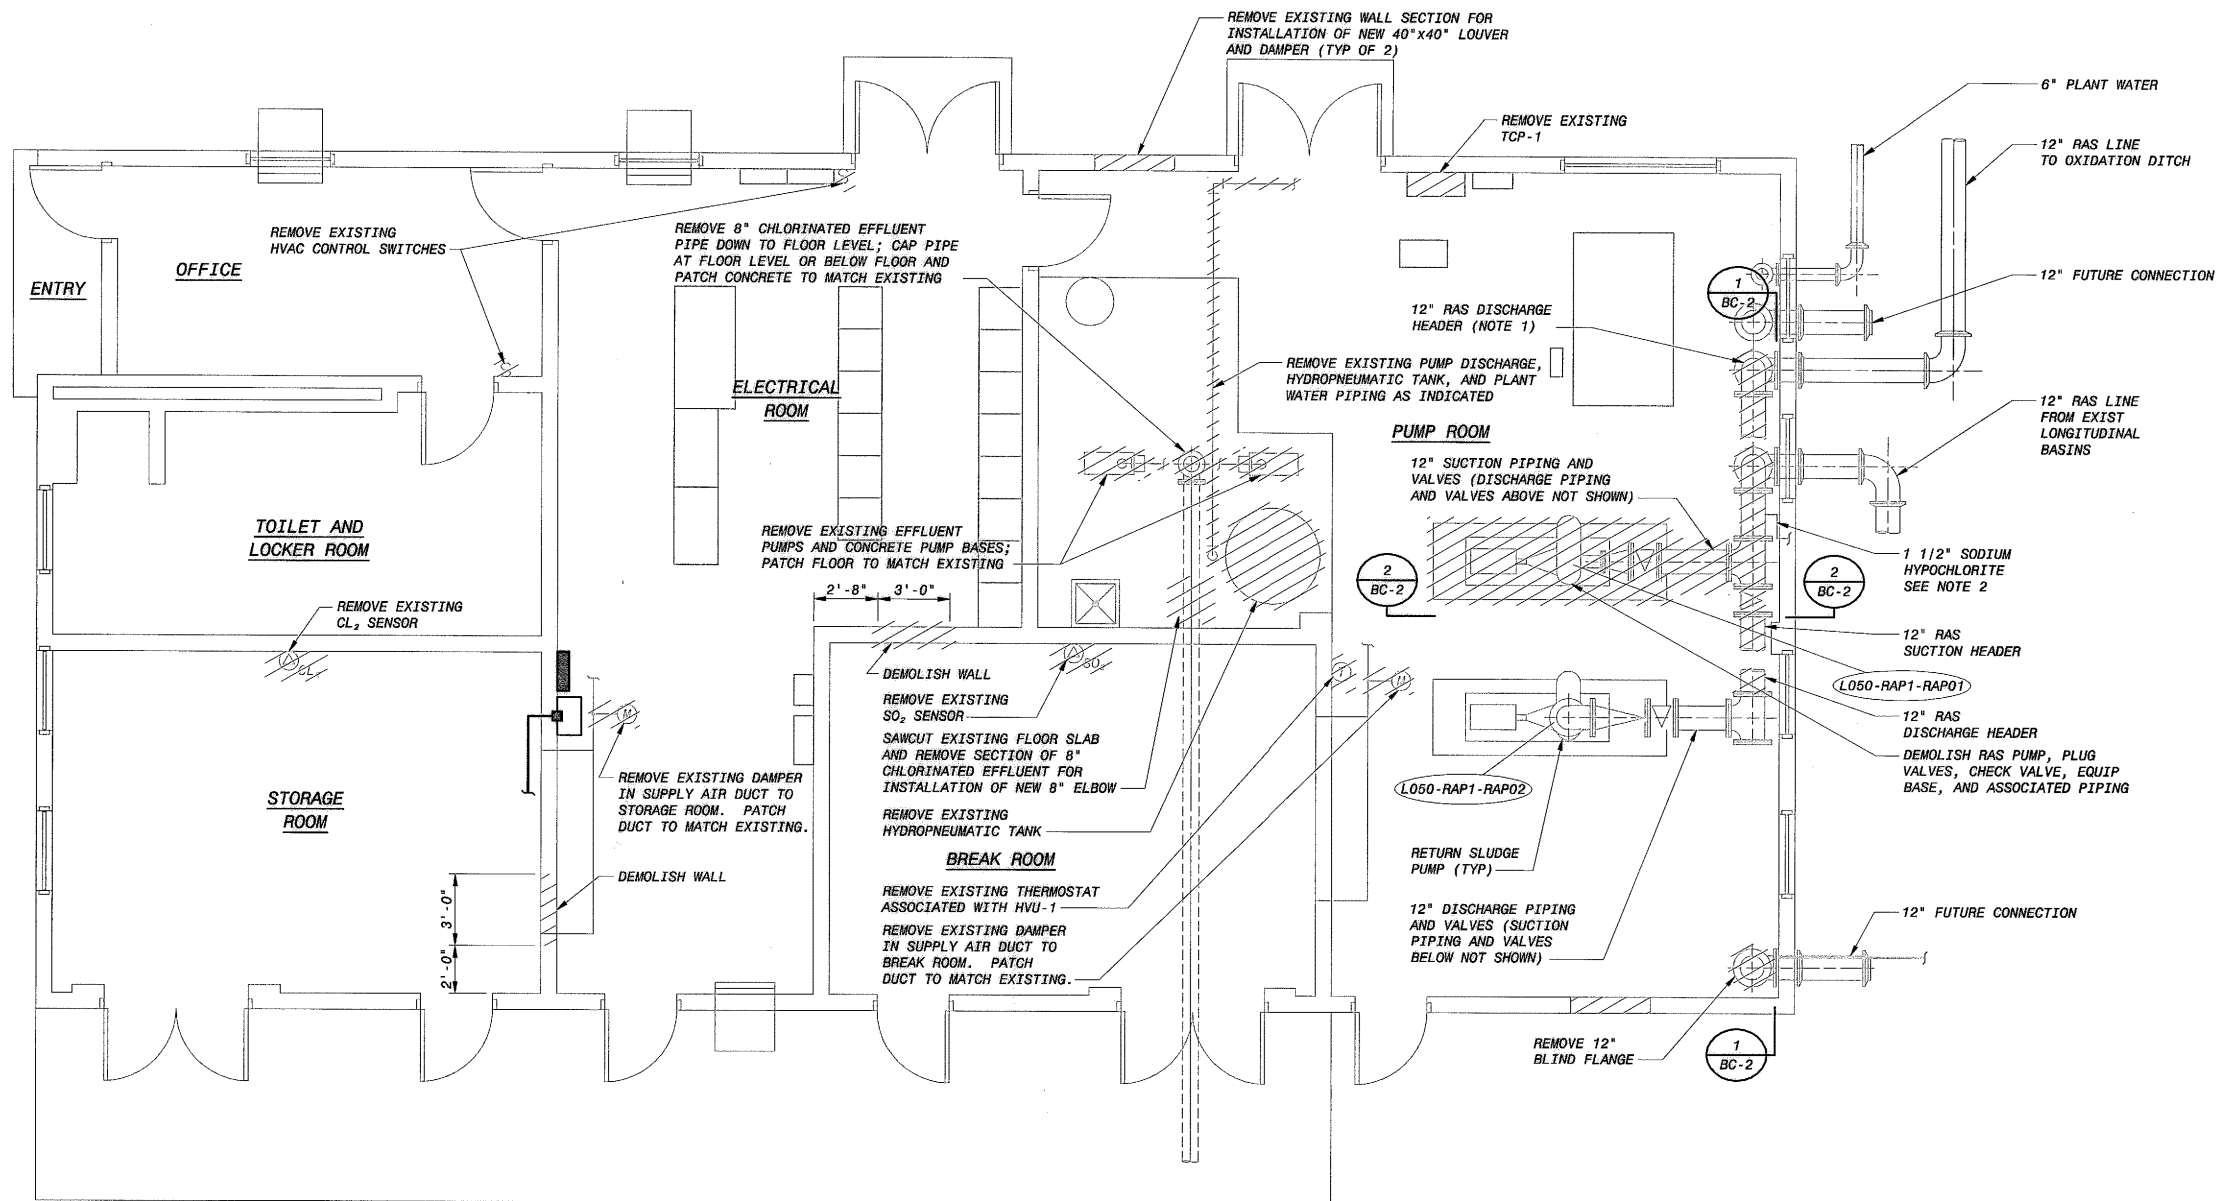


PLAN
1/4" = 1'-0"



NOTES:

1. REMOVE AND RELOCATE DISCHARGE HEADER TO LOWER ELEVATIONS, SEE SHEET BC-4. EXISTING PIPE SUPPORTS SHALL BE REMOVED AND REPLACED WITH NEW SUPPORTS AT REVISED ELEVATION. WHERE POSSIBLE, CONTRACTOR SHALL REUSE EXISTING PIPE SUPPORTS. ANY MODIFICATIONS TO EXISTING PIPE SUPPORTS SHALL BE COMPLETED IN A MANNER ACCEPTABLE TO ENGINEER.
2. REMOVE SODIUM HYPOCHLORITE LINE FROM 90° ELBOW TO RAS SUCTION PIPE. PLUG AND CAP EXISTING FEED POINT AT RAS SUCTION PIPE.

LOWER BIRD CREEK WWTP EXPANSION TMUA PROJECT NO. ES 2006-01 CONTRACT 1B			
RETURN SLUDGE PUMP STATION CIVIL/STRUCTURAL DEMOLITION PLAN			
CITY OF TULSA, OKLAHOMA TULSA METROPOLITAN UTILITY AUTHORITY ENGINEERING SERVICES DEPARTMENT			
PLANS AND ESTIMATES PREPARED BY:			
BLACK & VEATCH Building a world of difference Black & Veatch Corporation Kansas City, Missouri		HOLLOWAY, UPTAKE AND BELL Consulting Engineers Muskogee - Broken Arrow	
OWGATES Engineering Services			
PLAN SCALE: DESIGNED: CAC, JMS SURVEY:	DRAWN: JKS FIELD MGR.: JCS 10/11 SECT. MGR.: JCS 10/11 PROJ. MGR.: JCS 10/11 RECOMMENDED: HAS 10/30/11	APPROVED:	
PROFILE SCALE: HORIZONTAL: 1" = VERTICAL: 1" =	FILE: DRAWING: BC-1 ATLAS PAGE NO:	DATE 10/28/2011 SHEET 158 OF 261 SHEETS	

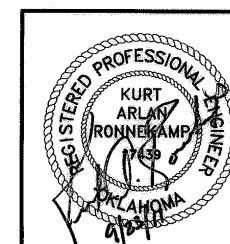


REVISION	BY	DATE

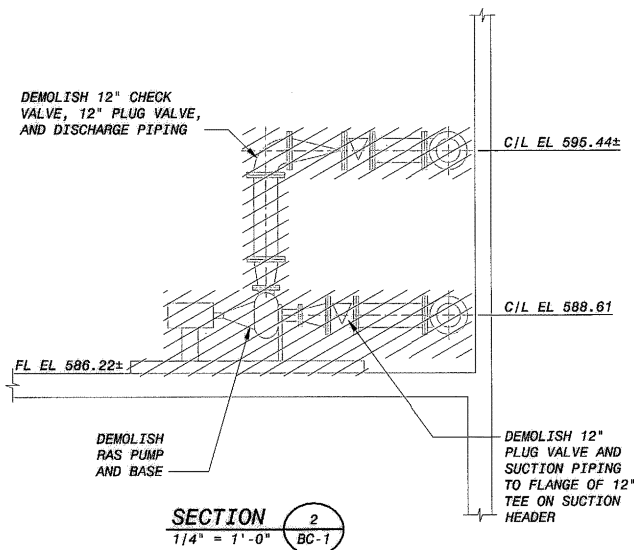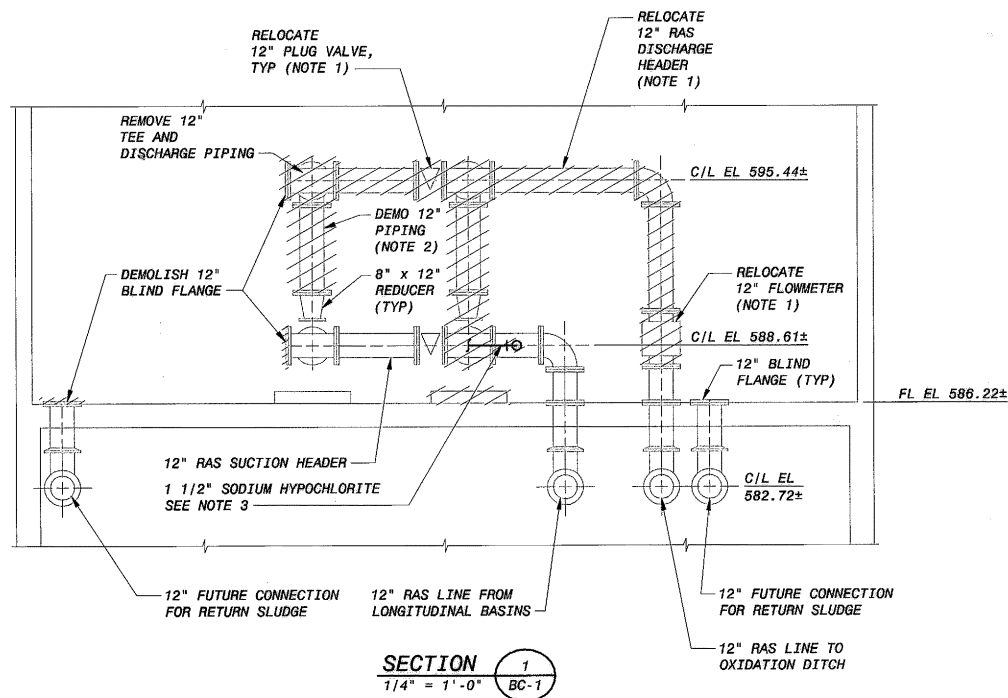


NOTES:


1. REMOVE AND RELOCATE DISCHARGE HEADER, PLUG VALVE, AND FLOWMETER. SEE SHEET BC-4. EXISTING PIPE SUPPORTS SHALL BE REMOVED AND REPLACED WITH NEW SUPPORTS AT REVISED ELEVATION. WHERE POSSIBLE, CONTRACTOR SHALL REUSE EXISTING PIPE SUPPORTS. ANY MODIFICATIONS TO EXISTING PIPE SUPPORTS SHALL BE COMPLETED IN A MANNER ACCEPTABLE TO ENGINEER.
2. PIPING SHALL BE REMOVED AS REQUIRED TO LOWER THE DISCHARGE HEADER ELEVATION TO 592.22.
3. REMOVE SODIUM HYPOCHLORITE LINE FROM 90° ELBOW TO RAS SUCTION PIPE. PLUG AND CAP EXISTING FEED POINT AT RAS SUCTION PIPE.

LOWER BIRD CREEK WWTP EXPANSION TMUA PROJECT NO. ES 2006-01 CONTRACT 1B			
RETURN SLUDGE PUMP STATION CIVIL/STRUCTURAL DEMOLITION SECTIONS			
CITY OF TULSA, OKLAHOMA TULSA METROPOLITAN UTILITY AUTHORITY ENGINEERING SERVICES DEPARTMENT			
PLANS AND ESTIMATES PREPARED BY:			
BLACK & VEATCH Building a world of difference		HOLLOWAY, UPTAKE AND BELL Consulting Engineers Washington - Boston - New York	
OWGATES Engineering Services		OWGATES Engineering Services	
PLAN SCALE:	DRAWN: JKS	DESIGNED: CAC, JMS	APPROVED:
PROFILE SCALE:	SURVEY	FIELD MGR. 709 John	SECT. MGR. 10/3/11
HORIZONTAL: 1" =	PROJ. MGR. 10/3/11	RECOMMENDED: 10/3/11	DIRECTOR: 10/3/11
VERTICAL: 1" =	FILE: DRAWING: BC-2	DATE: 10/28/2011	SHEET 159 OF 261 SHEETS
ATLAS PAGE NO:	9-28-11	B&V PROJECT NO. 132886	

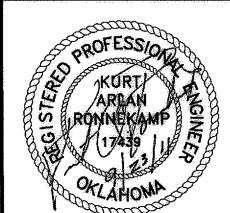


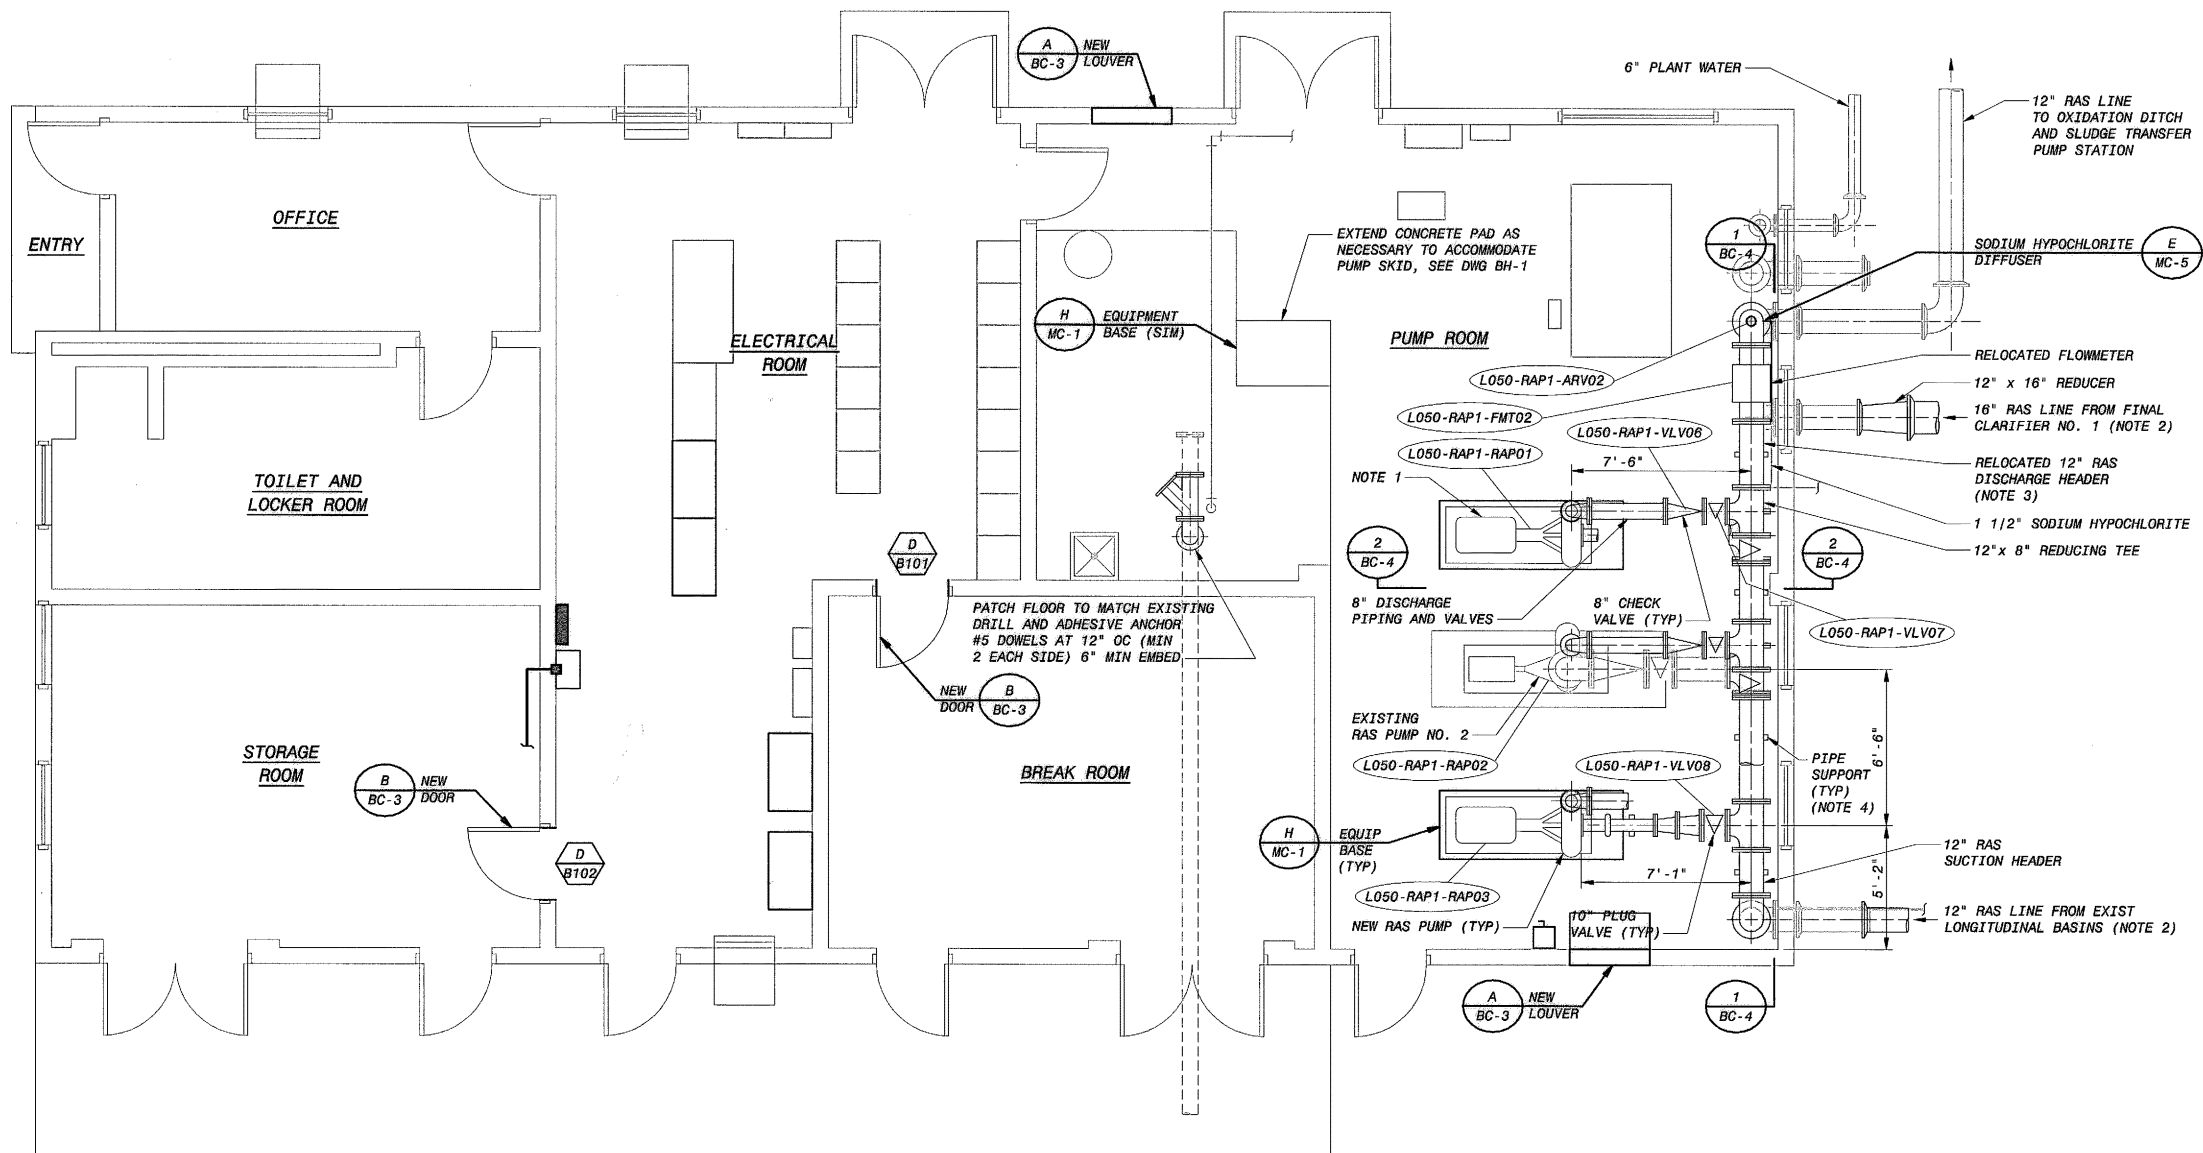

PLAN
1/4" = 1'-0"

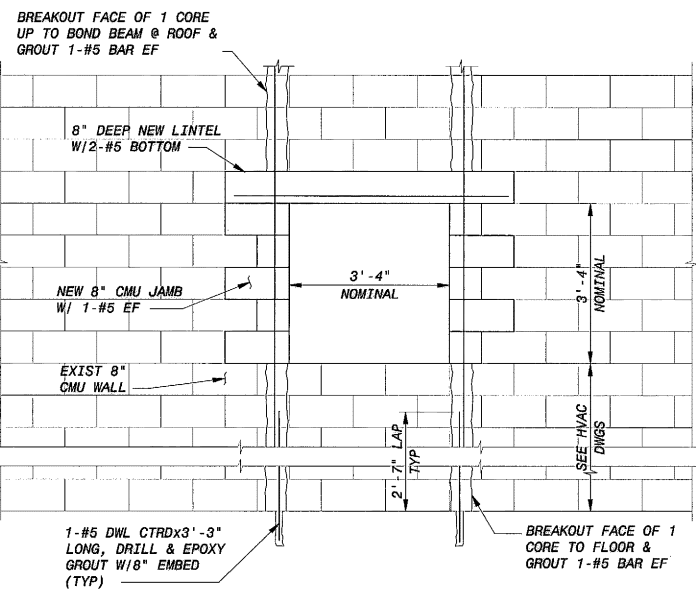


LOUVER DETAIL A
1/2" = 1'-0"

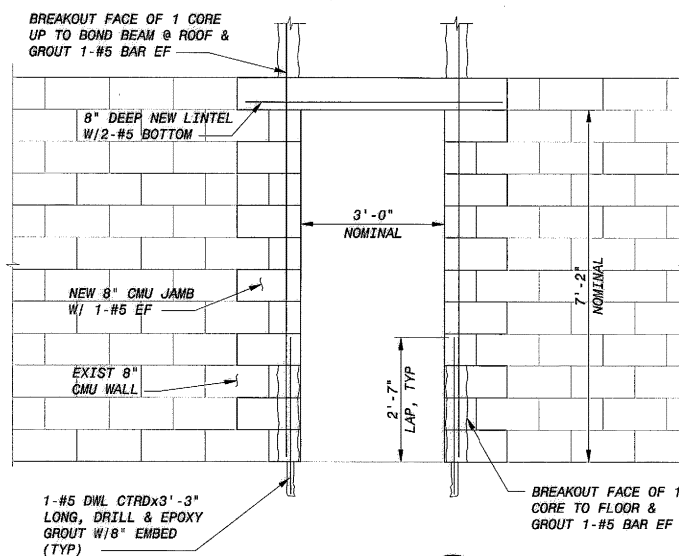

DOOR DETAIL B
1/2" = 1'-0"

NOTES:

1. A 1400 GPM NON-CLOG, HORIZONTAL, END-SUCTION CENTRIFUGAL PUMP SHALL REPLACE THE EXISTING PUMP. THE EXISTING CHECK AND PLUG VALVES SHALL BE REPLACED.
2. THE EXISTING 12" RAS LINE FROM THE EXISTING LONGITUDINAL BASINS WILL BE RE-ROUTED IN THE YARD TO ENTER THE RETURN SLUDGE PUMP STATION AT THE FUTURE CONNECTION LOCATED AT THE SOUTHEAST CORNER OF THE BUILDING. THE NEW 16" RAS LINE FROM THE FINAL CLARIFIER NO. 1 WILL USE THE CONNECTION CURRENTLY USED BY THE EXISTING LONGITUDINAL BASINS.
3. DISCHARGE HEADER SHALL BE RELOCATED. ALL DISCHARGE FITTINGS AND VALVES SHALL BE RELOCATED, SEE SHEET BC-4.
4. WHERE POSSIBLE, CONTRACTOR SHALL REUSE EXISTING PIPE SUPPORTS. ANY MODIFICATIONS TO EXISTING PIPE SUPPORTS SHALL BE COMPLETED IN A MANNER ACCEPTABLE TO ENGINEER.


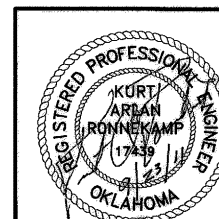


REVISION	BY	DATE

LOWER BIRD CREEK WWTP EXPANSION TMUA PROJECT NO. ES 2006-01 CONTRACT 1B RETURN SLUDGE PUMP STATION CIVIL/STRUCTURAL PLAN			
CITY OF TULSA, OKLAHOMA TULSA METROPOLITAN UTILITY AUTHORITY ENGINEERING SERVICES DEPARTMENT			
PLANS AND ESTIMATES PREPARED BY: BLACK & VEATCH Building a world of difference. Kansas City, Missouri			
HOLLOWAY, UPTON AND STALLION Consulting Engineers Muskogee - Broken Arrow			
DWGATES Engineering Services			
PLAN SCALE: DRAWN: JKS DESIGNED: CAC, JMS SURVEY: PROFILE SCALE: FIELD MGR. JKS 10/11 SECT. MGR. JKS 10/11 PROJ. MGR. JKS 10/11 RECOMMENDED: JKS 10/11 HKS 10/11	APPROVED: DIRECTOR: [Signature] DATE 10/28/2011	FILE: DRAWING: BC-3 ATLAS PAGE NO:	
SHEET 160 OF 261 SHEETS		B&V PROJECT NO. 132886	


PLOTTED DATE: 9/21/2011 7:14:14 PM Batch Plot
SAVED DATE: 9/19/2011 11:11:22 AM
C:\NET ID: 145120-3000-C-B0005KJS

FD145120
DI45120BY

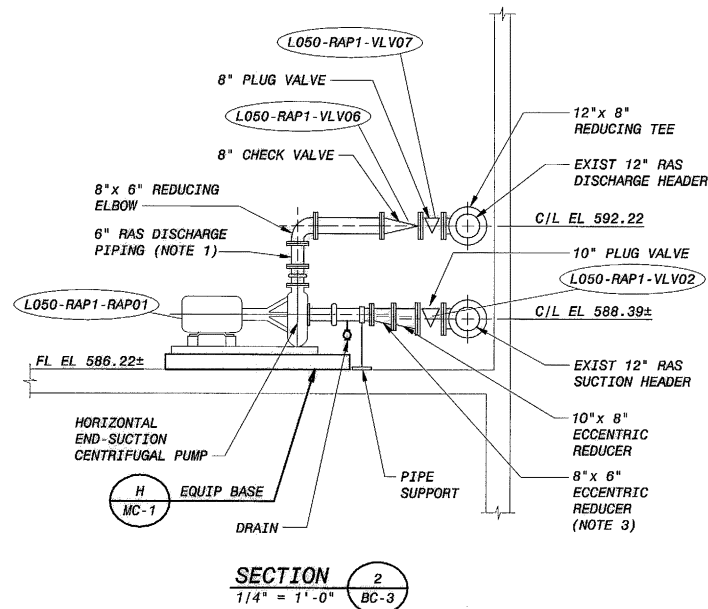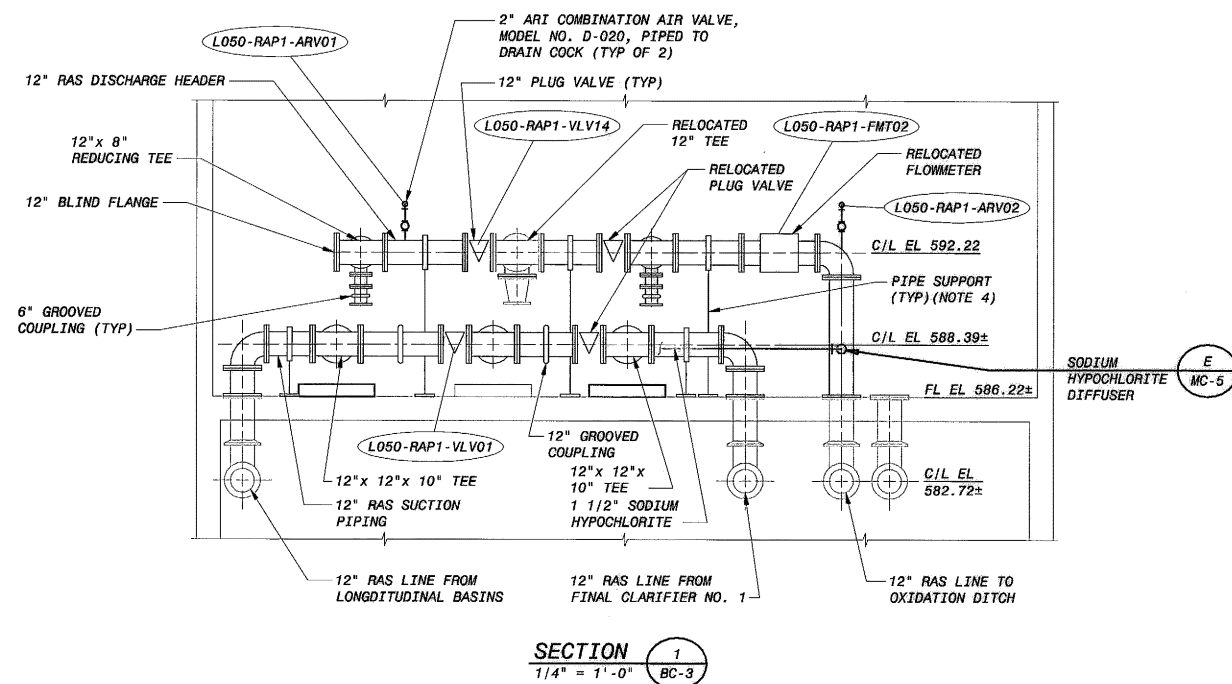


NOTES:

1. COORDINATE WITH PUMP SUPPLIER ON SIZE OF DISCHARGE CONNECTION.
2. COORDINATE WITH PUMP SUPPLIER ON THE LENGTHS OF SPOOL PIECES REQUIRED DUE TO VARYING INLET AND DISCHARGE CONNECTIONS. MINIMUM LENGTH OF SPOOL IS 6".
3. 8"x6" ECCENTRIC REDUCER MAY NOT BE NECESSARY, COORDINATE WITH PUMP SUPPLIER ON THE SIZE OF THE INLET.
4. WHERE POSSIBLE, CONTRACTOR SHALL REUSE EXISTING PIPE SUPPORTS. ANY MODIFICATIONS TO EXISTING PIPE SUPPORTS SHALL BE COMPLETED IN A MANNER ACCEPTABLE TO ENGINEER.

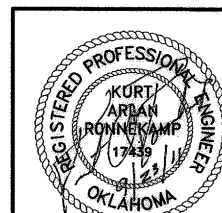

REVISION	BY	DATE

LOWER BIRD CREEK WWTP EXPANSION TMUA PROJECT NO. ES 2006-01 CONTRACT 1B			
RETURN SLUDGE PUMP STATION CIVIL/STRUCTURAL SECTIONS			
CITY OF TULSA, OKLAHOMA TULSA METROPOLITAN UTILITY AUTHORITY ENGINEERING SERVICES DEPARTMENT			
PLANS AND ESTIMATES PREPARED BY:			
Black & Veatch Corporation Kansas City, Missouri			
PLAN SCALE:		APPROVED:	
DRAWN: JKS			
DESIGNED: CAC, JMS			
SURVEY: [Signature]			
FIELD MGR. [Signature]			
PROFILE SCALE:		DATE 10/28/2011	
HORIZONTAL: 1" = [Scale]		SHEET 161 OF 261 SHEETS	
VERTICAL: 1" = [Scale]		ATLAS PAGE NO:	
FILE: DRAWING: BC-4		JBS 9-28-11 B&V PROJECT NO. 132886	

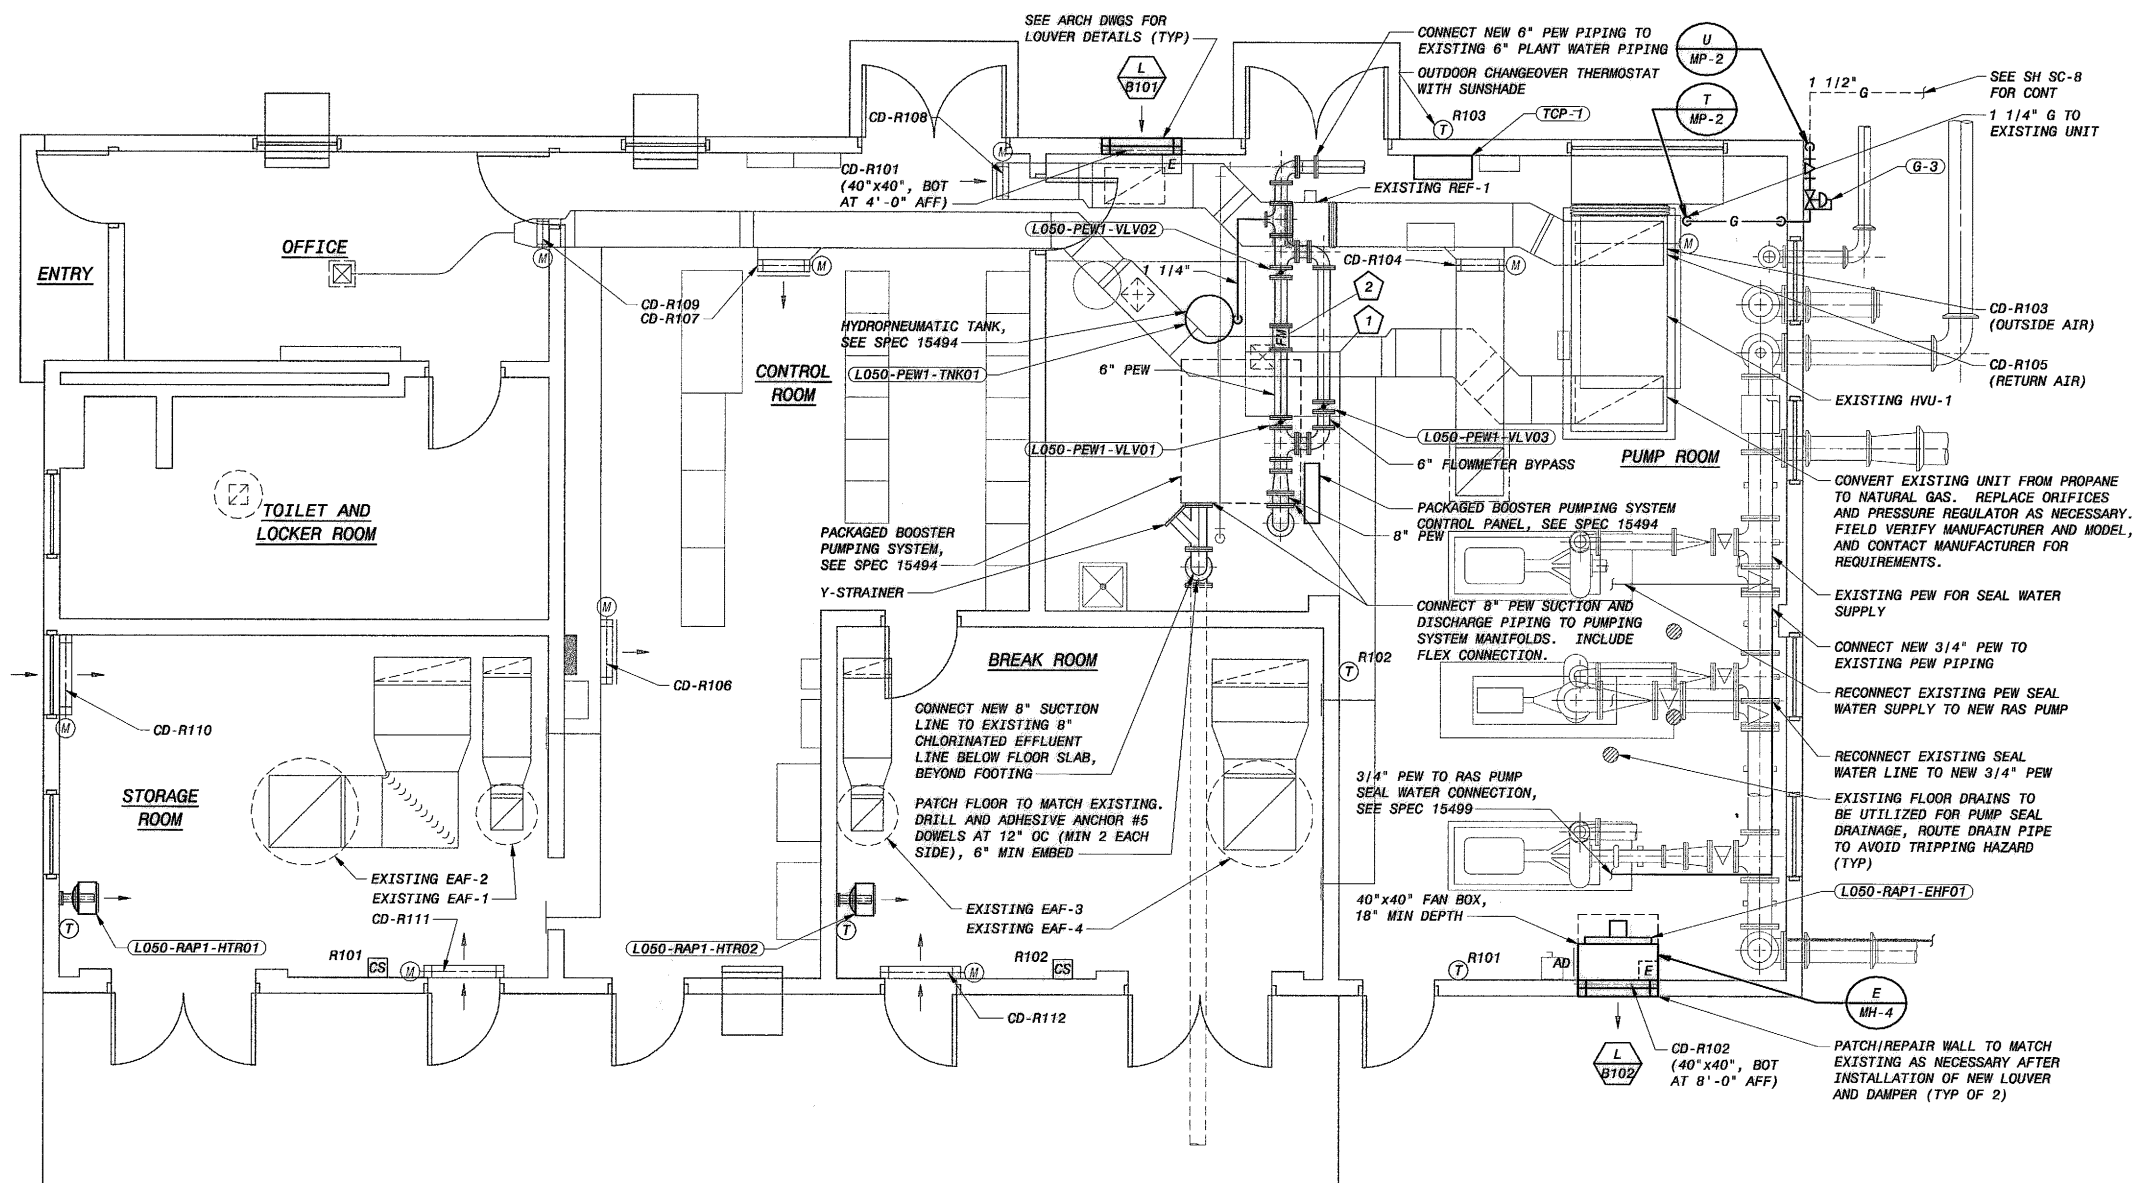


FLOOR PLAN
1/4" = 1'-0"

- GENERAL NOTES:**
1. REMOVE ALL CONTROLS ASSOCIATED WITH EXISTING HVAC SYSTEMS RECEIVING NEW CONTROLS AS INDICATED IN THE SEQUENCE OF OPERATIONS PARAGRAPH 6 ON SH MH3.
 2. SEE SHEET BC-1 FOR DEMOLITION.
 3. CONTROL DAMPERS ASSOCIATED WITH THE EXISTING HVAC SYSTEMS SHALL BE RE-LABELED AS INDICATED.

- PLAN NOTES:**
1. EXTEND CONCRETE PAD AS NECESSARY TO ACCOMMODATE PUMP SKID, WITHOUT OBSTRUCTING REMOVAL PATH FOR OTHER EQUIPMENT INSTALLED IN THE PUMP ROOM. SEE CIVIL SHEETS FOR EQUIPMENT BASE DETAILS (SIM).
- FLOWMETER PROVIDED WITH THE PUMPING SYSTEM SHALL BE INSTALLED IN THE OVERHEAD DISCHARGE PIPING. ADEQUATE STRAIGHT PIPING LENGTH SHALL BE PROVIDED FOR METER INSTALLATION.

LOWER BIRD CREEK WWTP EXPANSION TMAA PROJECT NO. ES 2006-01 CONTRACT 1B			
RETURN SLUDGE PUMP STATION PLUMBING/HVAC FLOOR PLAN			
CITY OF TULSA, OKLAHOMA TULSA METROPOLITAN UTILITY AUTHORITY ENGINEERING SERVICES DEPARTMENT			
PLANS AND ESTIMATES PREPARED BY:			
Black & Veatch Corporation Kansas City, Missouri			
Holloway, Updeave and Ballen Consulting Engineers Muskogee, Broken Arrow			
O'GATE Engineering Services			
REVISION			
BY			
DATE			
PLAN SCALE:			
DRAWN			
DESIGNED			
SURVEY			
PROFILE SCALE:			
FIELD MGR.			
SECT. MGR.			
PROJ. MGR.			
RECOMMENDED:			
FILE: BH-01.DWG			
DRAWING: BH-1			
DATE 10/28/2011			
SHEET 162 OF 261 SHEETS			



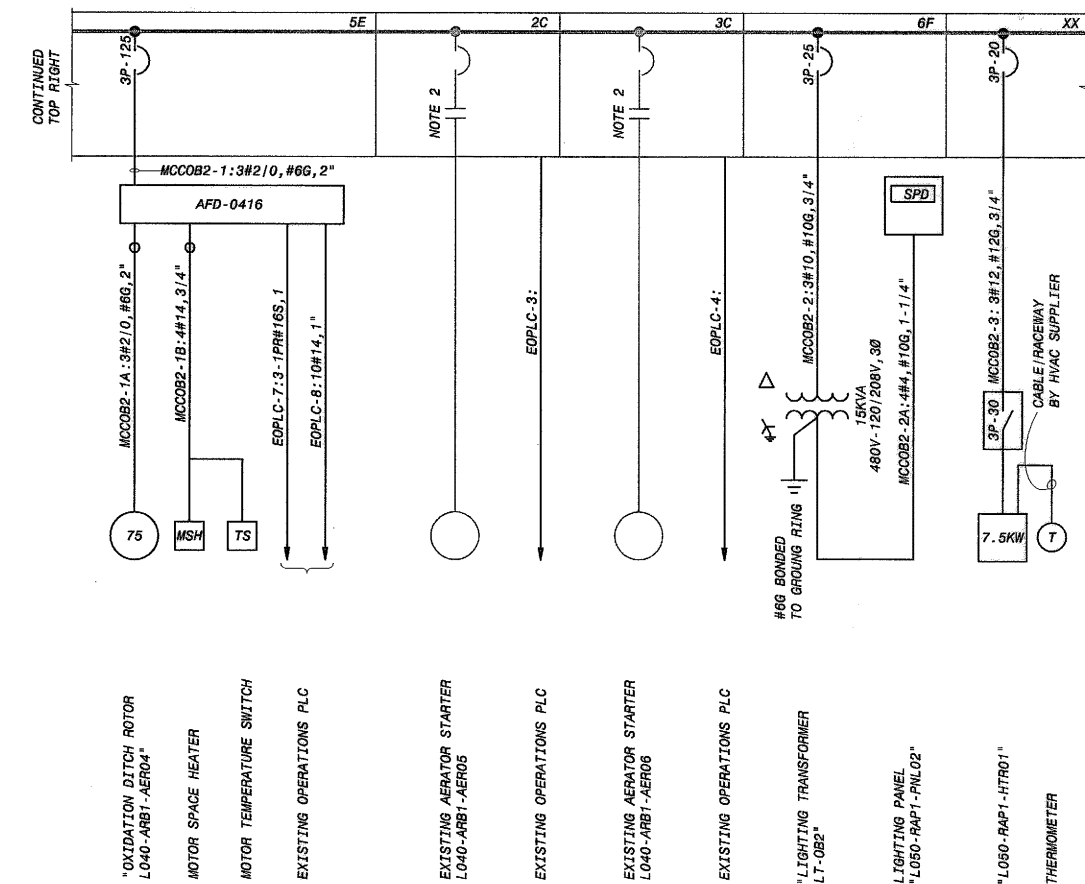

NOTES:


1. SEE DRAWING GE-1 FOR ELECTRICAL LEGEND & ABBREVIATIONS AND GENERAL REQUIREMENTS.
2. CONTRACTOR SHALL MODIFY STARTER WIRING AS SHOWN IN ELECTRICAL SCHEMATICS.

	REVISION	BY	DATE	PLAN SCALE:	DRAWN	KMA	APPROVED:
					DESIGNED	SDS	
					SURVEY		
					PROFILE SCALE:	FIELD MGR.	TS 10/11
					HORIZONTAL:	SECT. MGR.	
				1" =	PROJ. MGR.	BE 10/3/11	
				VERTICAL	RECOMMENDED:		
				1" =	HAS 10/30/11		DIRECTOR 
				FILE:	DRAWING: BE-2		DATE 10/28/2011
				ATLAS PAGE NO:			SHEET 164 OF 261 SHEETS

LOWER BIRD CREEK WWTP EXPANSION
TMUA PROJECT NO. ES 2006-01
CONTRACT 1B
RETURN SLUDGE PUMP STATION
ELECTRICAL
EXISTING MCC-0B1 ONE-LINE DIAGRAM
CITY OF TULSA, OKLAHOMA
SA METROPOLITAN UTILITY AUTHORITY
ENGINEERING SERVICES DEPARTMENT

 PLANS AND ESTIMATES PREPARED BY:




PLAN SCALE:		DRAWN	KMA	APPROVED:
		DESIGNED	SDS	
		SURVEY		
PROFILE SCALE:		FIELD MGR.	<i>TS</i> <i>10/11</i>	
HORIZONTAL: 1" =		SECT. MGR.		 DIRECTOR
		PROJ. MGR.	<i>BE</i> <i>10/3/11</i>	
VERTICAL 1" =		RECOMMENDED:		
			<i>HHS</i> <i>10/20/11</i>	
FILE:		DRAWING: BE - 2		DATE 10/28/2011
ATLAS PAGE NO:				SHEET 164 OF 261 SHEETS

PLOTTED DATE: HET53306, 6/14/2011, 12:13:28 PM
SAVED DATE: AND4974, 9/22/2011, 9:53:08 AM
CYPNET ID: 745120-3000-E-8000130R


FD145120
D145120B

RETURN SLUDGE PUMP

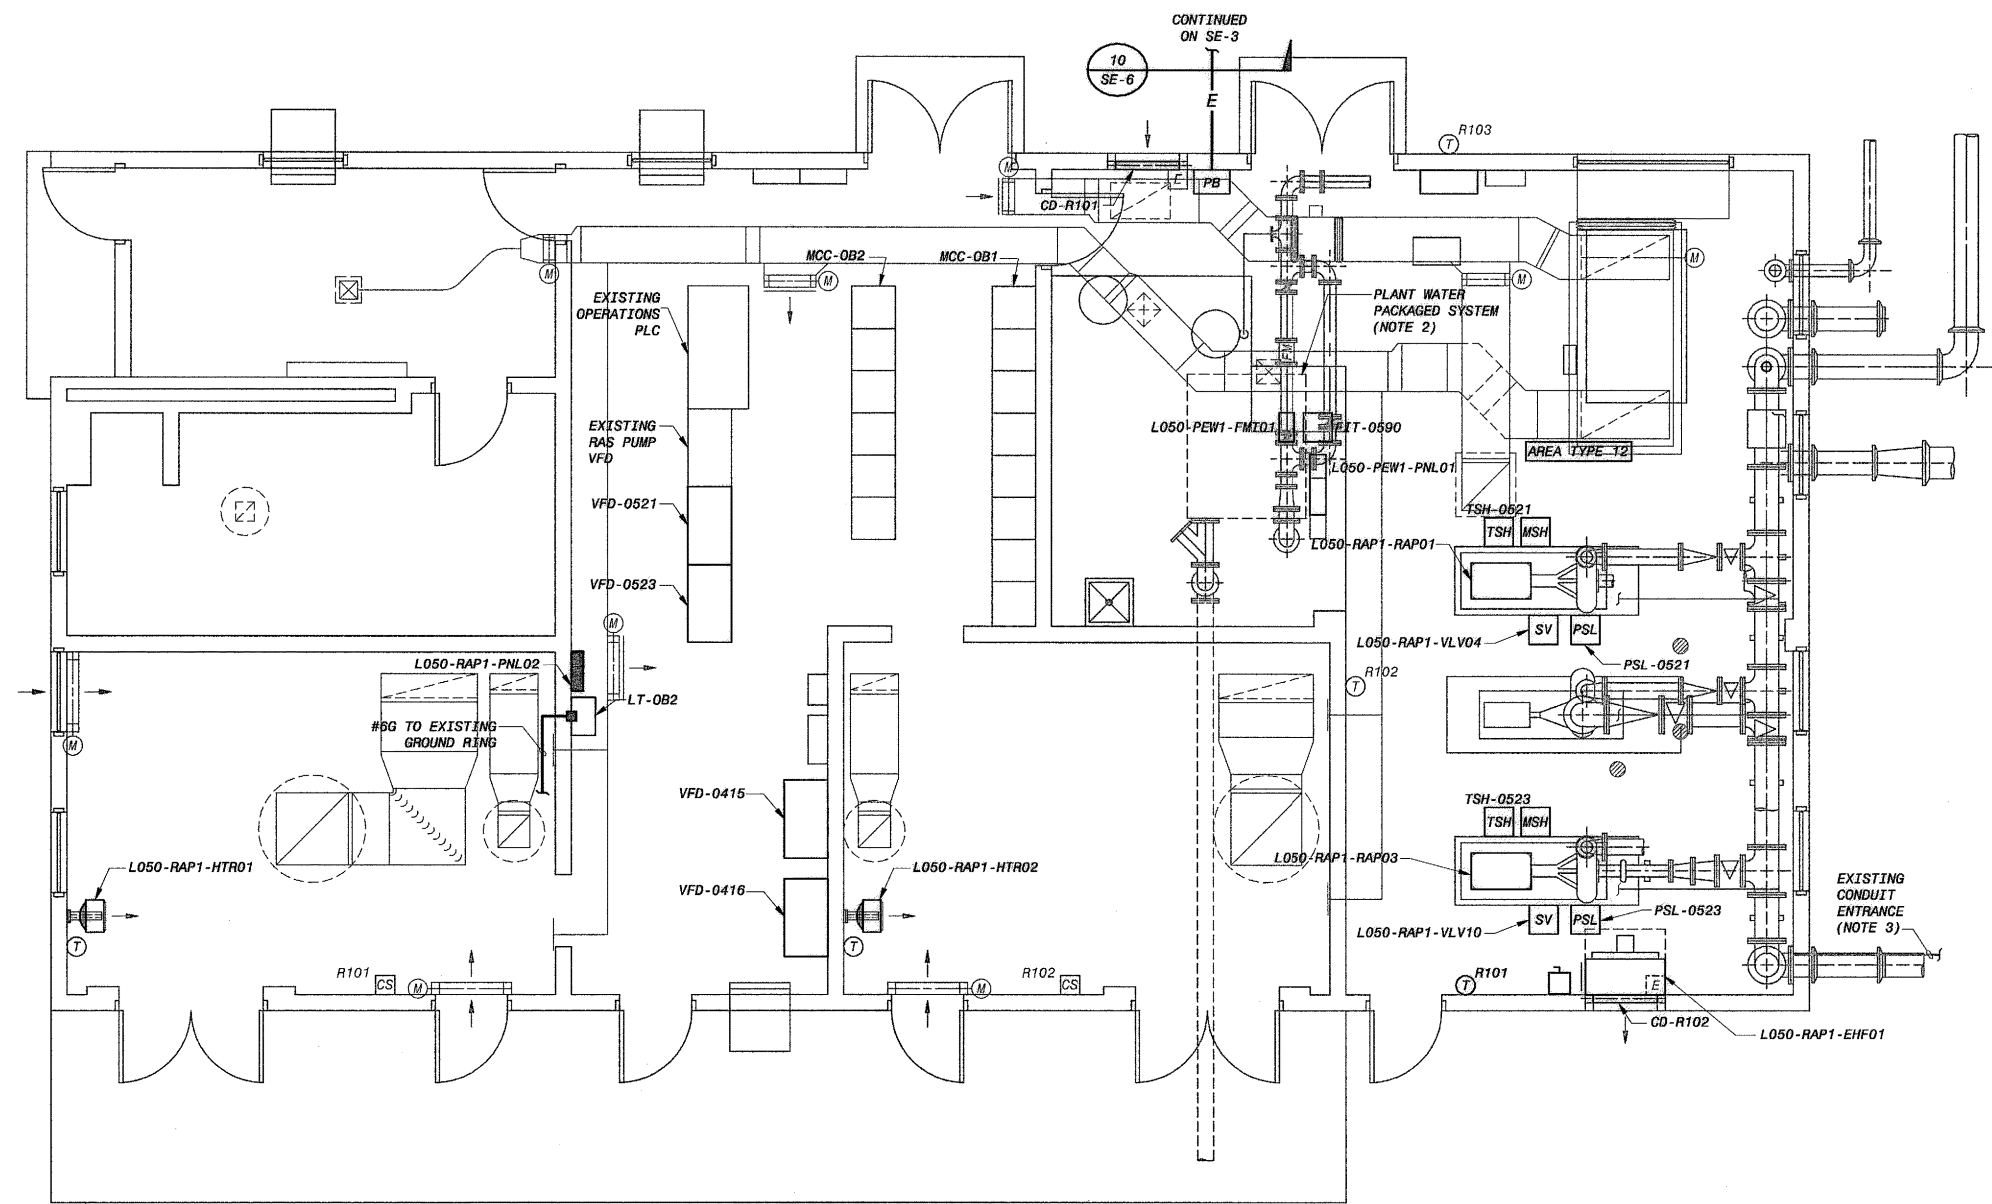


POWER PLAN
1/4" = 1'-0"

- NOTES:**
- SEE DRAWING GE-1 FOR ELECTRICAL LEGEND & ABBREVIATIONS AND GENERAL REQUIREMENTS.
 - PACKAGED SYSTEM INCLUDES L050-PEW1, -PWP01, -PWP02, -PWP03, -PWP04 & PIT-0590.
 - CONTRACTOR SHALL RELOCATE 4 EXISTING CONDUITS ENTERING BUILDING WHICH CONFLICT WITH NEW PIPING TO BE INSTALLED. CONTRACTOR SHALL REMOVE ALL CABLE ROOTED THROUGH EXISTING CONDUIT. PROVIDE NEW CONDUIT AS REQUIRED TO CIRCUMVENT PIPING CONFLICT, AND INSTALL NEW CABLE TO MATCH EXISTING. EXISTING CIRCUITS ARE AS FOLLOWS:
 - 3#2, #86, 2°C
 - 3#2, #86, 2°C
 - 41#12, 2°C
 - 2-1PR#16S, 2-1PR#18S, 3°CFOR BIDDING PURPOSES ASSUME ALL CIRCUITS ARE 180 FEET IN LENGTH.

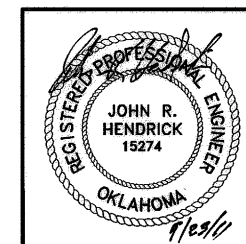

REVISION	BY	DATE


LOWER BIRD CREEK WWTP EXPANSION TMUA PROJECT NO. ES 2006-01 CONTRACT 1B			
RETURN SLUDGE PUMP STATION ELECTRICAL POWER PLAN			
CITY OF TULSA, OKLAHOMA TULSA METROPOLITAN UTILITY AUTHORITY ENGINEERING SERVICES DEPARTMENT			
PLANS AND ESTIMATES PREPARED BY:			
DRAWN: KMA		APPROVED:	
DESIGNED: SDS			
SURVEY:			
PROFILE SCALE: FIELD MGR. 10/11			
HORIZONTAL: 1" = 100'			
VERTICAL: 1" = 40'		DATE 10/28/2011	
FILE: DRAWING: BE-4		SHEET 166 OF 261 SHEETS	
ATLAS PAGE NO:		B&V PROJECT NO. 132886	

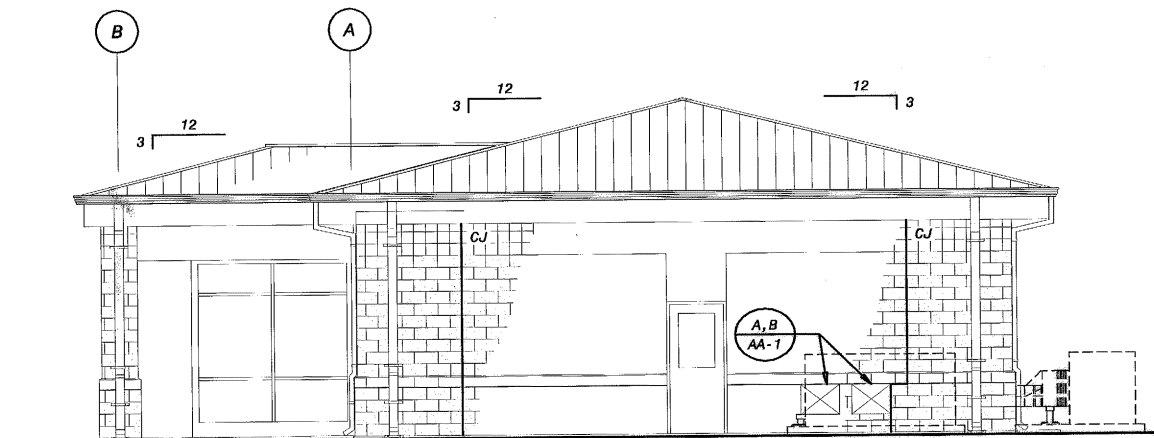

W
A104

D
A103

EAST ELEVATION
3/16" = 1'-0"

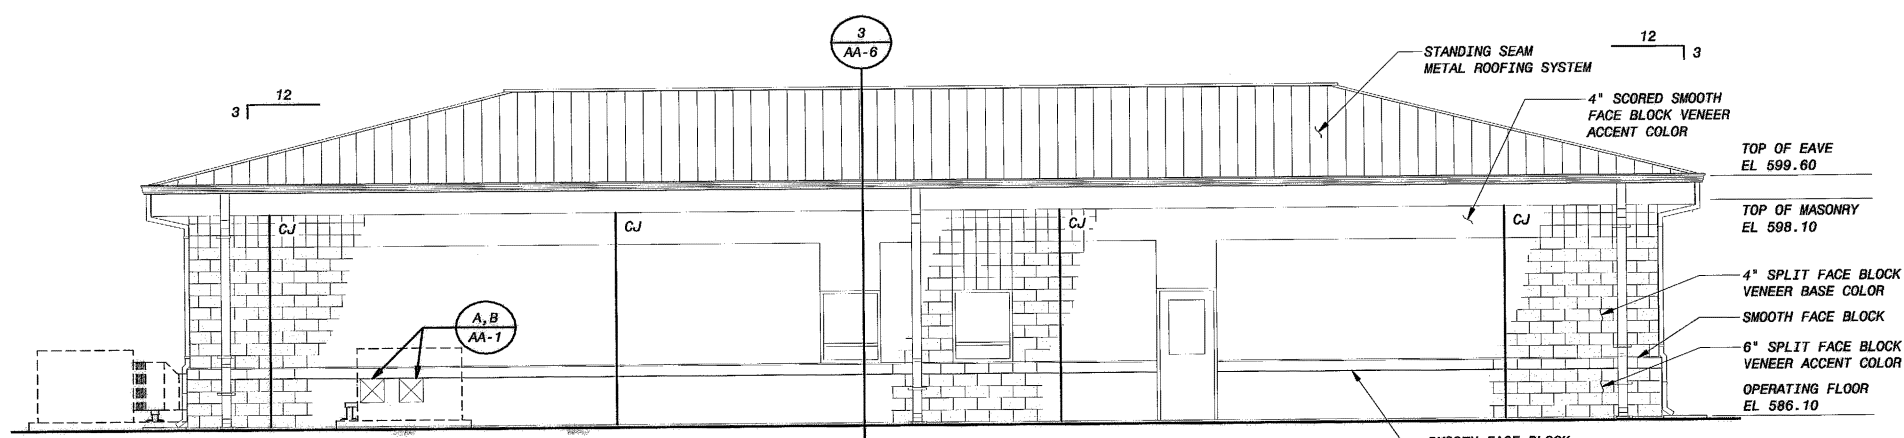


W
A109

W
A110

D
A104

NORTH ELEVATION
3/16" = 1'-0"

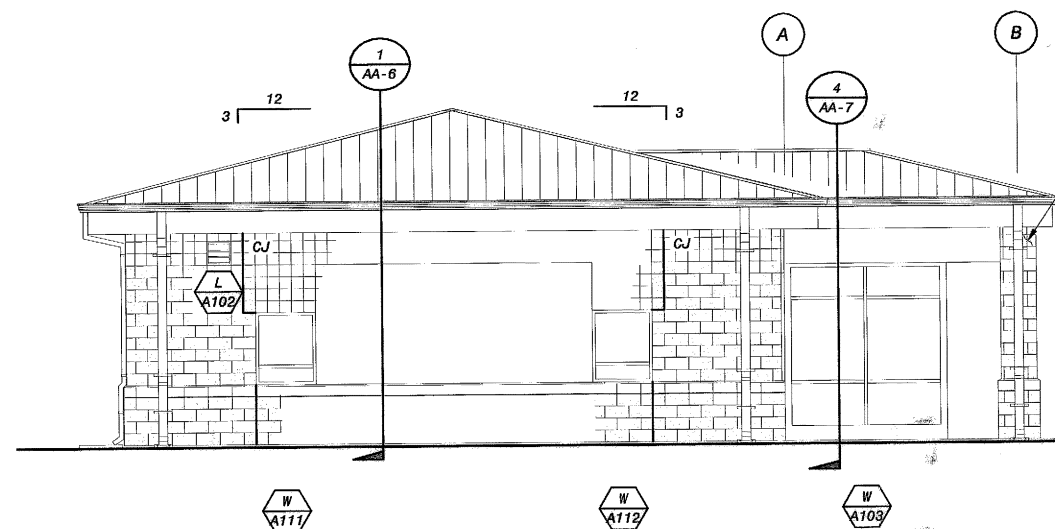


W
A111

W
A112

W
A103

WEST ELEVATION
3/16" = 1'-0"

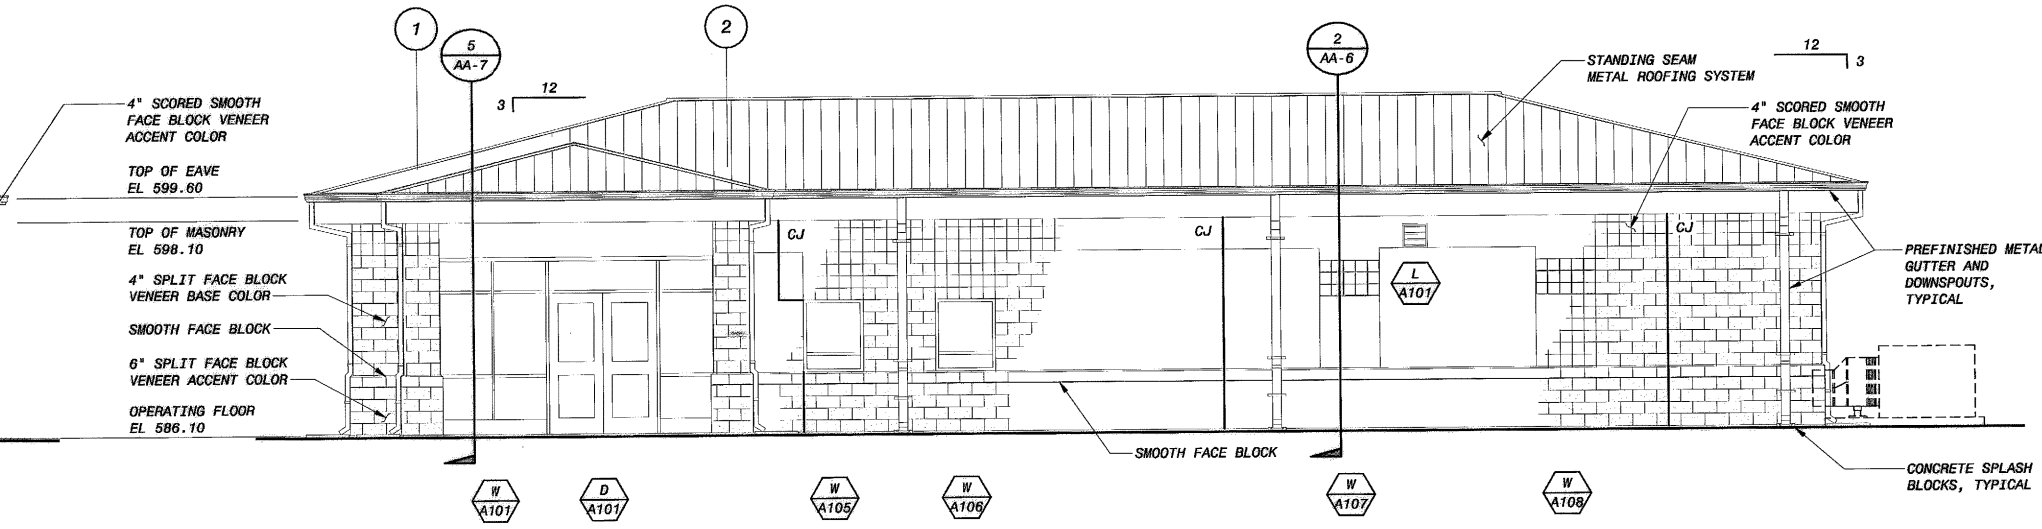

W
A101

D
A101


W
A105

W
A106


W
A107

W
A108

SOUTH ELEVATION
3/16" = 1'-0"

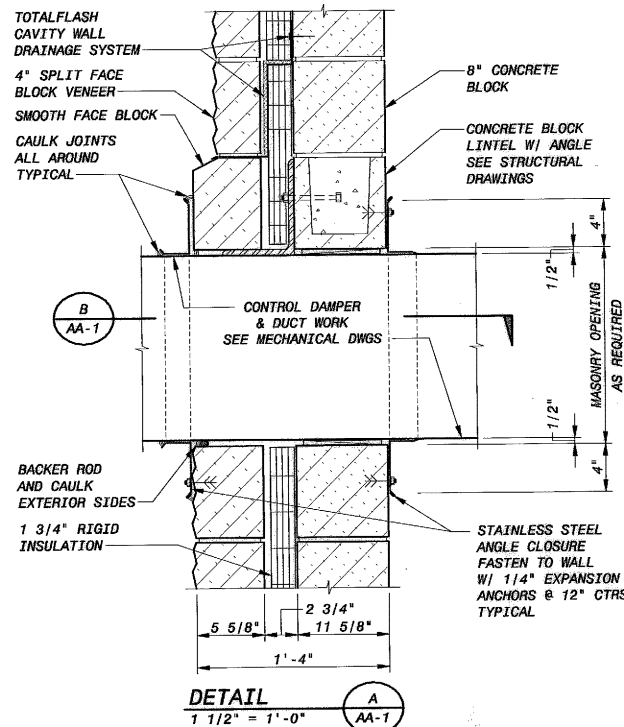


DETAIL
1 1/2" = 1'-0"

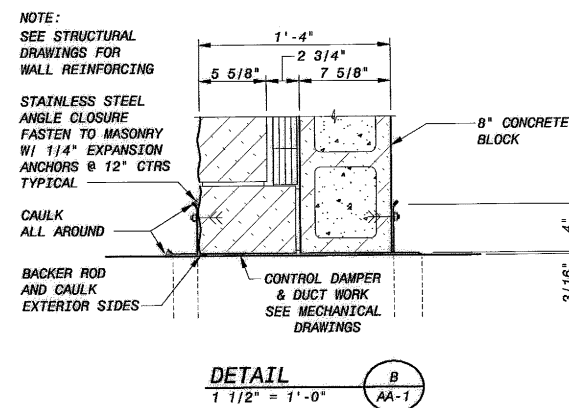


DETAIL
1 1/2" = 1'-0"

NOTES:


1. VENEER FACE BLOCK CONTROL JOINT (CJ).
SEE STRUCTURAL DRAWINGS
FOR BACKUP CONCRETE MASONRY UNITS (CMU) WALL
CONTROL JOINT LOCATIONS.

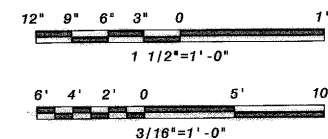

LOWER BIRD CREEK WWTP EXPANSION TMUA PROJECT NO. ES 2006-01 CONTRACT 1B			
OPERATIONS BUILDING ARCHITECTURAL BUILDING ELEVATIONS			
CITY OF TULSA, OKLAHOMA TULSA METROPOLITAN UTILITY AUTHORITY ENGINEERING SERVICES DEPARTMENT			
PLANS AND ESTIMATES PREPARED BY:			
 BLACK & VEATCH Building a world of difference		 Holloway, Updike and Ballen Consulting Engineers Mechanical - Structural - Airflow	
Black & Veatch Corporation Kansas City, Missouri		 DINGATES Engineering Services	
PLAN SCALE:	DRAWN	TMB	APPROVED:
	DESIGNED	PDR	
	SURVEY		
PROFILE SCALE:	FIELD MGR.	7/10/11	
HORIZONTAL:	SECT. MGR.		
1" =	PROJ. MGR.	7/10/11	 DIRECTOR
VERTICAL	RECOMMENDED:		
1" =	7/10/11		
FILE: AA-01	DRAWING: AA-1		DATE 10/28/2011
ATLAS PAGE NO:			SHEET 167 OF 261 SHEETS

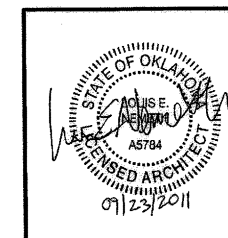


REVISION	BY	DATE

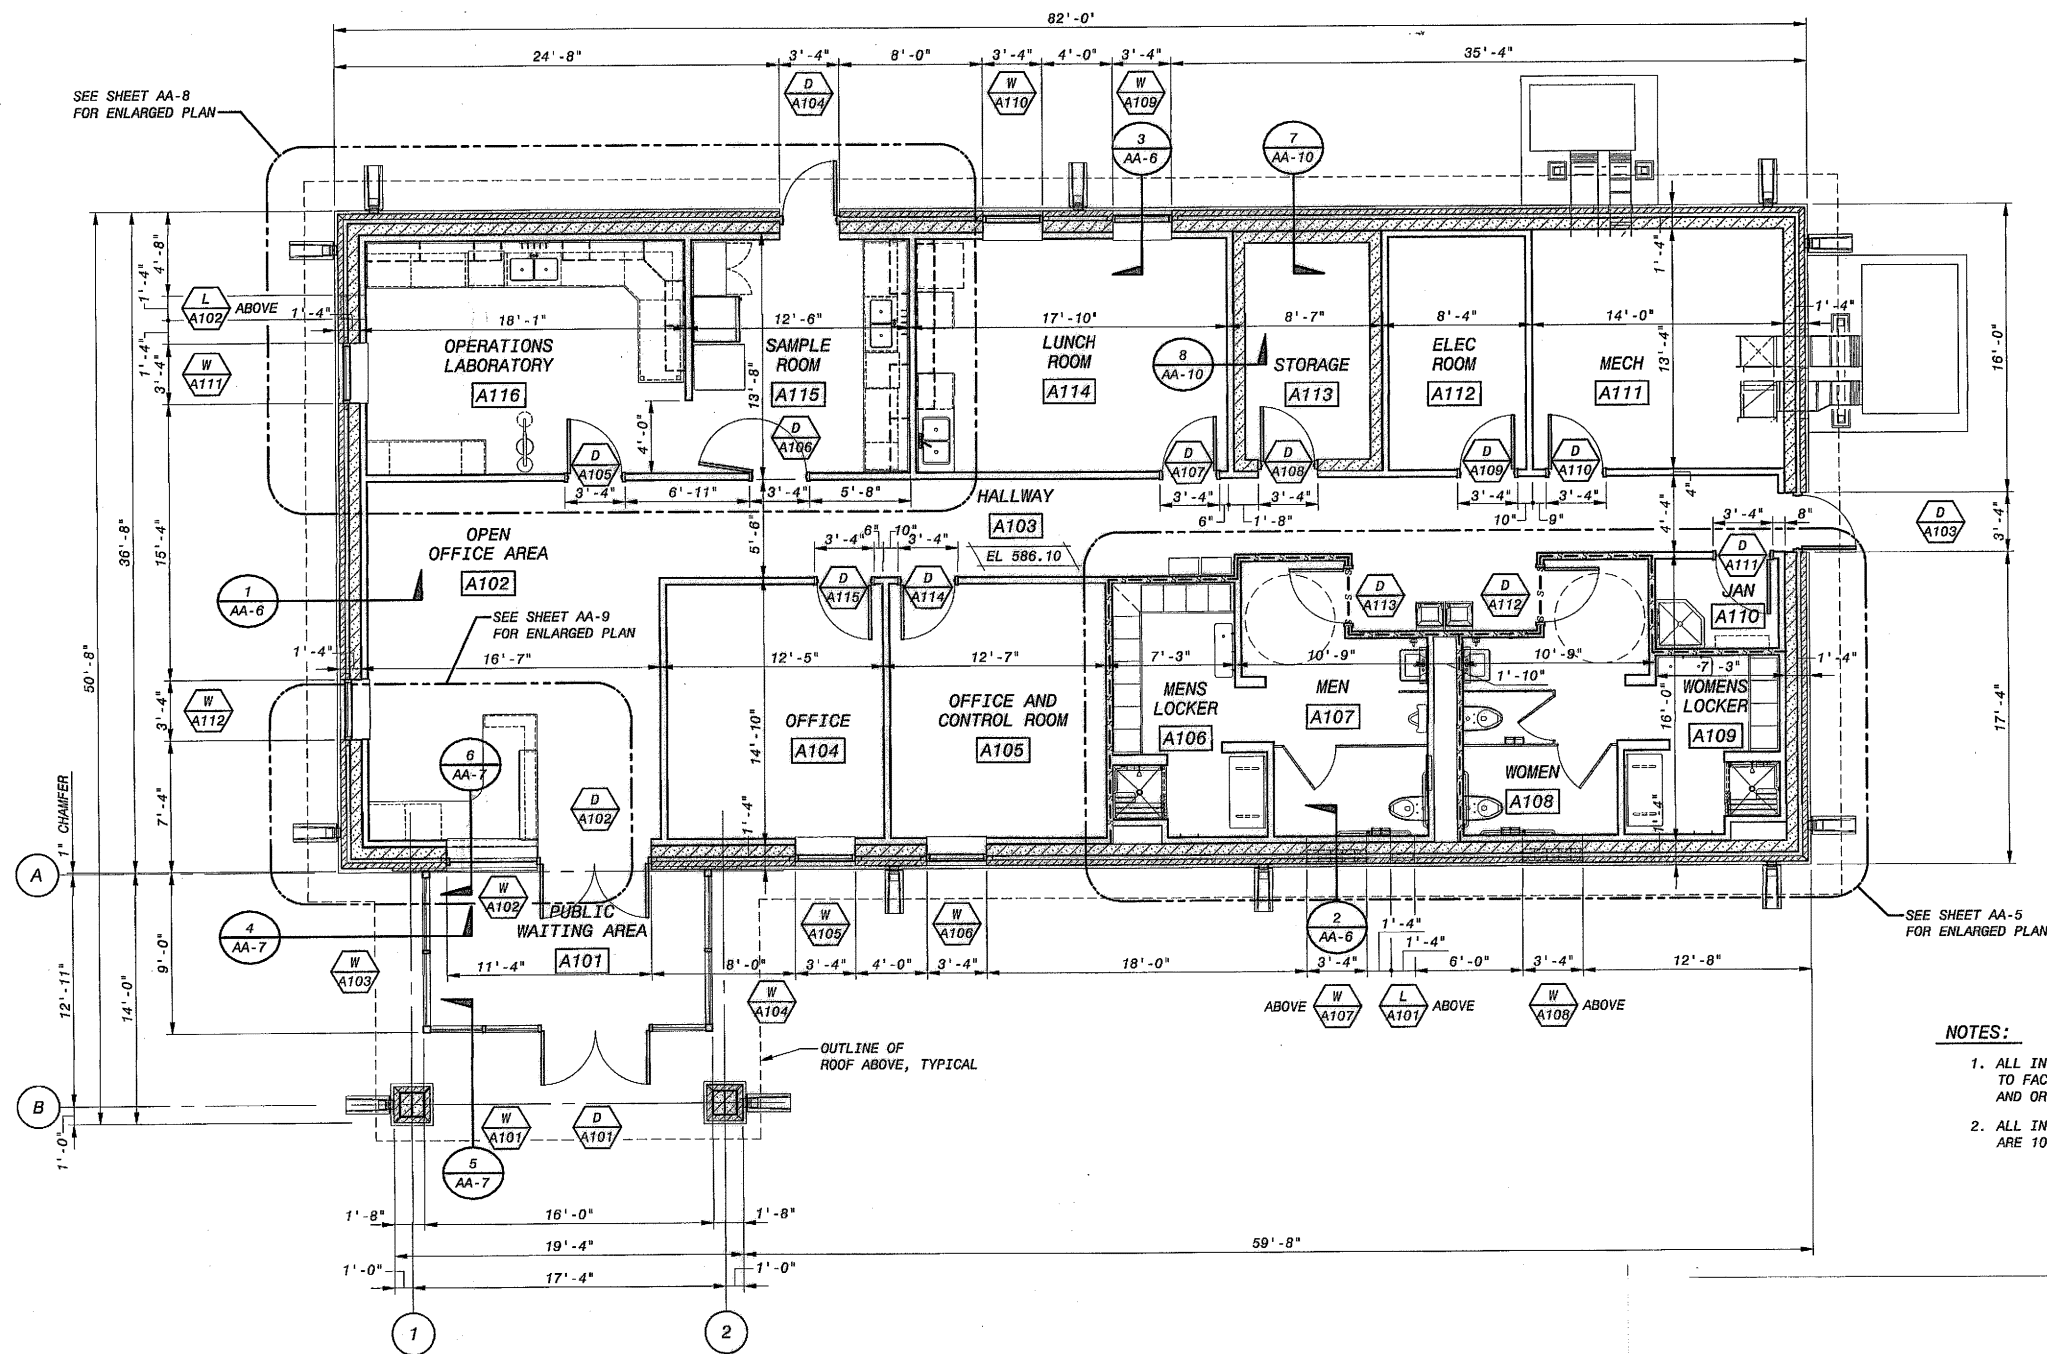


NOTES:

 1. ALL INTERIOR DIMENSIONS ARE TO FACE OF METAL STUDS AND OR MASONRY
2. ALL INTERIOR STUD WALL HEIGHTS ARE 10'-0" UNLESS NOTED OTHERWISE




FLOOR PLAN
3/16" = 1'-0"

LOWER BIRD CREEK WWTP EXPANSION TMUA PROJECT NO. ES 2006-01 CONTRACT 1B			
OPERATIONS BUILDING ARCHITECTURAL FLOOR PLAN			
CITY OF TULSA, OKLAHOMA TULSA METROPOLITAN UTILITY AUTHORITY ENGINEERING SERVICES DEPARTMENT			
PLANS AND ESTIMATES PREPARED BY:			
BLACK & VEATCH Building a world of difference		Holloway, Updeave and Dalton Consulting Engineers Muskegon - Tucson - Aurora	
Black & Veatch Corporation Kansas City, Missouri			
PLAN SCALE: DRAWN: MDE DESIGNED: PDR SURVEY:	PROFILE SCALE: FIELD MGR. 708 10/11 SECT. MGR. PROJ. MGR. 264 10/11 RECOMMENDED:	APPROVED: 	
HORIZONTAL: 1" =	VERTICAL: 1" =	FILE: AA-02 DRAWING: AA-2 ATLAS PAGE NO:	DATE 10/28/2011 SHEET 168 OF 261 SHEETS

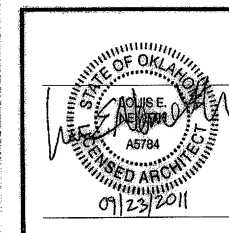


REVISION	BY	DATE

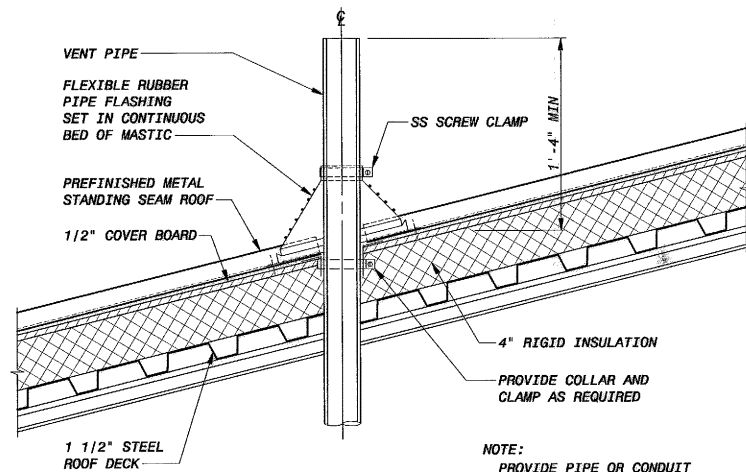


DETAIL
1 1/2" = 1'-0"

NOTE:
PROVIDE PIPE OR CONDUIT SUPPORT BELOW ROOF DECK WHEN UNSUPPORTED LENGTH BELOW ROOF EXCEEDS 5'-0"

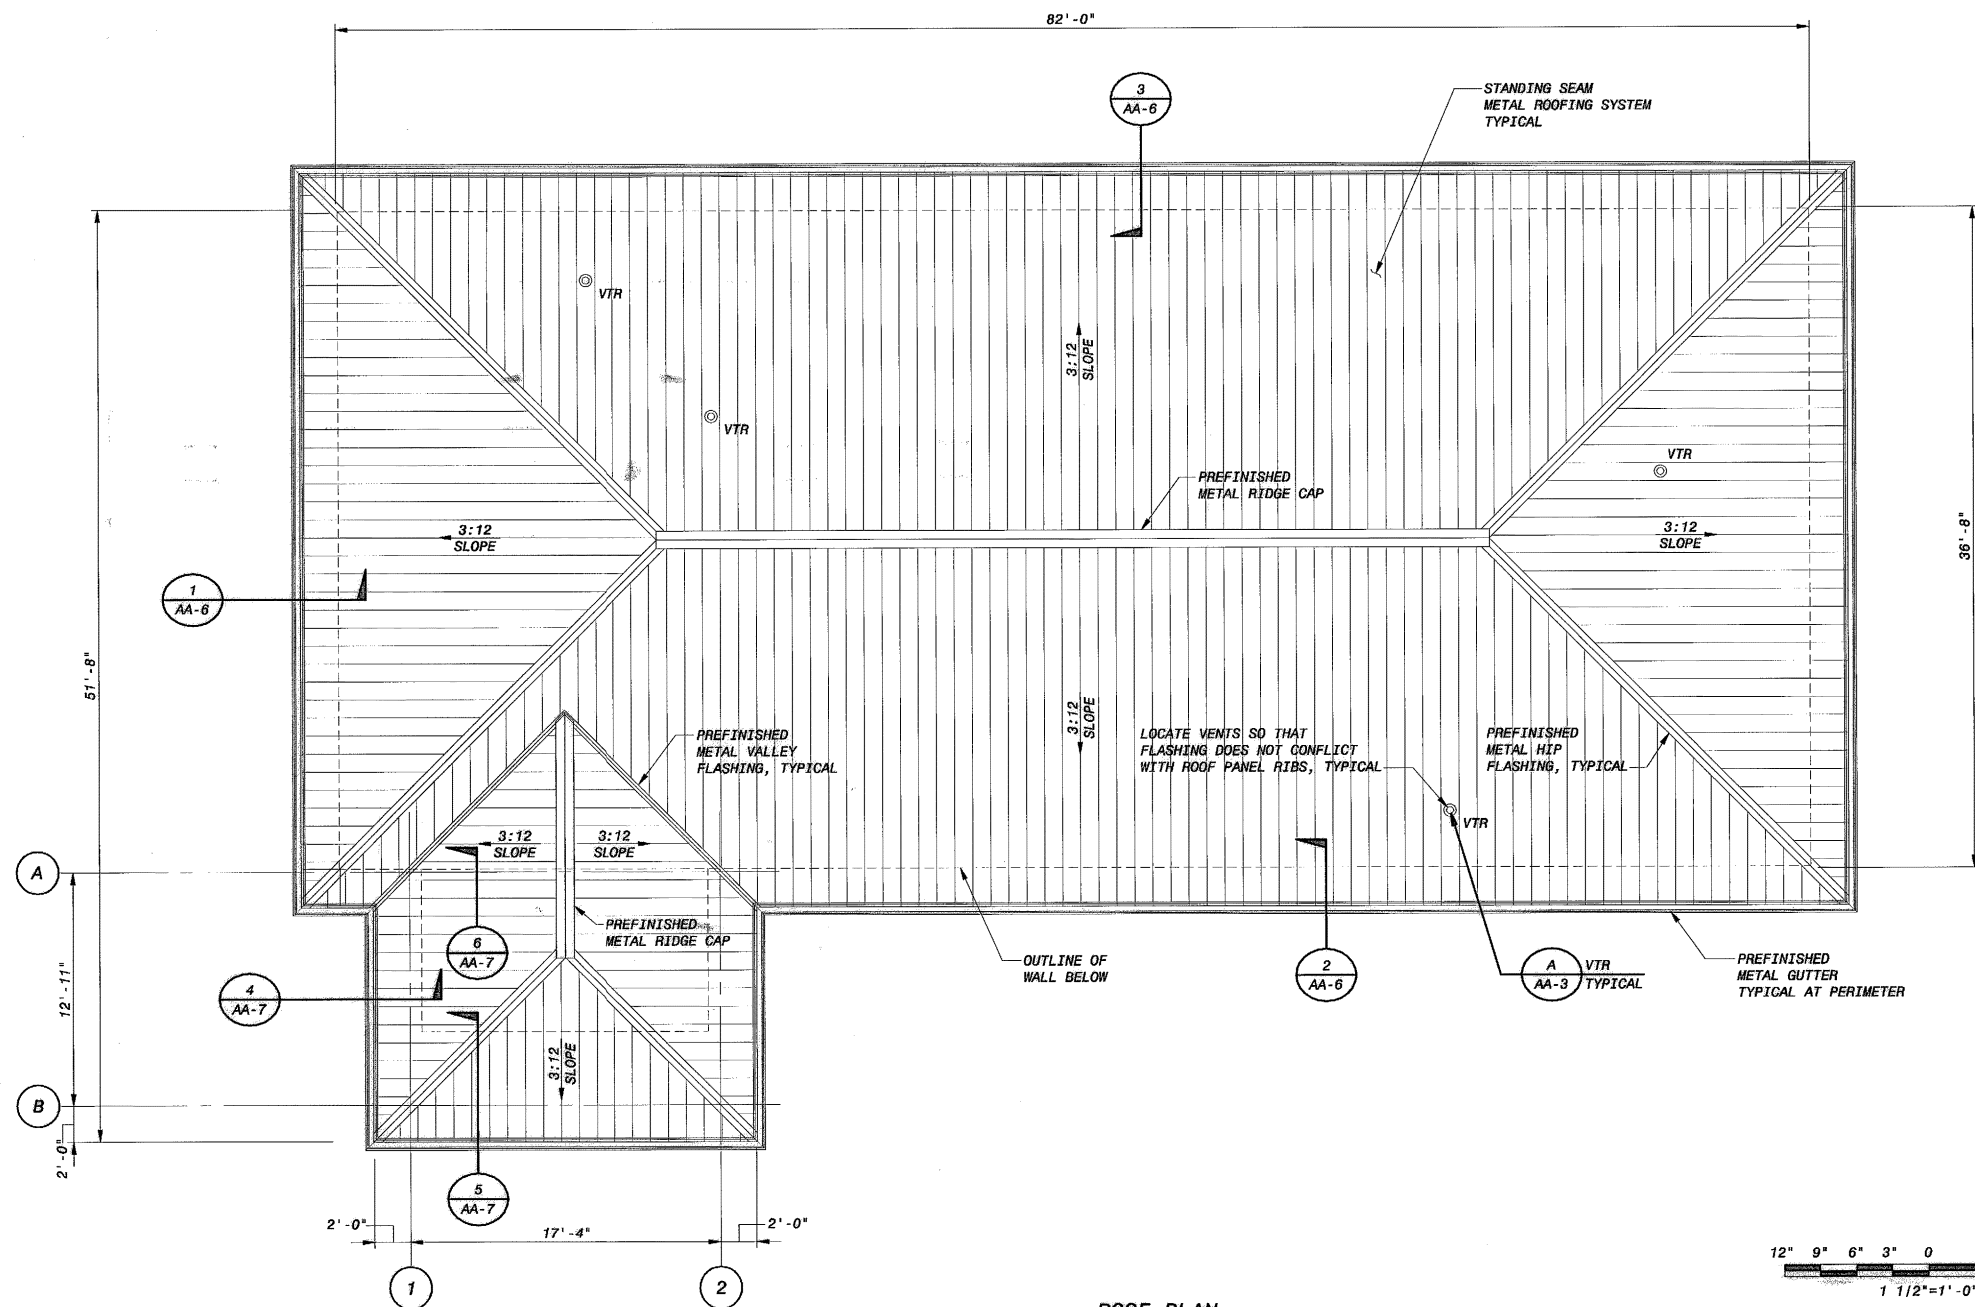

ROOF PLAN
3/16" = 1'-0"

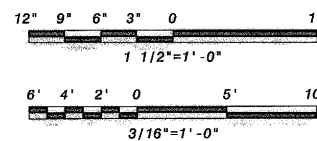

LOWER BIRD CREEK WWTP EXPANSION
TMUA PROJECT NO. ES 2006-01
CONTRACT 1B

OPERATIONS BUILDING
ARCHITECTURAL
ROOF PLAN

CITY OF TULSA, OKLAHOMA
TULSA METROPOLITAN UTILITY AUTHORITY
ENGINEERING SERVICES DEPARTMENT

PLANS AND ESTIMATES PREPARED BY:



REVISION	BY	DATE	PLAN SCALE:	DRAWN	TMB	APPROVED:
				DESIGNED	PDR	
				SURVEY		
			PROFILE SCALE:	FIELD MGR.	708 10/11	
			HORIZONTAL:	SECT. MGR.		
			1" =	PROJ. MGR.	26W 11/11	
			VERTICAL	RECOMMENDED:		
			1" =			
			FILE: AA-03	DRAWING: AA-3		
			ATLAS PAGE NO:			






[Signature]
DIRECTOR


DATE 10/28/2011

SHEET 169 OF 261 SHEETS

388 7-28-11 B&V PROJECT NO. 145120

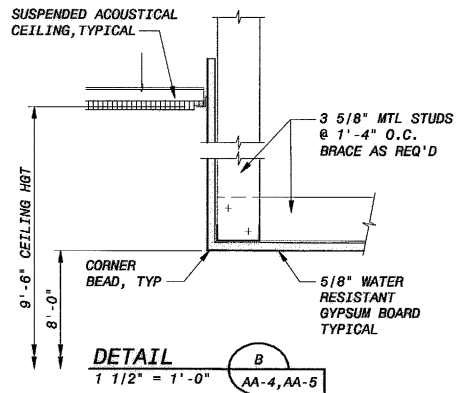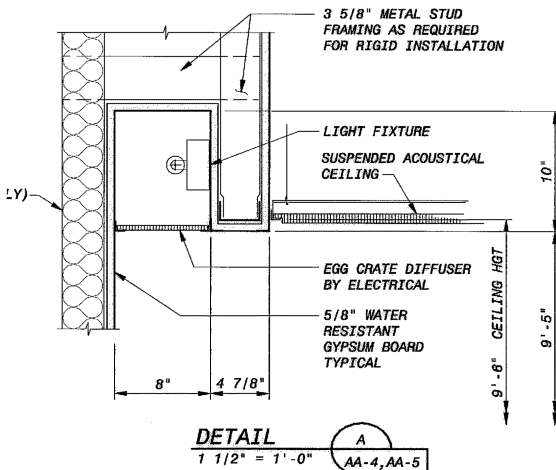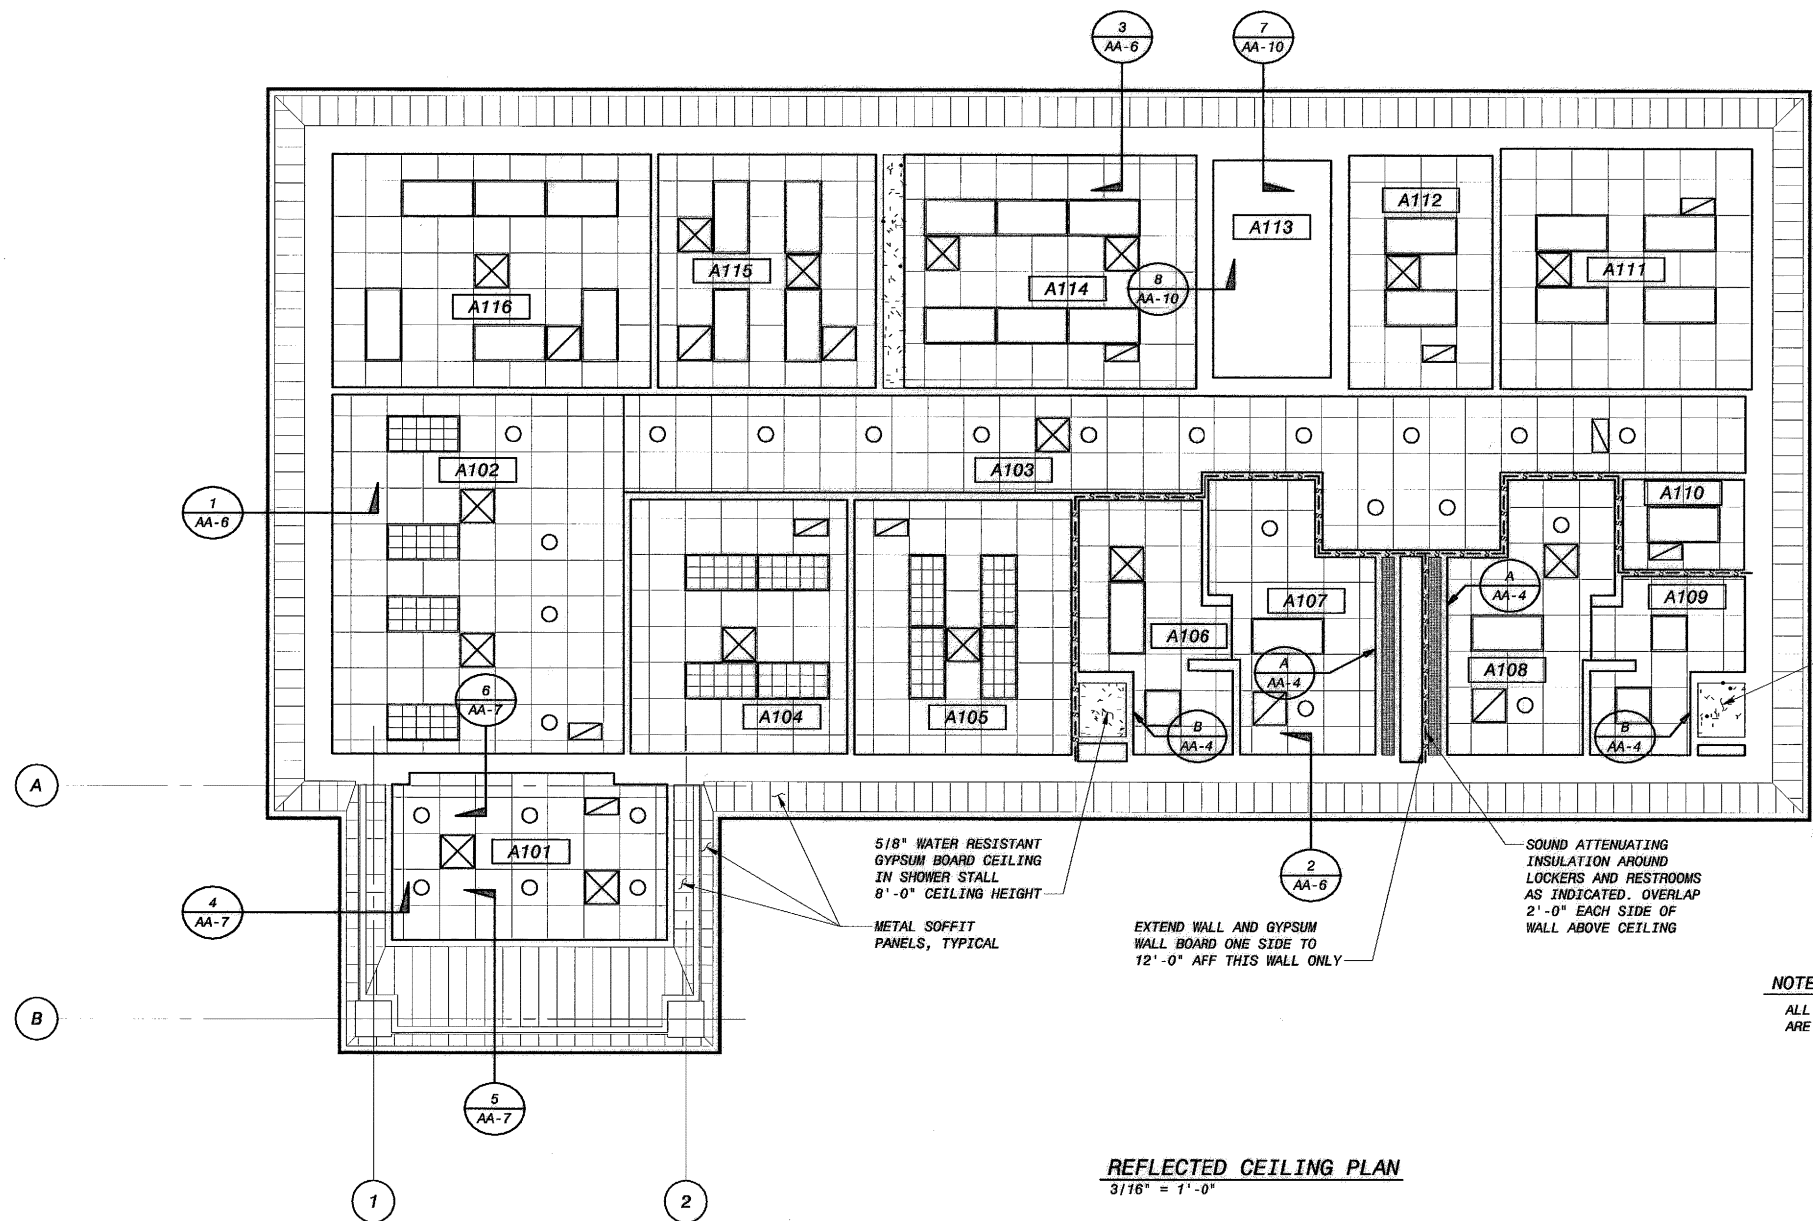

- LEGEND**
- LIGHT FIXTURES
 - EXHAUST DIFFUSER / RETURN DIFFUSER
 - SUPPLY DIFFUSER

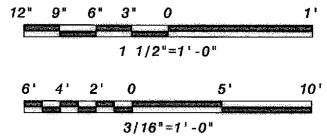

NOTE:
ALL INTERIOR STUD WALL HEIGHTS
ARE 10'-0" UNLESS NOTED OTHERWISE


REFLECTED CEILING PLAN
3/16" = 1'-0"

LOWER BIRD CREEK WWTP EXPANSION
TMUA PROJECT NO. ES 2006-01
CONTRACT 1B
OPERATIONS BUILDING
ARCHITECTURAL
REFLECTED CEILING PLAN AND DETAILS
CITY OF TULSA, OKLAHOMA
TULSA METROPOLITAN UTILITY AUTHORITY
ENGINEERING SERVICES DEPARTMENT




PLANS AND ESTIMATES PREPARED BY:

Black & Veatch Corporation
Kansas City, Missouri

REVISION		BY	DATE	APPROVED:

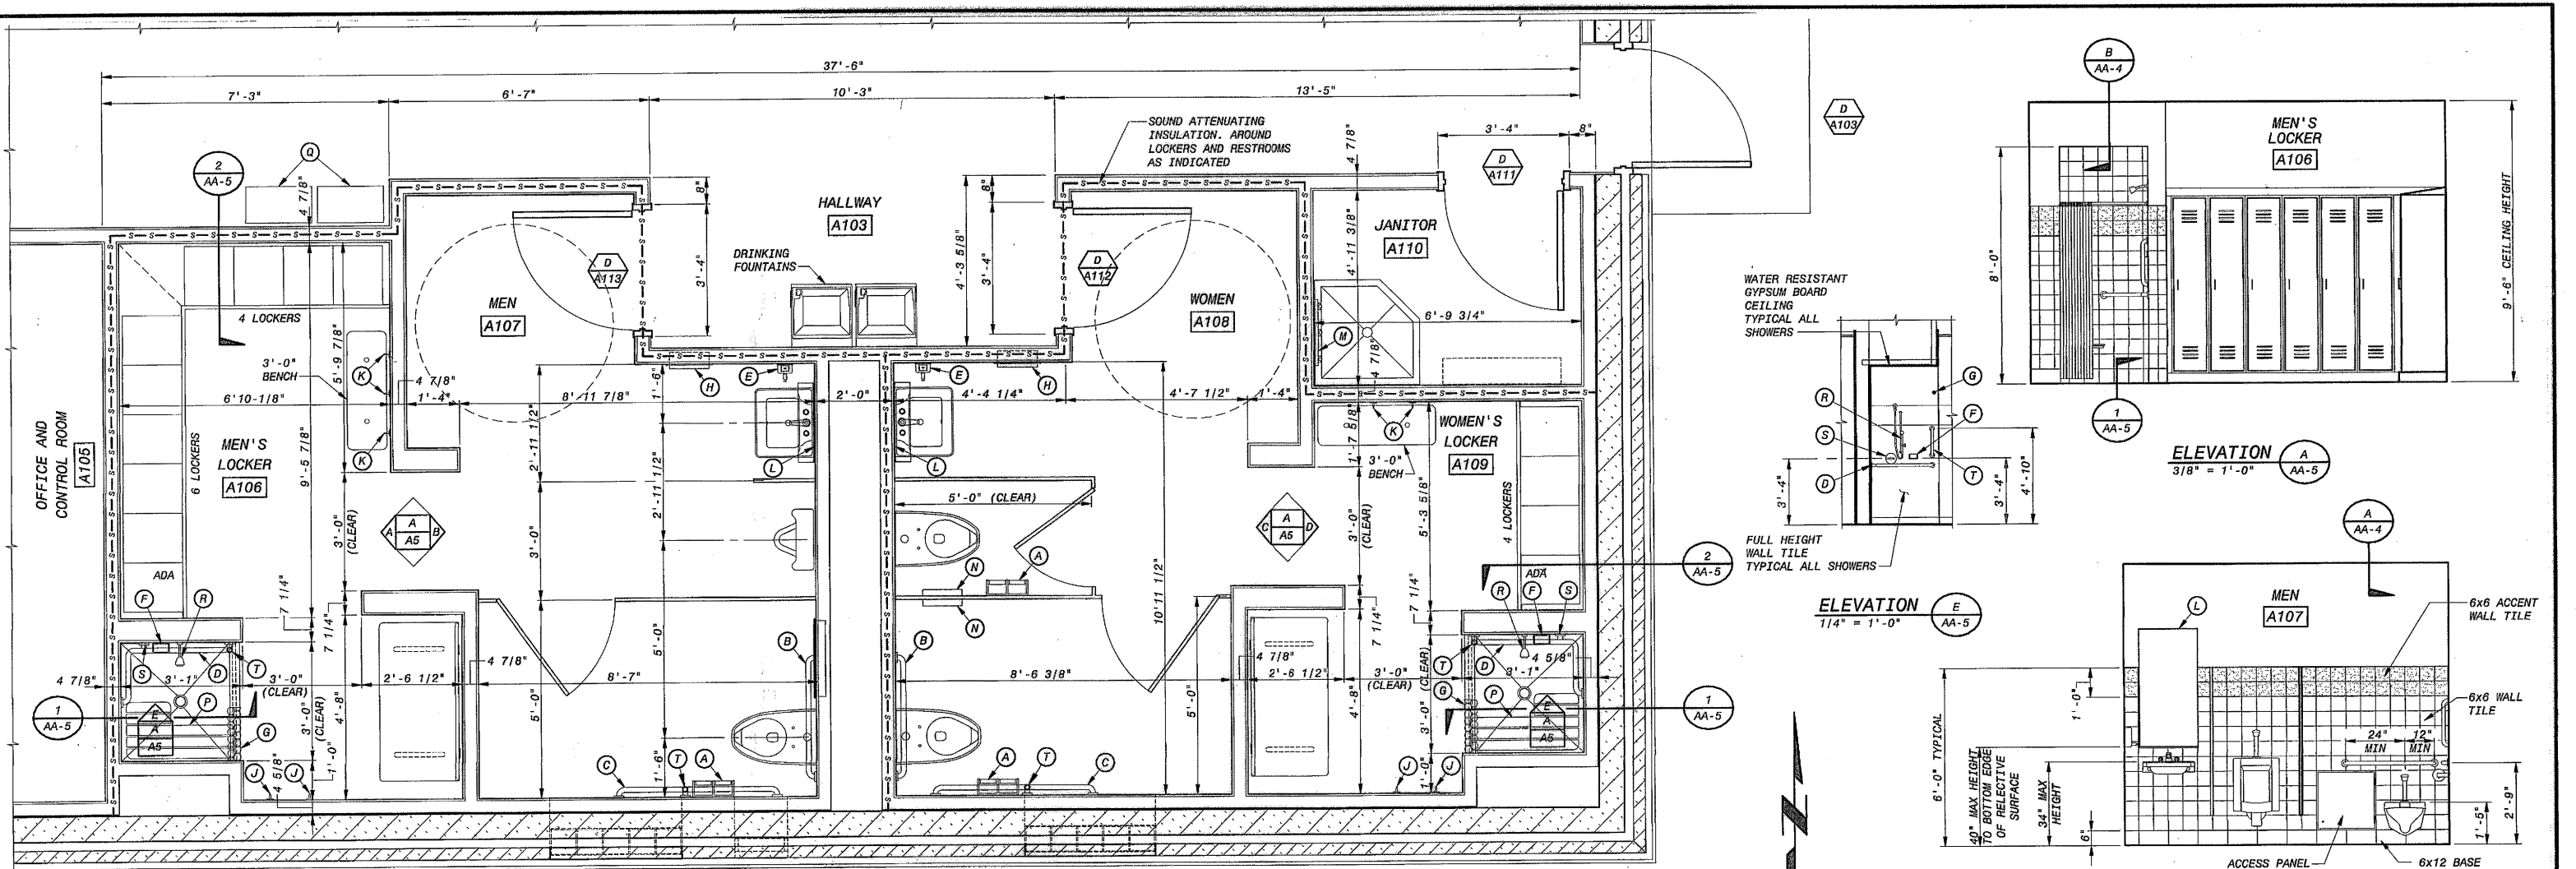

ACCESSORY SCHEDULE			
QTY	ID	ITEM	MOUNTING HEIGHT
3	A	SURFACE MOUNTED TOILET PAPER HOLDER	2'-4"
2	B	36" GRAB BAR	CL 2'-9"
2	C	48" GRAB BAR	CL 2'-9"
2	D	TWO-WALL GRAB BAR	CL 2'-9"
2	E	AUTOMATIC SOAP DISPENSER	3'-4" TO BOTTOM
2	F	SURFACE MOUNTED SOAP HOLDER	3'-4" TO BOTTOM
2	G	SHOWER CURTAIN, HOOKS AND ROD	6'-6" AFF
2	H	AUTOMATIC ROLL PAPER TOWEL DISPENSER AND WASTE RECEPTACLE	4'-0" AFF TO BOTTOM OF UNIT
4	J	TOWEL PIN (ONE ADA AT EACH SHOWER)	5'-0" AFF
4	K	HAT AND COAT HOOK	4'-0" AFF ADA
5	L	FRAMED MIRROR 24" x 48"	5'-0" AFF
2	M	24" MOP AND BROOM HOLDER	3'-4" TO BOTTOM OF REFLECTIVE SURFACE
2	N	PARTITION MOUNTED SANITARY NAPKIN DISPENSER	6'-0" AFF
2	P	SHOWER SEAT	2'-6" AFF
2	Q	WASTE AND RECYCLE RECEPTACLES	18" AFF
2	R	ADA HAND SHOWER W/ SLIDE BAR	3'-8" TO BOTTOM OF SLIDE BAR
2	S	SHOWER VALVE	CL 3'-4" AFF
4	T	18" VERTICAL GRAB BAR	CL 4'-10" AFF

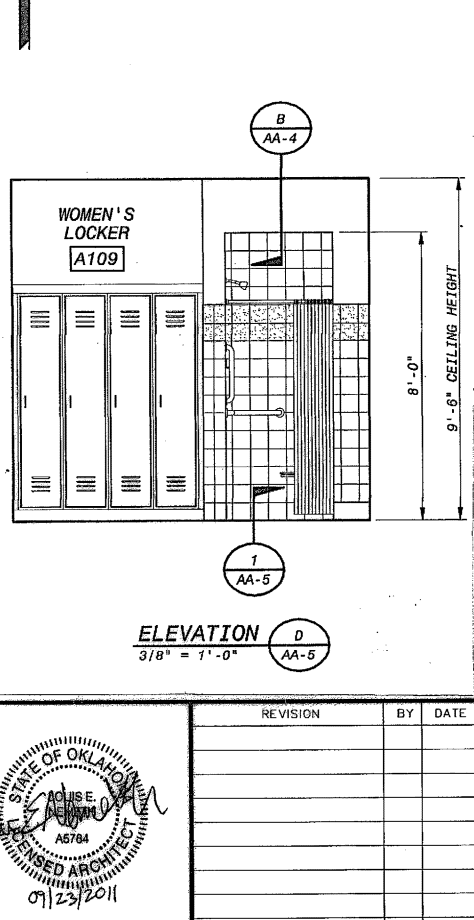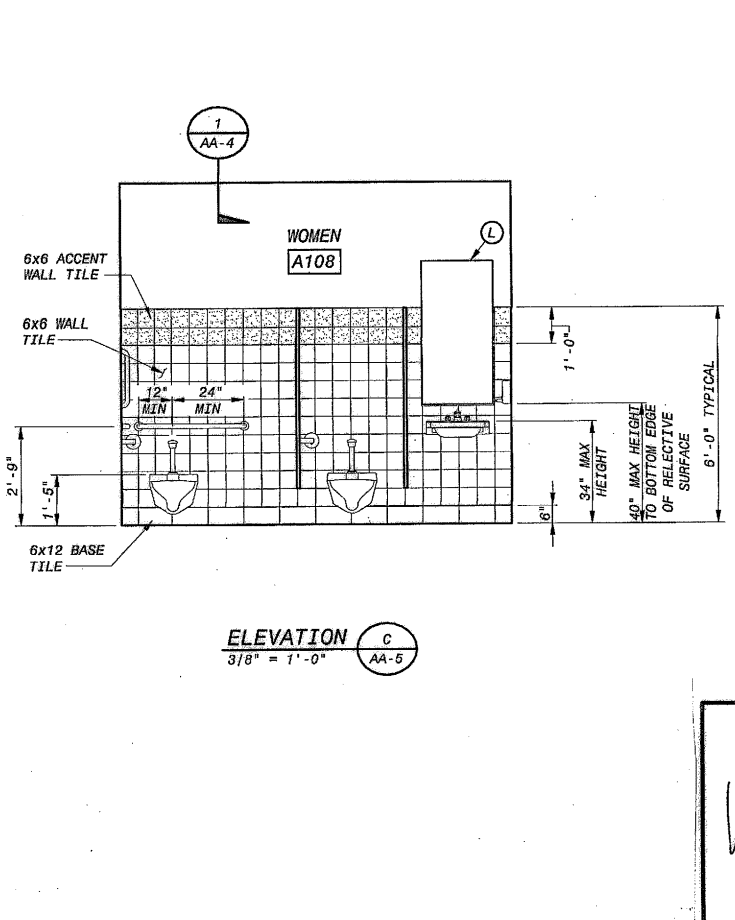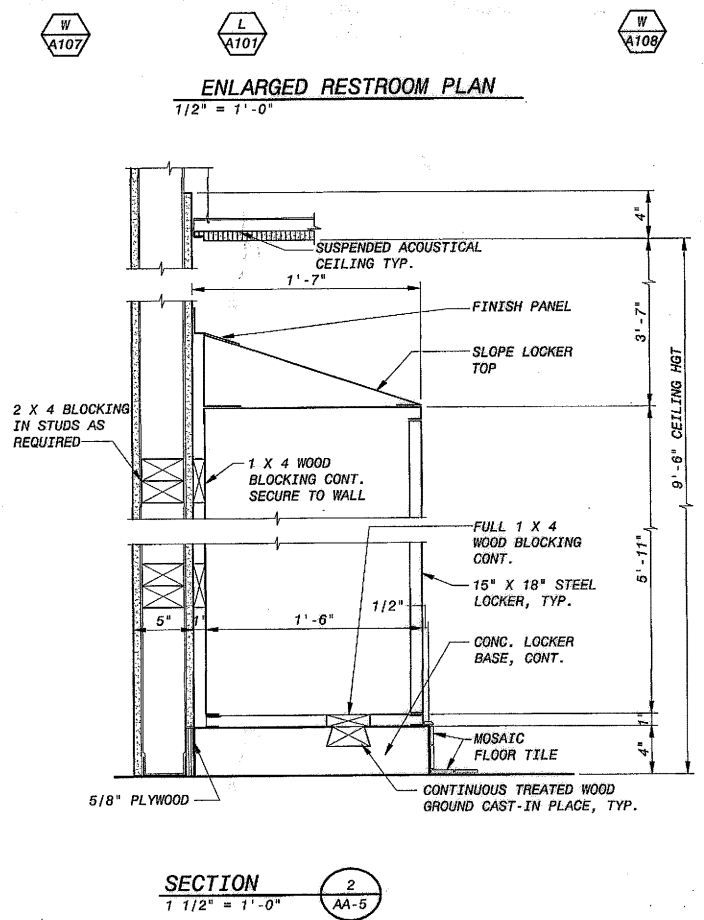

ELEVATION A
3/8" = 1'-0"

ELEVATION B
3/8" = 1'-0"

ELEVATION C
3/8" = 1'-0"

ELEVATION D
3/8" = 1'-0"

ELEVATION E
1/4" = 1'-0"

SECTION 1
1 1/2" = 1'-0"

SECTION 2
1 1/2" = 1'-0"

LOWER BIRD CREEK WWTW EXPANSION
TMUA PROJECT NO. ES 2006-01
CONTRACT 1B

OPERATIONS BUILDING
ARCHITECTURAL
ENLARGED RESTROOM AND LOCKER ROOM

CITY OF TULSA, OKLAHOMA
TULSA METROPOLITAN UTILITY AUTHORITY
ENGINEERING SERVICES DEPARTMENT

PLANS AND ESTIMATES PREPARED BY:

BLACK & VEATCH
Building a world of difference

Black & Veatch Corporation
Kansas City, Missouri

PLANNED BY: **BLACK & VEATCH**

DESIGNED BY: **MDE**

SURVEY BY: **PDR**

FIELD MGR. BY: **708 10/11**

SECT. MGR. BY: **201 10/11**

PROJ. MGR. BY: **201 10/11**


RECOMMENDED BY: **HAS 10/20/11**

FILE: AA-05 DRAWING: AA-5 DATE 10/25/2011


ATLAS PAGE NO: SHEET 171 OF 261 SHEETS

B&V PROJECT NO. 145120


PLOTTED DATE: EDM7043, 9/21/2011, 8:33:19 AM
 SAVED DATE: EDM7043, 9/20/2011, 2:08:17 PM
 C:\NET\10-145120-3000-A-00005.MXD

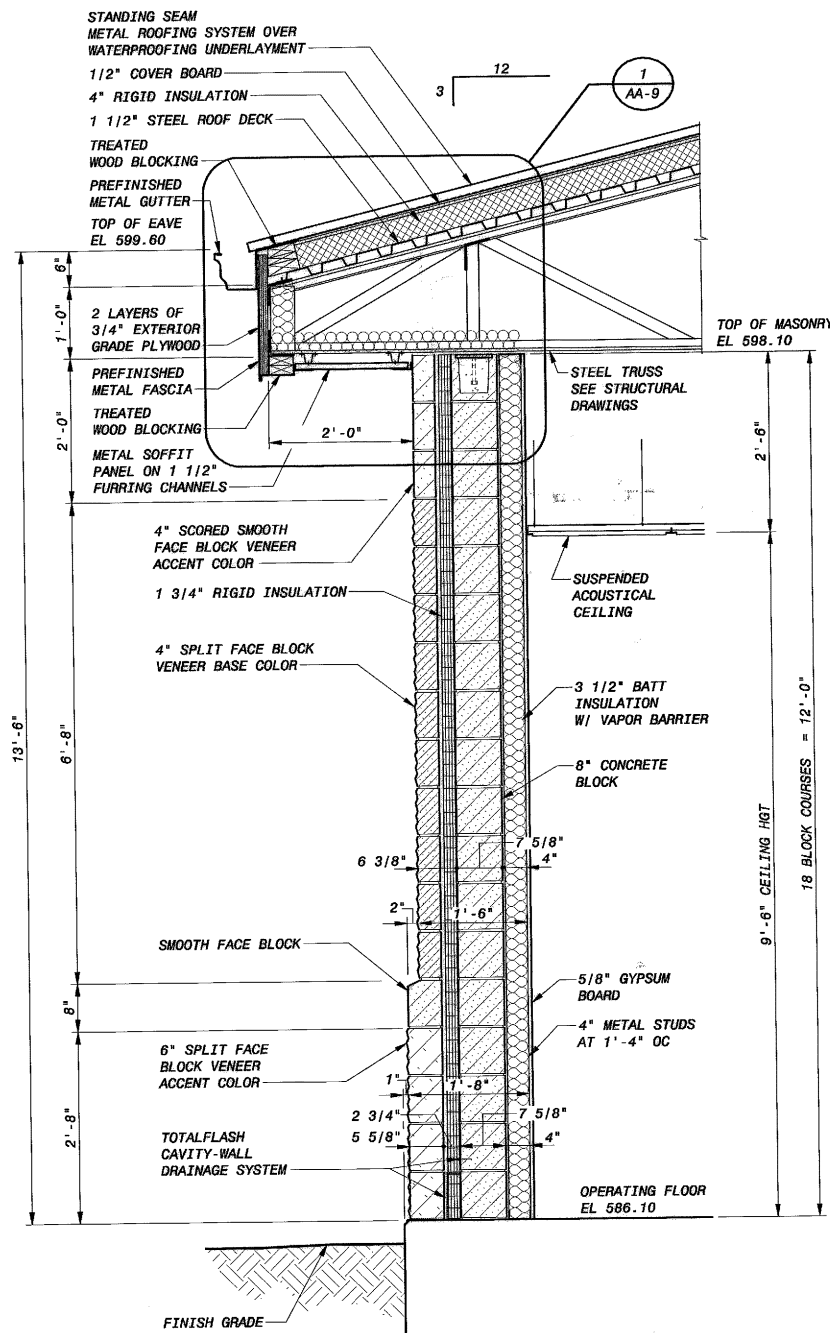

SECTION 1
3/4" = 1'-0"


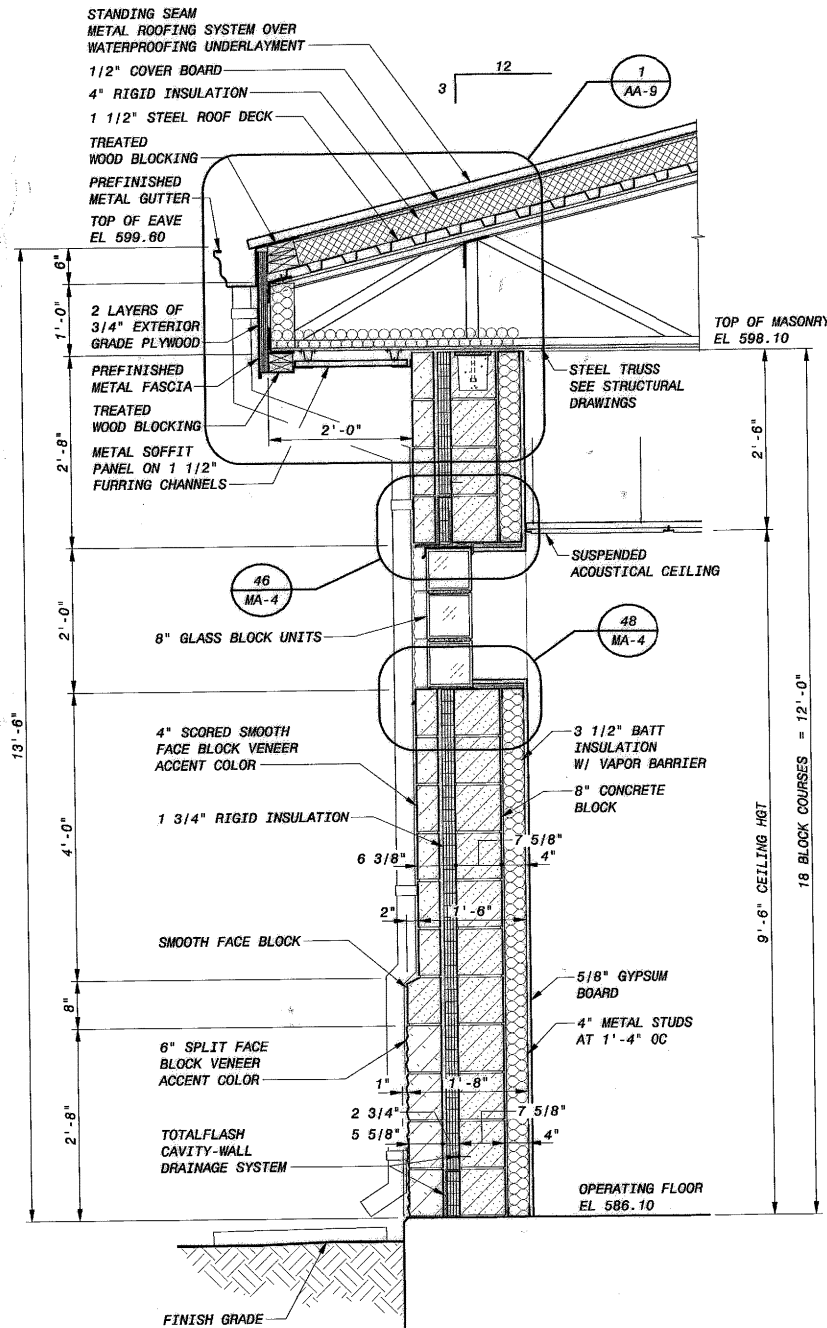


SECTION 2
3/4" = 1'-0"

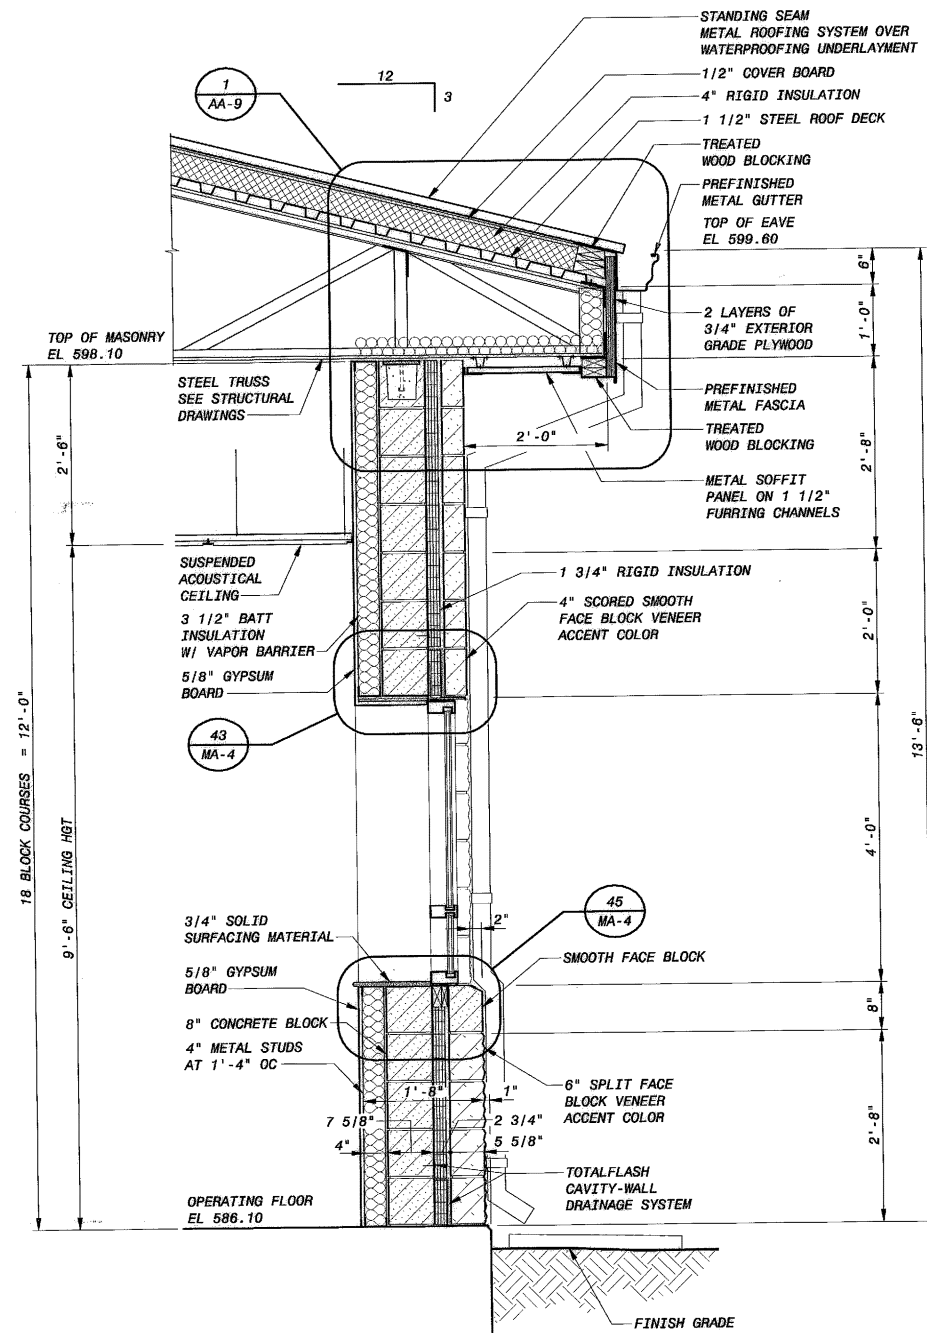


SECTION 3
3/4" = 1'-0"

 - NOTES:**
1. FOR VERTICAL REINFORCING, BOND BEAM LOCATIONS AND WALL PENETRATIONS, SEE STRUCTURAL DRAWINGS
 2. SEE SPECIFICATION SECTION 04200 BUILDING MASONRY FOR HORIZONTAL JOINT REINFORCING

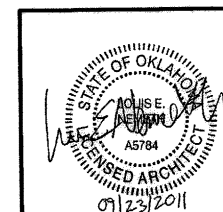


REVISION	BY	DATE	PLAN SCALE:	DRAWN	MDE	APPROVED:
			DESIGNED	PDR		
			SURVEY			
			PROFILE SCALE:	FIELD MGR.	7/28/10/11	
			HORIZONTAL:	SECT. MGR.	10/3/11	
			VERTICAL:	PROJ. MGR.	10/3/11	
			RECOMMENDED:	HAS	10/30/11	
			FILE: AA-06	DRAWING: AA-6	DATE 10/26/2011	
			ATLAS PAGE NO:			

LOWER BIRD CREEK WWTP EXPANSION
TMUA PROJECT NO. ES 2006-01
CONTRACT 1B
OPERATIONS BUILDING
ARCHITECTURAL
WALL SECTIONS
CITY OF TULSA, OKLAHOMA
TULSA METROPOLITAN UTILITY AUTHORITY
ENGINEERING SERVICES DEPARTMENT
 PLANS AND ESTIMATES PREPARED BY:
BLACK & VEATCH
 Building a world of difference
 Black & Veatch Corporation
 Kansas City, Missouri
 07/23/2011
 SHEET 172 OF 261 SHEETS
 B&V PROJECT NO. 145120

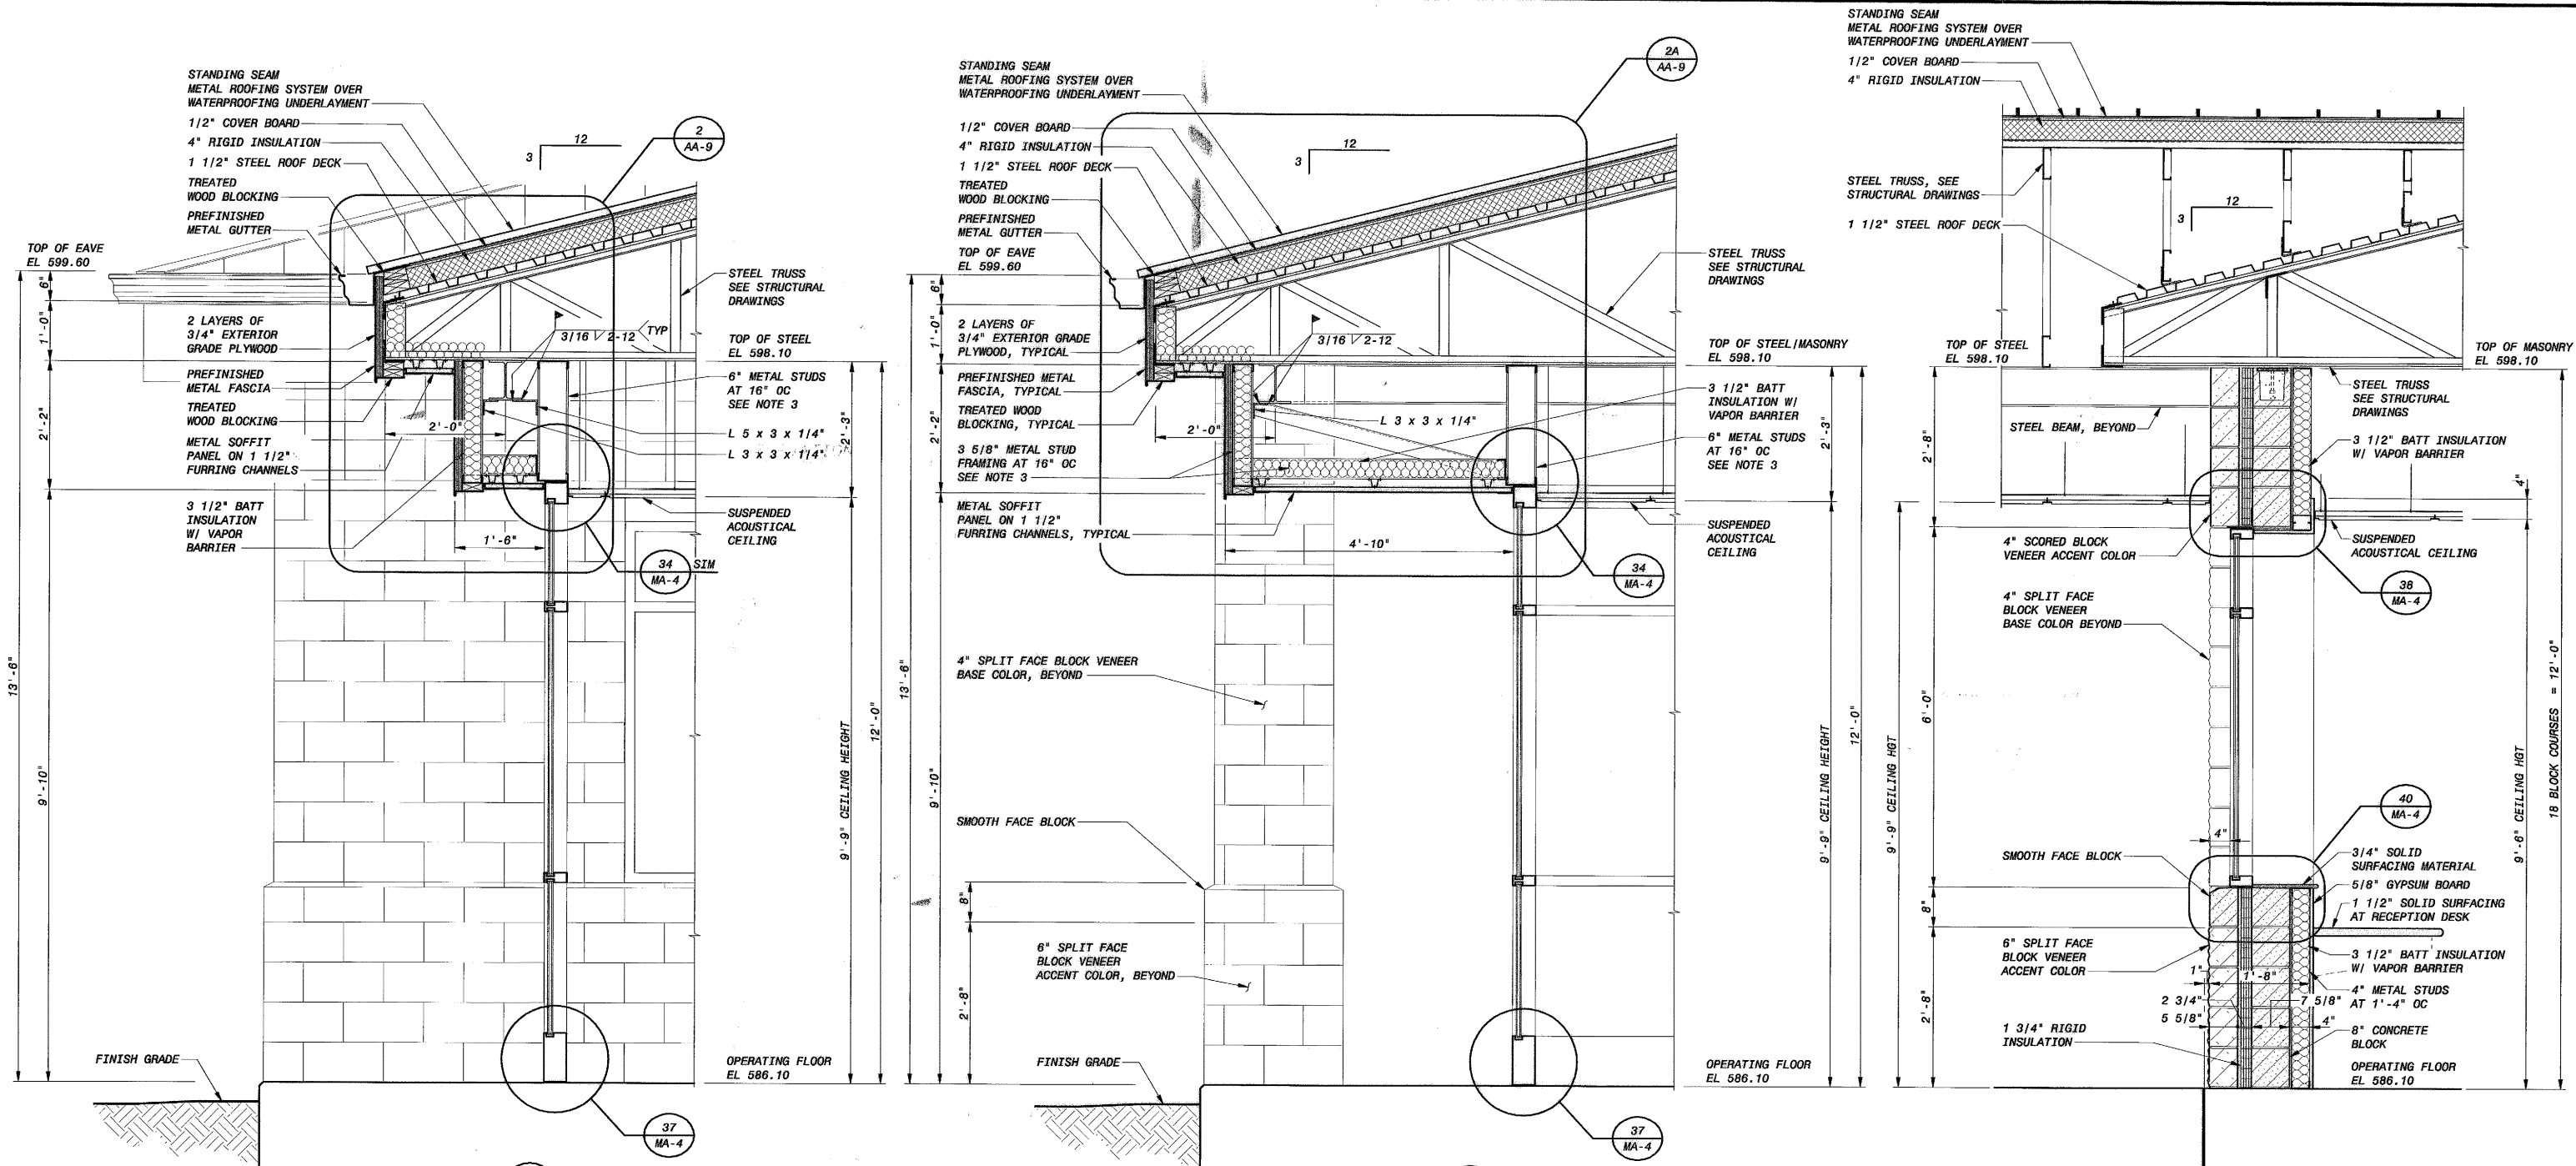

- NOTES:
1. FOR BOND BEAMS AND WALL REINFORCING, SEE STRUCTURAL DRAWINGS
 2. SEE SPECIFICATION SECTION 04200 BUILDING MASONRY FOR HORIZONTAL JOINT REINFORCING
 3. CONTRACTOR SHALL DESIGN LIGHT GAUGE FRAMING PER SECTION 05400

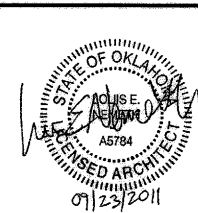

REVISION	BY	DATE

SECTION 6
3/4" = 1'-0"

AA-2, AA-3, AA-4, AA-9

LOWER BIRD CREEK WWTP EXPANSION
TMUA PROJECT NO. ES 2006-01
CONTRACT 1B

OPERATIONS BUILDING
ARCHITECTURAL
WALL SECTIONS

CITY OF TULSA, OKLAHOMA
TULSA METROPOLITAN UTILITY AUTHORITY
ENGINEERING SERVICES DEPARTMENT

PLANS AND ESTIMATES PREPARED BY:

BLACK & VEATCH
Building a world of difference


Black & Veatch Corporation
Kansas City, Missouri

Holloway, Updeave and Ballen
Consulting Engineers
Muskogee - Broken Arrow


OWGATES
Engineering Services

PLAN SCALE:	DRAWN	MDE	APPROVED:
	DESIGNED	PDR	
	SURVEY		
PROFILE SCALE:	FIELD MGR.	7/28 10/11	
	SECT. MGR.		
HORIZONTAL:	PROJ. MGR.	2/24 10/11	
	RECOMMENDED:		
VERTICAL:		1/24 10/11	
FILE: AA-07	DRAWING: AA-7	DATE 10/28/2011	
ATLAS PAGE NO:		SHEET 173 OF 261 SHEETS	


PLOTTED DATE: EDM17043, 6/16/2011 8:38:29 AM
 SAVED DATE: EDM17043, 9/20/2011 2:09:45 PM
 CYGNET ID: 145120-3000-A-8000SWP

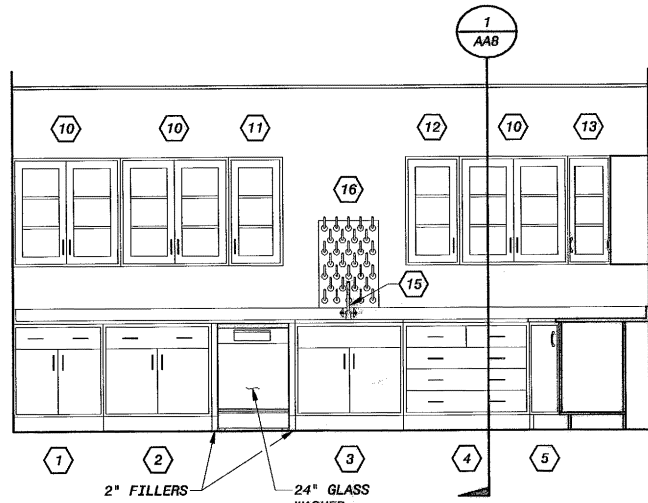


ELEVATION
3/8" = 1'-0"

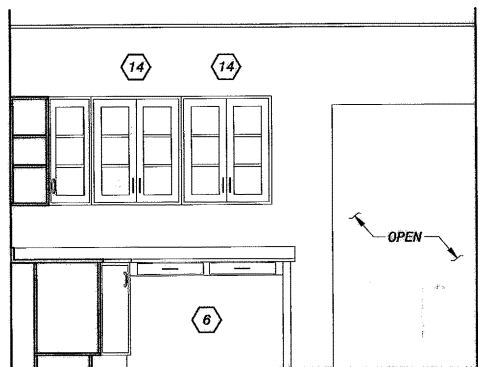


ELEVATION
3/8" = 1'-0"

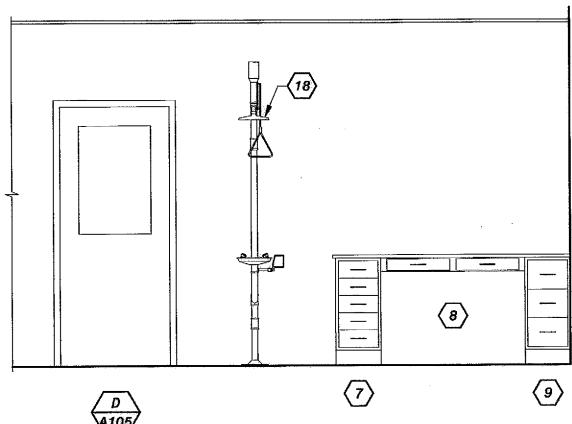


ELEVATION
3/8" = 1'-0"

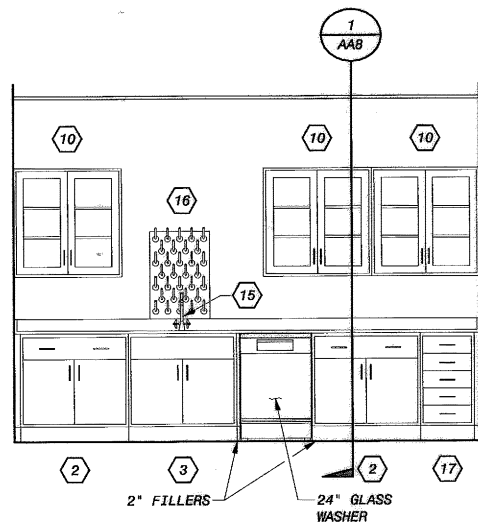


ELEVATION
3/8" = 1'-0"

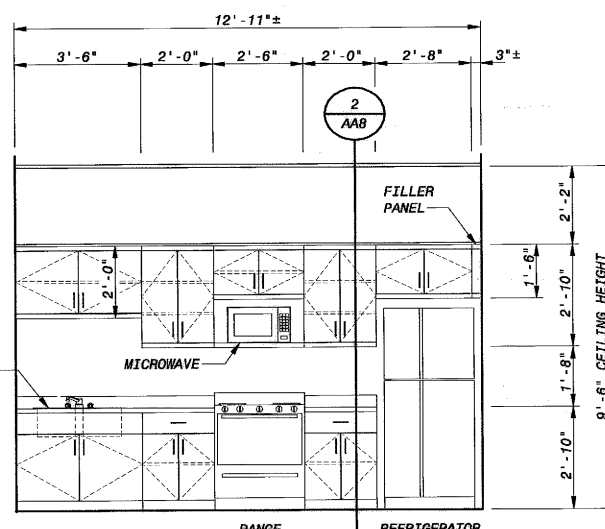


ELEVATION
3/8" = 1'-0"

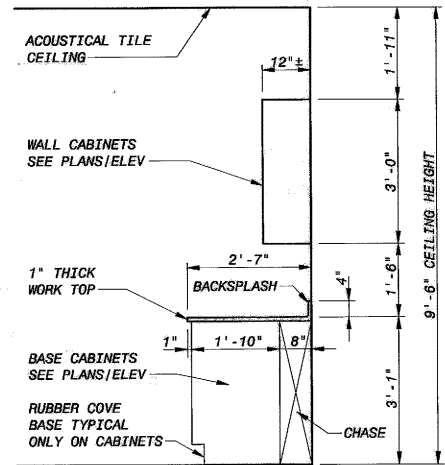

SECTION
1/2" = 1'-0"


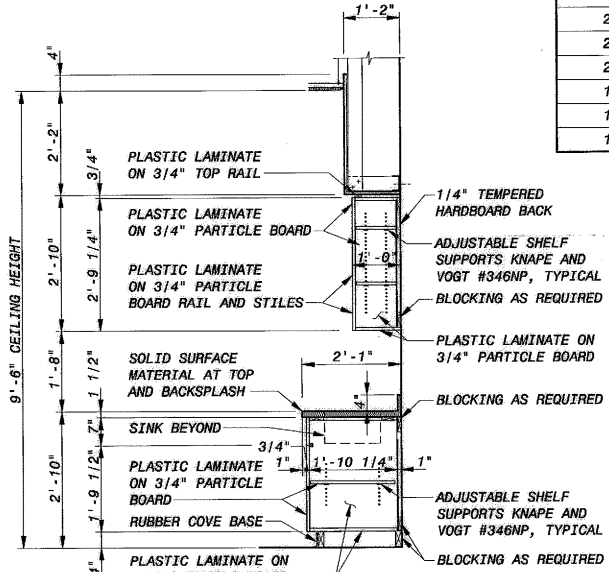


SECTION
1/2" = 1'-0"

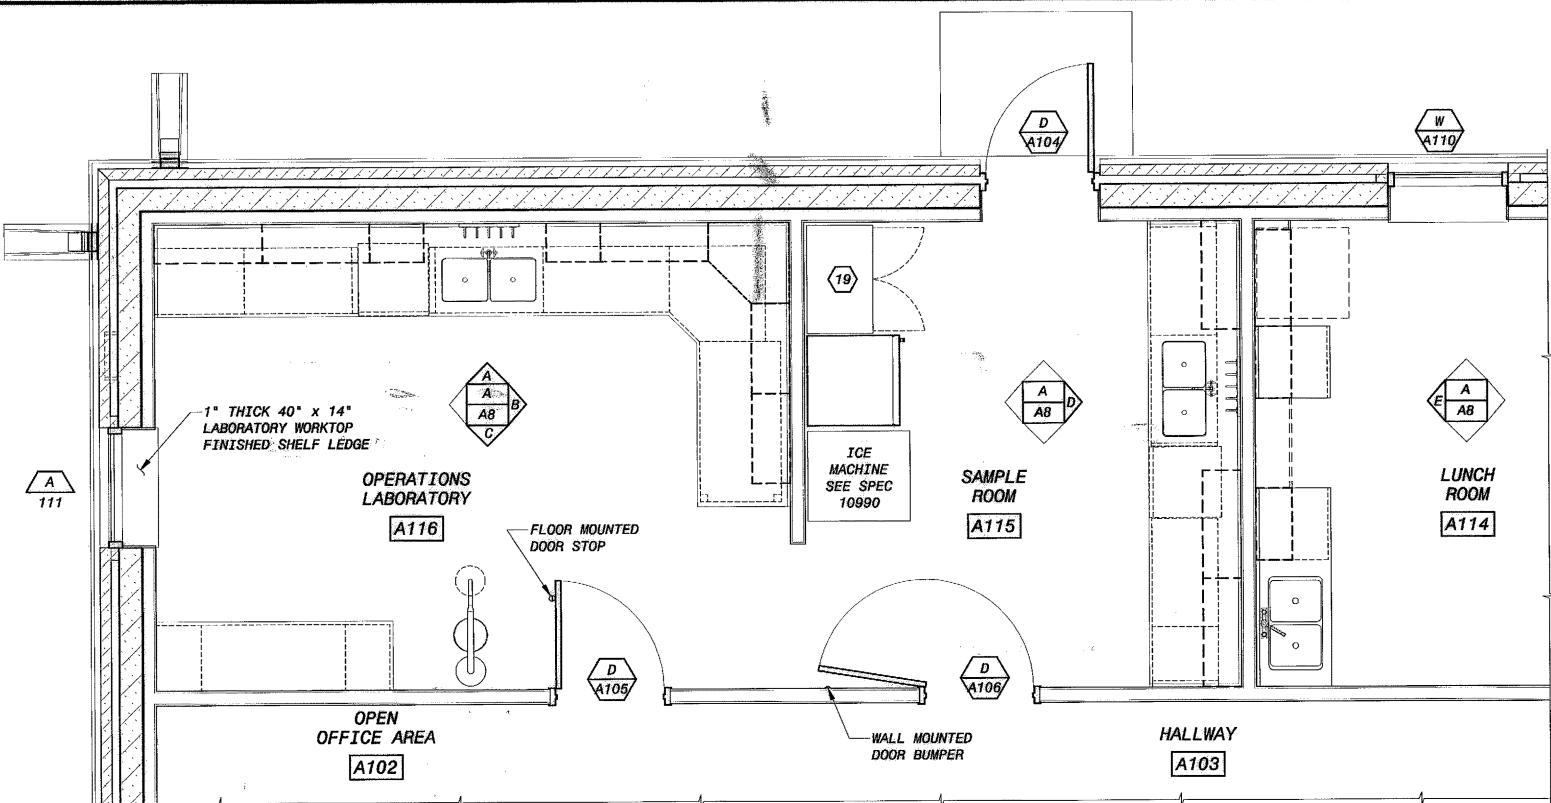

ENLARGED LABORATORY PLAN
3/8" = 1'-0"

LABORATORY CABINET SCHEDULE					
Quantity	CAB No.	MFR	MODEL No.	DESCRIPTION	REMARKS
1	1	KEWAUNEE	E41W362230-5212	CUPBOARD AND DRAWER CABINET	
3	2	KEWAUNEE	E41W362236-5212	CUPBOARD AND DRAWER CABINET	
2	3	KEWAUNEE	G00W362236-5212	SINK CABINET	
1	4	KEWAUNEE	D31W362242-5212	DRAWER CABINET	
1	5	KEWAUNEE	G14W362215-5212	DIAGONAL CORNER CABINET	NO LAZY SUSAN
1	6	KEWAUNEE	A18W052854-5012	APRON	WITH LEG ASSEMBLY (A21W3628-0010)
1	7	KEWAUNEE	D50W362215-5012	DRAWER CABINET	
1	8	KEWAUNEE	A02W052248-5012	APRON	
1	9	KEWAUNEE	D00W362215-5012	DRAWER CABINET	
6	10	KEWAUNEE	W20W361236-5212	WALL MOUNTED STORAGE CABINET	
1	11	KEWAUNEE	W20W361218-5212	WALL MOUNTED STORAGE CABINET	
1	12	KEWAUNEE	W20W361218L-5212	WALL MOUNTED STORAGE CABINET	
1	13	KEWAUNEE	W21W361217-5212	DIAGONAL WALL MOUNTED STORAGE CABINET	
2	14	KEWAUNEE	W20W361230-5212	WALL MOUNTED STORAGE CABINET	
2	15	KEWAUNEE	W-0340-0V	DECK MOUNTED H&C WATER MIXING VACUUM BREAKER GOOSENECK FAUCET	
2	16	KEWAUNEE	X-020014	COMPOSITE RESIN LABORATORY PEGBOARD	20" X 30" WITH DRIP TROUGH
1	17	KEWAUNEE	D50W362218-5012	DRAWER CABINET	
1	18	KEWAUNEE	W-0936-00	DRENCH SHOWER AND EYE WASH COMBINATION	
1	19	KEWAUNEE	S30W842230	STEEL FULL HEIGHT STORAGE CABINET	

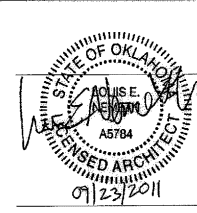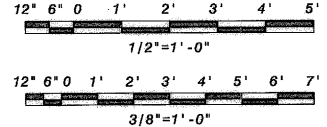

REVISION	BY	DATE	PLAN SCALE:	DRAWN	MDE	APPROVED:
			DESIGNED			
			SURVEY			
			FIELD MGR.			
			SECT. MGR.			
			PROJ. MGR.			
			RECOMMENDED:			
			FILE: AA-08	DRAWING: AA-B		
			ATLAS PAGE NO:			

LOWER BIRD CREEK WWTP EXPANSION
TMUA PROJECT NO. ES 2006-01
CONTRACT 1B

OPERATIONS BUILDING
ARCHITECTURAL
ENLARGED LABORATORY PLAN, SECTS & ELEV

CITY OF TULSA, OKLAHOMA
TULSA METROPOLITAN UTILITY AUTHORITY
ENGINEERING SERVICES DEPARTMENT

 
 
PLANS AND ESTIMATES PREPARED BY:

BLACK & VEATCH
Building a world of difference



Holloway, Updeave and Ballen
Consulting Engineers
Mechanical - Station Avenue


OWGATES
Engineering Services

DATE 10/28/2011
SHEET 174 OF 261 SHEETS



- 12" 6" 0 1' 2' 3'
- 3/4" = 1' - 0"

  LOWER BIRD CREEK WWTP EXPANSION TMAU PROJECT NO. ES 2006-01 CONTRACT 1B			
OPERATIONS BUILDING ARCHITECTURAL TORNADO SHELTER			
CITY OF TULSA, OKLAHOMA TULSA METROPOLITAN UTILITY AUTHORITY ENGINEERING SERVICES DEPARTMENT			
PLANS AND ESTIMATES PREPARED BY:			
 BLACK & VEATCH <i>Building a world of difference</i>	 Motoway, Updike and Bohlen Consulting Engineers Muskogee - Broken Arrow		
Black & Veatch Corporation Kansas City, Missouri			
PLAN SCALE:	DRAWN	MDE	APPROVED:
	DESIGNED	PDR	 DIRECTOR
	SURVEY		
PROFILE SCALE:	FIELD MGR.	7/23 10/11	
HORIZONTAL: 1" =	SECT. MGR.	10/11	
	PROJ. MGR.	PDR 10/13/11	 DIRECTOR
VERTICAL 1" =	RECOMMENDED:	HAS 4/30/11	
FILE: AA-10	DRAWING: AA-10		DATE 10/28/2011
ATLAS PAGE NO:			SHEET 176 OF 261 SHEETS

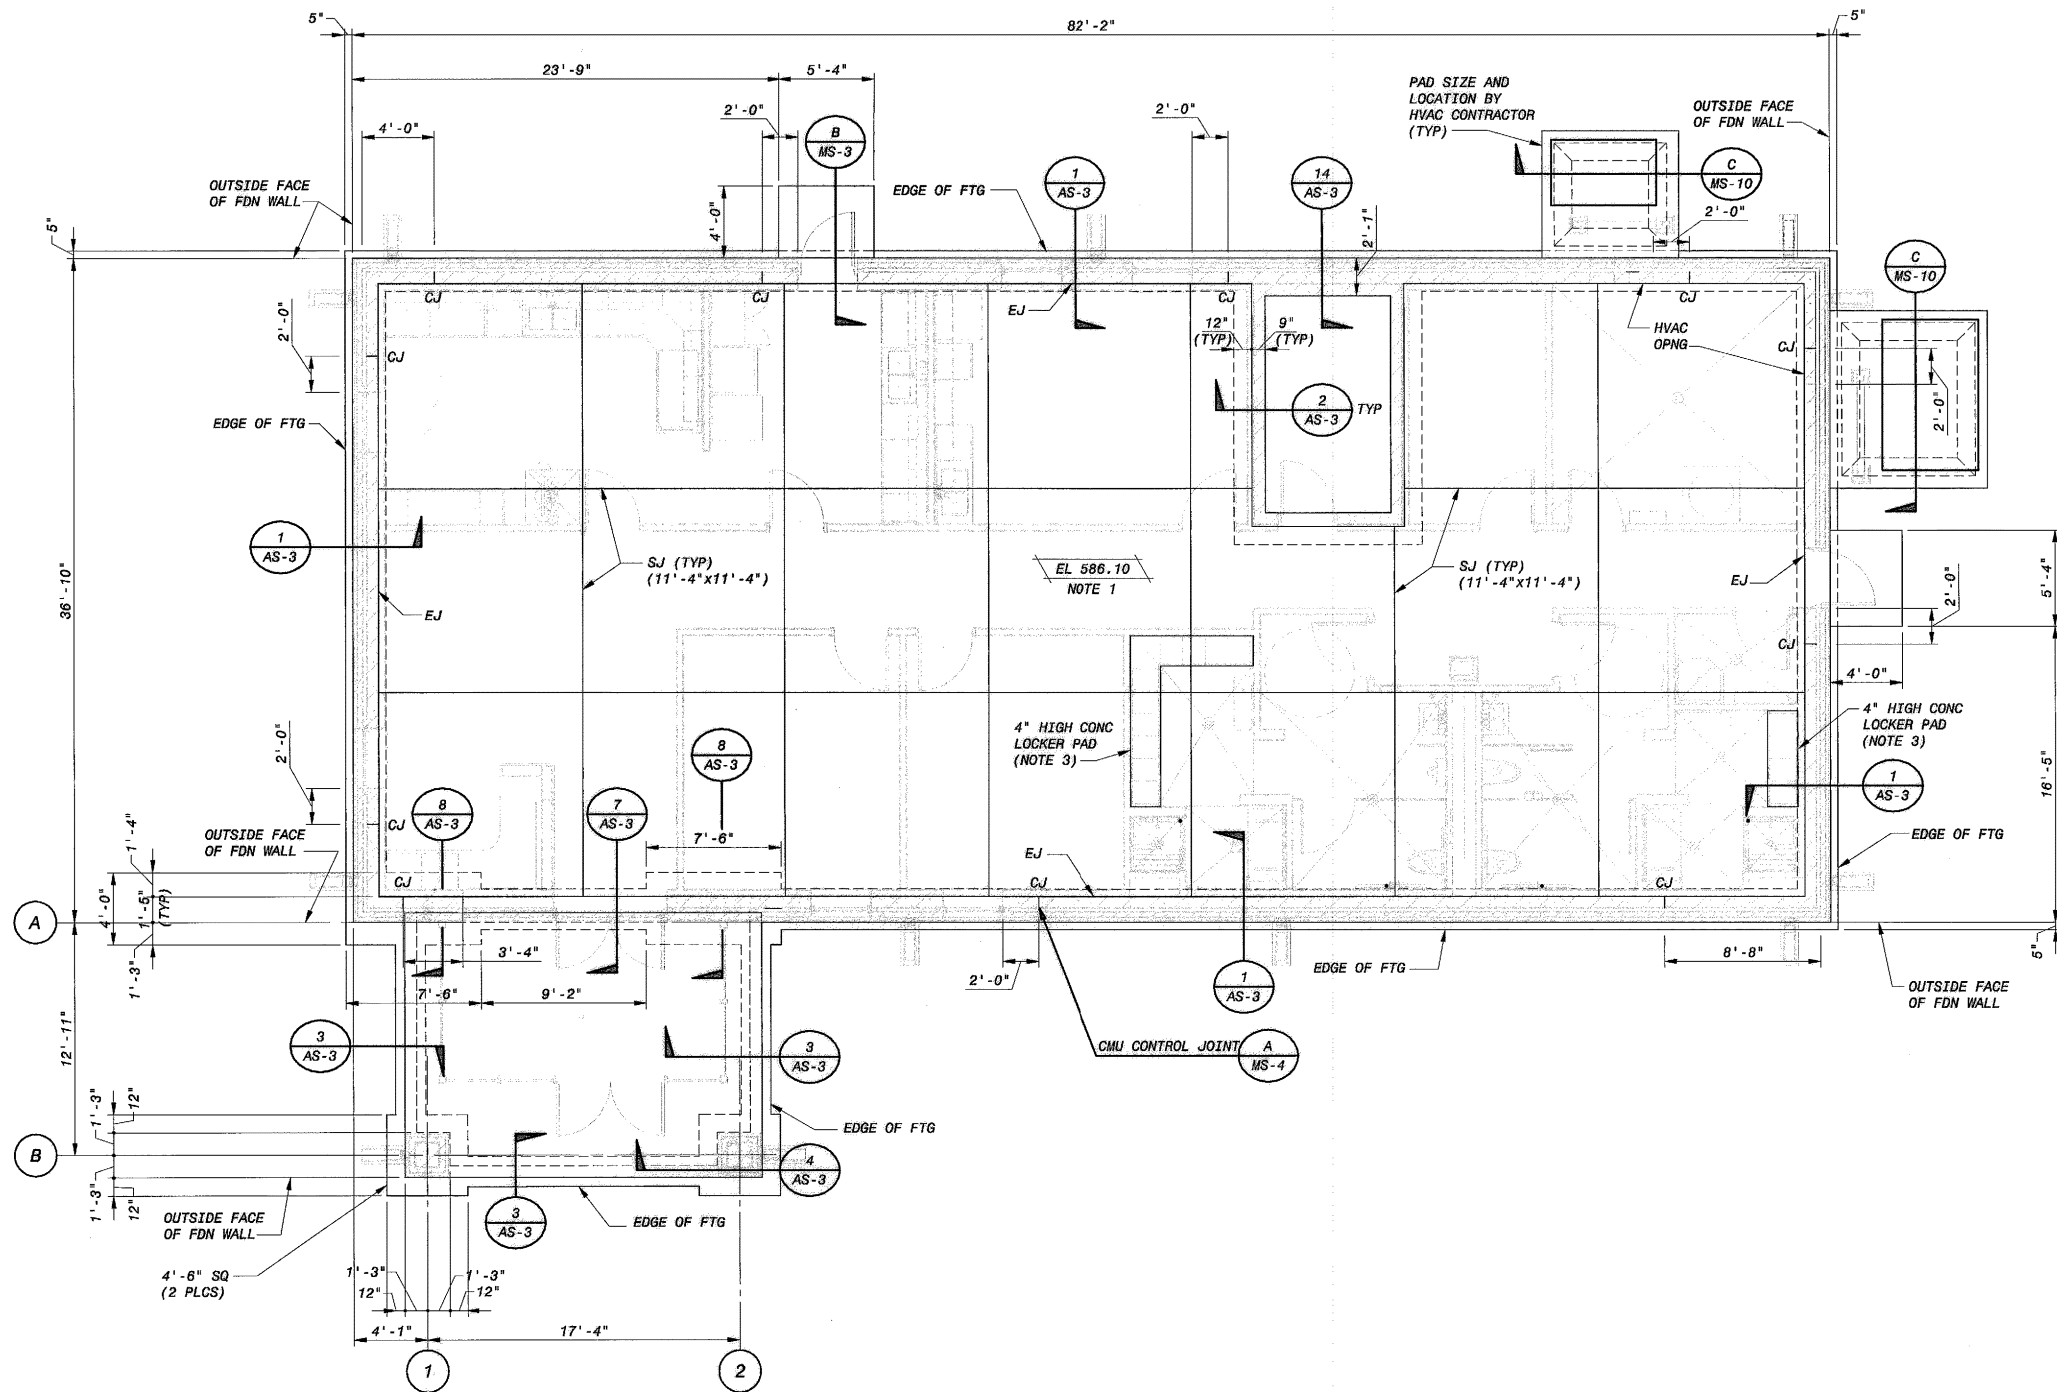


FOUNDATION PLAN & CMU CONTROL JOINT LOCATION PLAN
3/16" = 1'-0"

- NOTES:**
1. SEE PLUMBING DRAWING AP-1 FOR FLOOR DRAINS, PIPE STUB-UPS AND LOW POINT ELEVATIONS. SEE SLAB NOTES ON MS-8.
 2. SEE STD MASONRY DETAIL SHT MS-4 AND MS-5 FOR CMU WALL REINFORCEMENT DETAILS AND SIZES.
 3. SEE ARCH DWGS FOR DETAILS. ADJUST DIMENSIONS BASED ON LOCKERS FURNISHED. PAD IS UNREINFORCED CONCRETE. PROVIDE TOOLED JOINTS AT 2'-6" OC.


LOWER BIRD CREEK WWTP EXPANSION
TMUA PROJECT NO. ES 2006-01
CONTRACT 1B
OPERATIONS BUILDING
STRUCTURAL
FOUNDATION PLAN
CITY OF TULSA, OKLAHOMA
TULSA METROPOLITAN UTILITY AUTHORITY
ENGINEERING SERVICES DEPARTMENT

PLANS AND ESTIMATES PREPARED BY:
BLACK & VEATCH
Building's world of difference
Holloway, Little and Dellen
Consulting Engineers
Muskegon - Broken Arrow
DIGATES
Engineering
Services

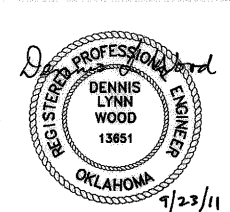

REVISION	BY	DATE	PLAN SCALE:	DRAWN	JGC	APPROVED:
			DESIGNED	DLW		
			SURVEY			
			PROFILE SCALE:	FIELD MGR.	7/23/11	
			HORIZONTAL:	SECT. MGR.	7/23/11	
			1" =	PROJ. MGR.	7/23/11	
			VERTICAL	RECOMMENDED:	7/23/11	
			1" =			
			FILE:	DRAWING: AS-1		
			ATLAS PAGE NO:			


PLOTTED DATE: 6/17/2011 10:55:13 AM
SAVED DATE: 6/17/2011 9:56:36 AM
CYPNET ID: 145120-3000-S-B00003M4V

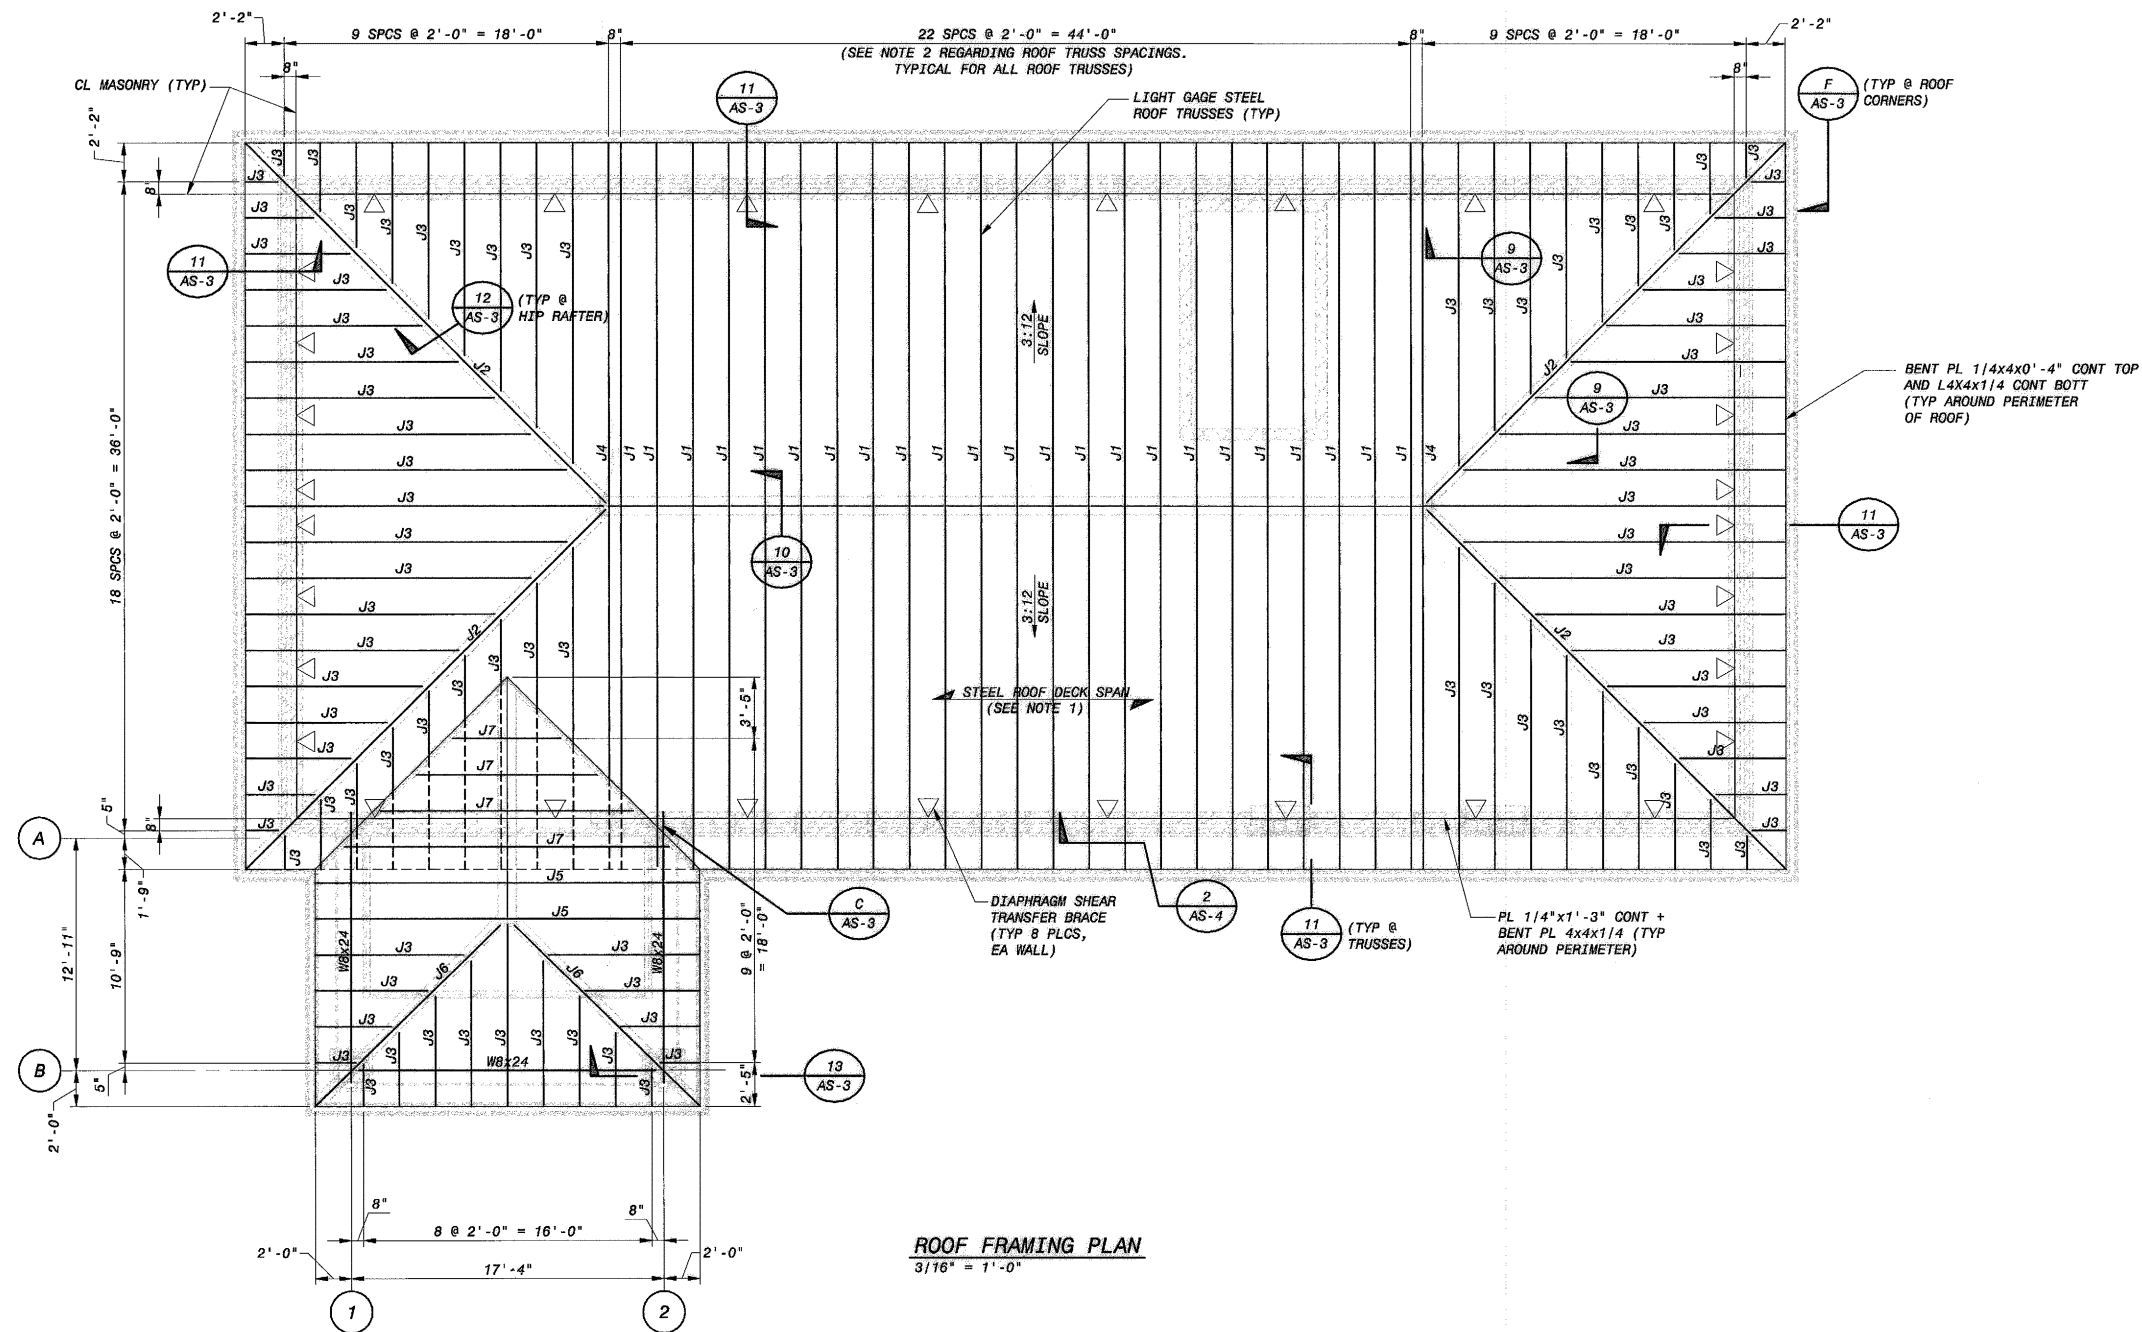



ROOF FRAMING PLAN
3/16" = 1'-0"

NOTES:

 
1. STEEL ROOF DECK SHALL BE 1 1/2" DEEP, TYPE "B", 20 GAGE MATERIAL. DECK FASTENERS TO SUPPORT STEEL SHALL BE #12 TEK SCREWS W/ 36/5 FASTENING PATTERN. DECK SIDELAP FASTENERS SHALL BE #10 TEK SCREWS @ 12" OC.
2. TRUSS SPACINGS MAY BE INCREASED IF LIGHT GAGE STEEL TRUSS VENDOR IS ABLE TO PROVIDE A MORE ECONOMICAL SOLUTION USING A LARGER TRUSS SPACING. TRUSS SPACING SHALL BE LIMITED TO A MAXIMUM OF 4'-0". CHANGES IN DECK GAGE OR NUMBER/SIZE OF FASTENERS REQ'D DUE TO INCREASED SPACING SHALL BE AT NO COST TO OWNER.

LOWER BIRD CREEK WWTP EXPANSION TMUA PROJECT NO. ES 2006-01 CONTRACT 1B			
OPERATIONS BUILDING STRUCTURAL ROOF FRAMING PLAN			
CITY OF TULSA, OKLAHOMA TULSA METROPOLITAN UTILITY AUTHORITY ENGINEERING SERVICES DEPARTMENT			
PLANS AND ESTIMATES PREPARED BY:			
  			
Black & Veatch Corporation Kansas City, Missouri			
Holloway, Urdahl and Ballen Consulting Engineers Muskogee - Broken Arrow			
DINGATE Engineering Services			
REVISION			
BY			
DATE			
PLAN SCALE:			
DRAWN			
DESIGNED			
SURVEY			
PROFILE SCALE:			
FIELD MGR.			
SECT. MGR.			
PROJ. MGR.			
RECOMMENDED:			
FILE:			
DRAWING: AS-2			
ATLAS PAGE NO:			
SHEET 178 OF 261 SHEETS			
DATE 10/28/2011			
DIRECTOR			

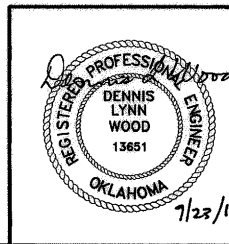


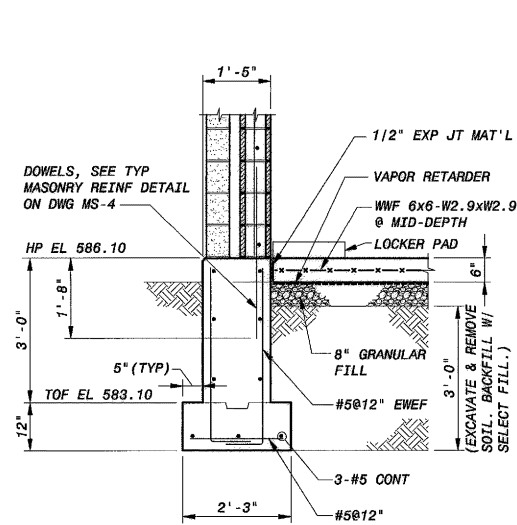


SECTION 1
1/2" = 1'-0"

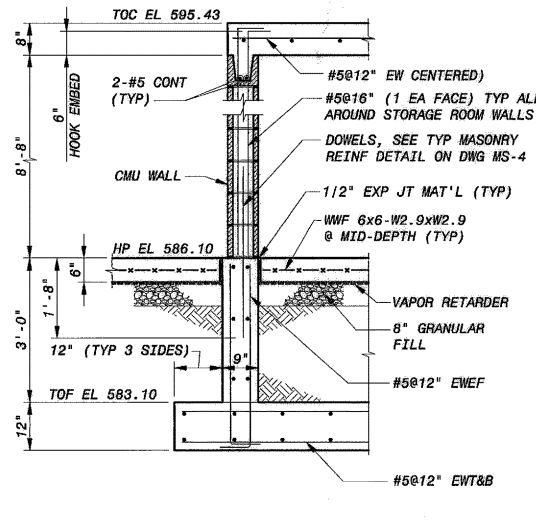


SECTION 2
1/2" = 1'-0"

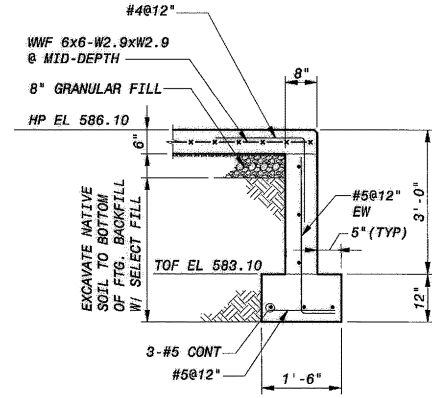


SECTION 3
1/2" = 1'-0"

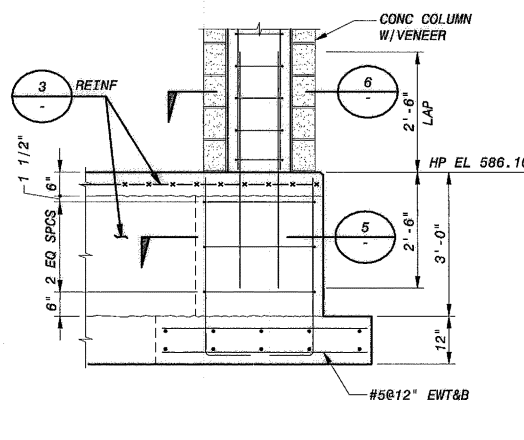


SECTION 4
1/2" = 1'-0"

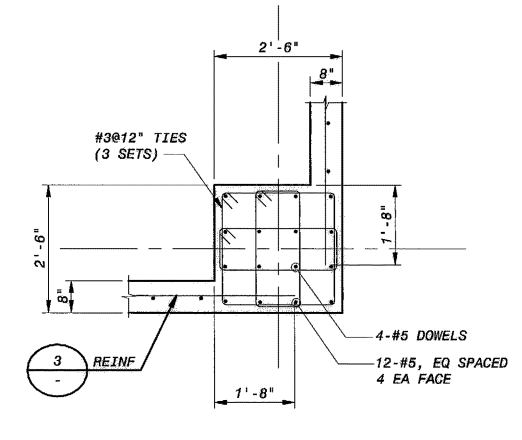


SECTION 5
1/2" = 1'-0"

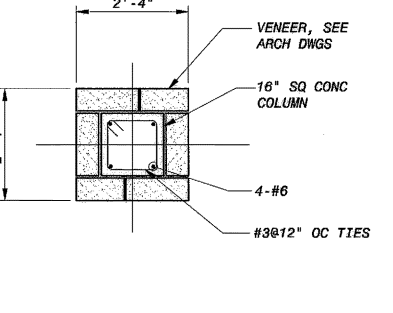


SECTION 6
1/2" = 1'-0"

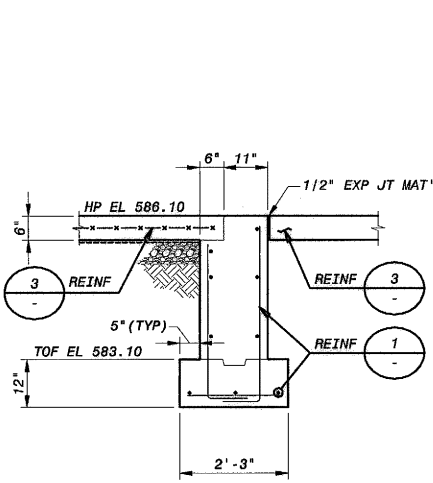


SECTION 7
1/2" = 1'-0"

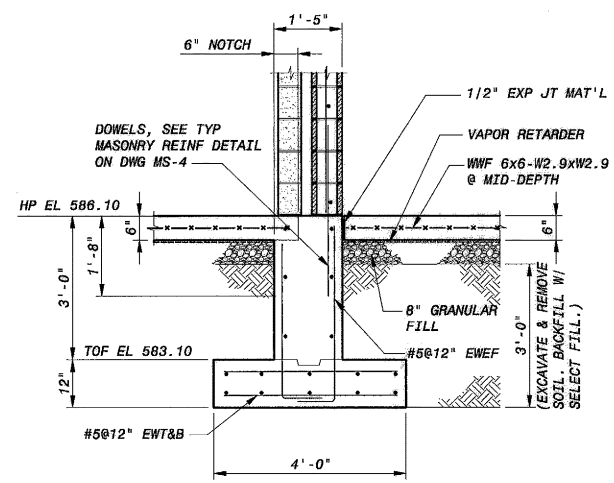


SECTION 8
1/2" = 1'-0"

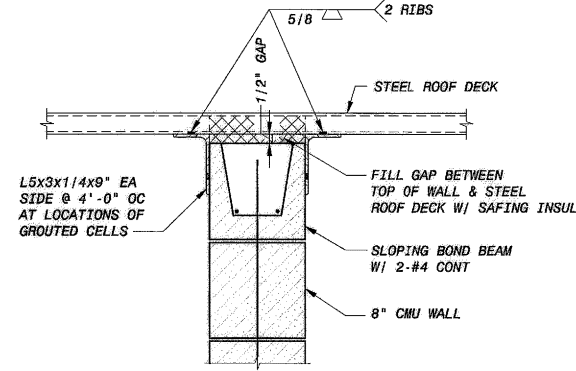


SECTION 9
1 1/2" = 1'-0"

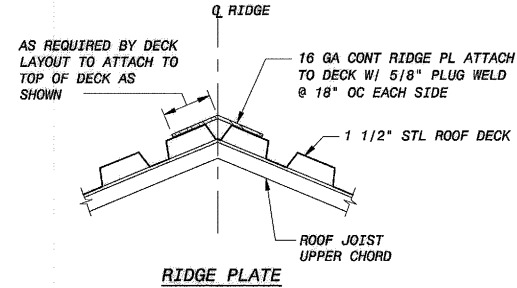


SECTION 10
1 1/2" = 1'-0"

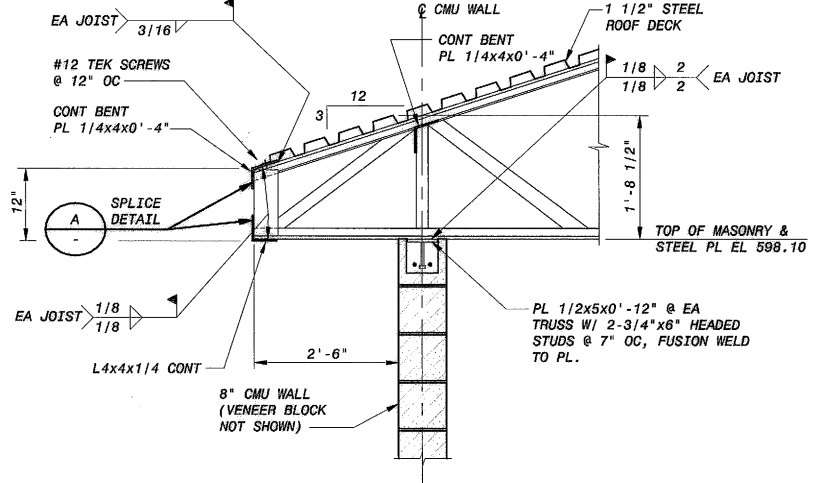


SECTION 11
3/4" = 1'-0"

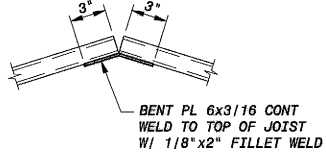


SECTION 12
1 1/2" = 1'-0"

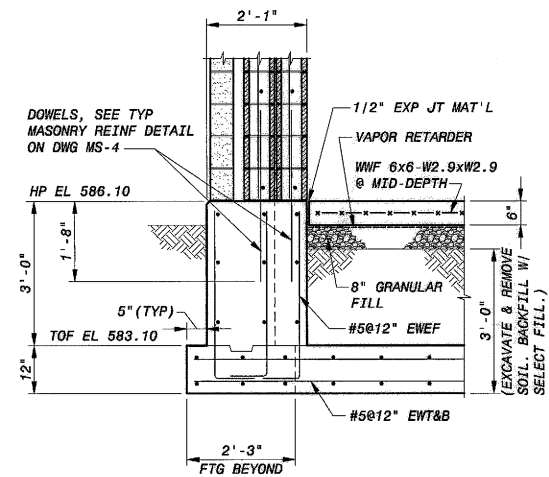


SECTION 14
1/2" = 1'-0"

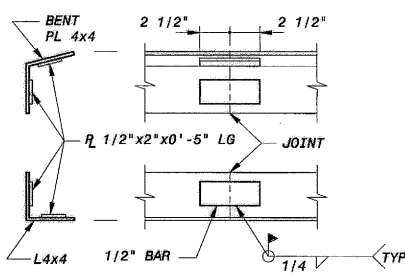


SECTION 13
1 1/2" = 1'-0"

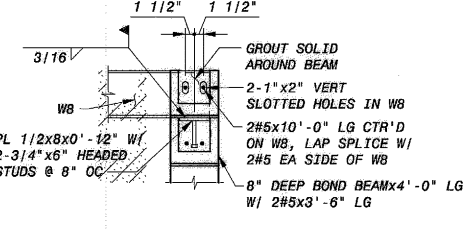


DETAIL C
3/4" = 1'-0"

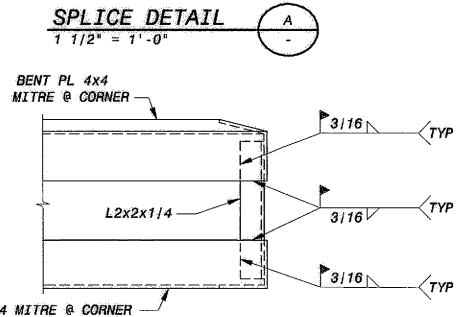

DETAIL A
1 1/2" = 1'-0"

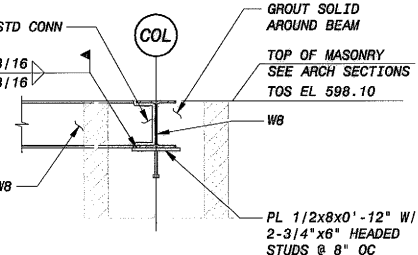

SECTION 13
3/4" = 1'-0"

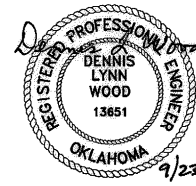


REVISION				BY	DATE


PLAN SCALE:	DRAWN	NMC	APPROVED:
DESIGNED	DLW		
SURVEY			
PROFILE SCALE:	FIELD MGR.	708 10/11	
HORIZONTAL:	SECT. MGR.	20 10/11	
1" =	PROJ. MGR.		
VERTICAL:	RECOMMENDED:		
1" =			
FILE:	DRAWING: AS-3		DATE 10/28/2011
ATLAS PAGE NO:			SHEET 179 OF 261 SHEETS

LOWER BIRD CREEK WWTP EXPANSION
TMUA PROJECT NO. ES 2006-01
CONTRACT 1B
OPERATIONS BUILDING
STRUCTURAL
SECTIONS AND DETAILS
CITY OF TULSA, OKLAHOMA
TULSA METROPOLITAN UTILITY AUTHORITY
ENGINEERING SERVICES DEPARTMENT


PLANS AND ESTIMATES PREPARED BY:
BLACK & VEATCH
Building a world of difference
Holloway, Updike and Ballen
Consulting Engineers
Holloway - Broken Arrow
DUGATES
Engineering Services

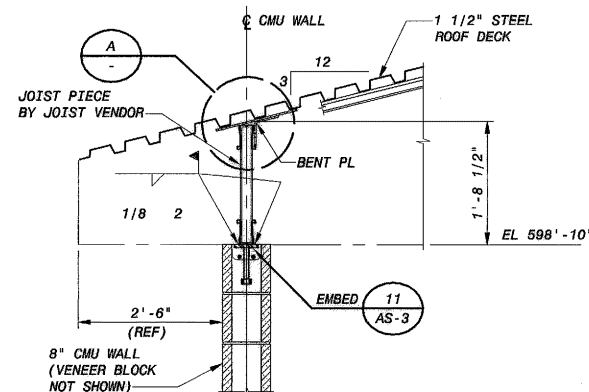


SECTION 1
3/4" = 1'-0"

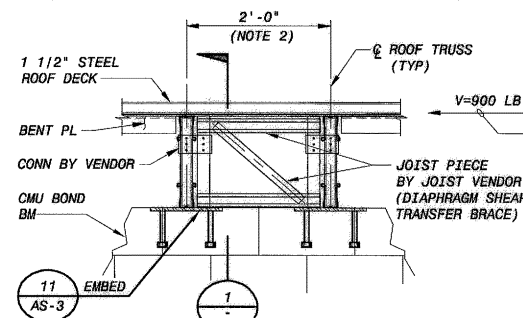


SECTION 2
3/4" = 1'-0"

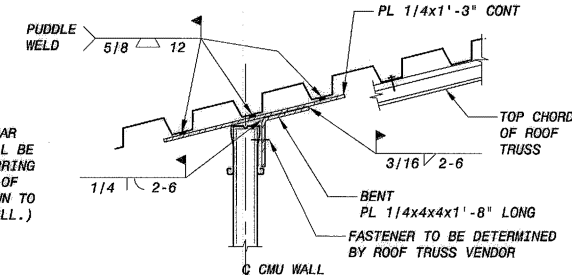


DETAIL A
1 1/2" = 1'-0"

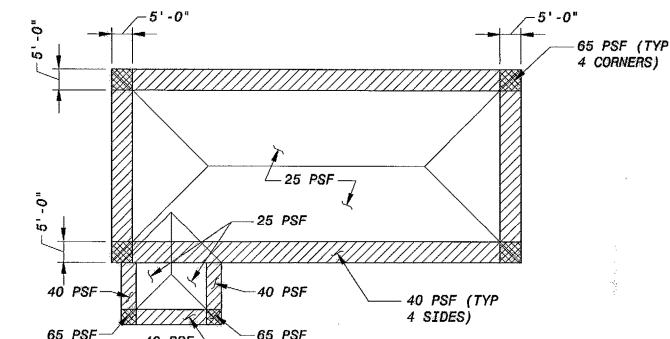


WIND UPLIFT DESIGN PRESSURES
FOR LIGHT GAGE ROOF TRUSSES
NO SCALE

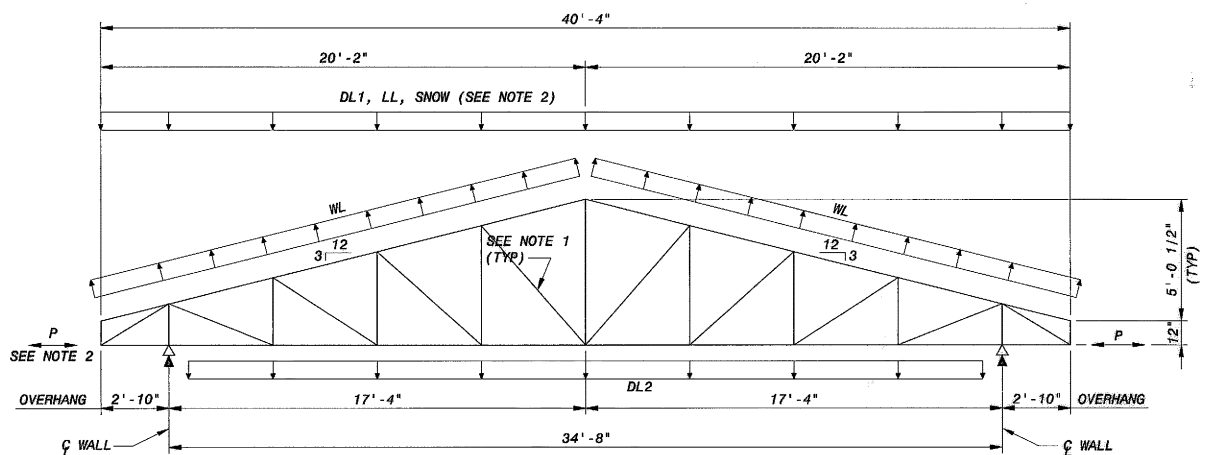


ROOF TRUSS J1
NO SCALE

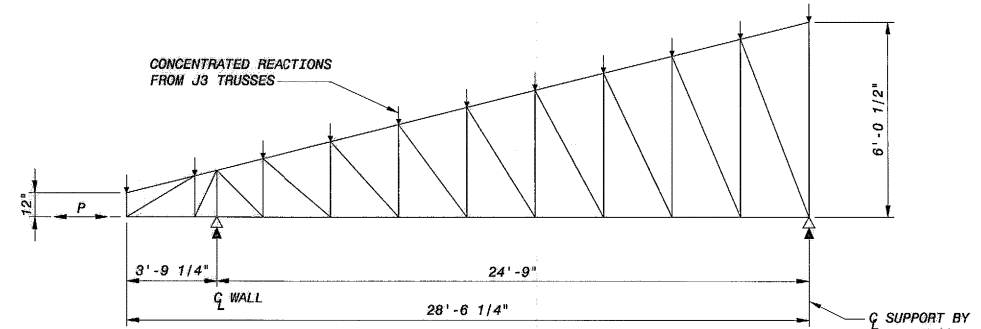


JOIST J2
NO SCALE

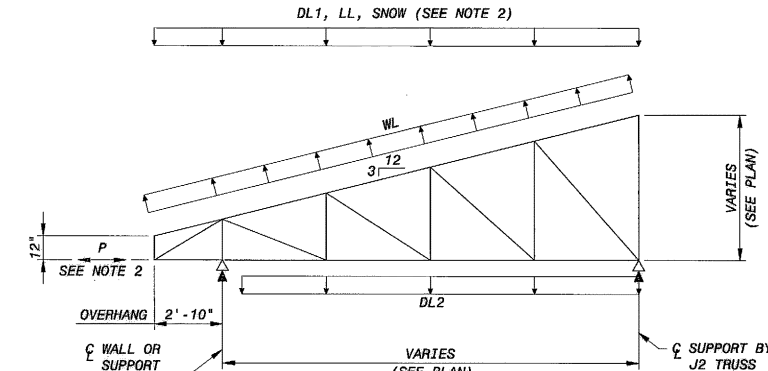

ROOF TRUSS J3
NO SCALE

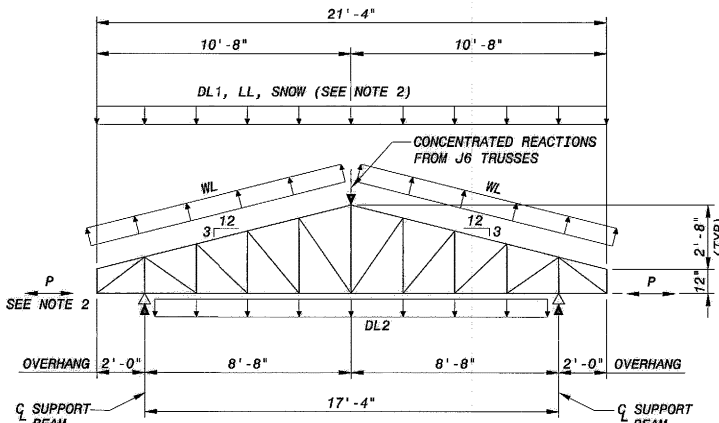


ROOF TRUSS J5
NO SCALE

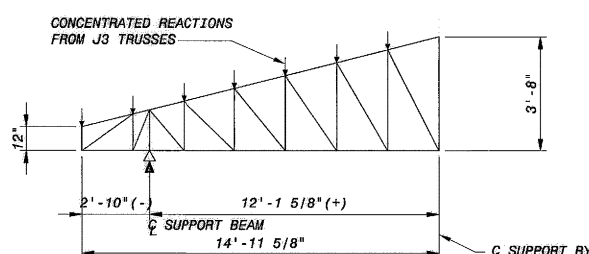


JOIST J6
NO SCALE

- NOTES:
1. TRUSS WEB MEMBER ARRANGEMENT IS REPRESENTATIVE ONLY, ACTUAL ARRANGEMENT SHALL BE DETERMINED BY TRUSS VENDOR.
 2. LIGHT GAGE STEEL TRUSS LOADING INFORMATION AS FOLLOWS:
DL1 = 15 PSF (DEAD LOAD APPLIED TO TOP CHORD OF TRUSS DUE TO METAL DECK, INSULATION, PLYWOOD, ETC.)
DL2 = 7 PSF (DEAD LOAD APPLIED TO BOTTOM CHORD OF TRUSS DUE TO HVAC, CEILING TILES, LIGHTING, ETC.)
LL (ROOF LIVE LOAD) = 20 PSF (NON-REDUCIBLE)
CONCENTRATED PHANTOM LIVE LOAD = 500 LB (SHALL BE APPLIED AT LOCATIONS THAT WILL INDUCE WORST CASE MOMENT AND WORST CASE SHEAR IN ROOF TRUSSES. SHALL BE COMBINED WITH UNIFORM ROOF LL.)
S (SLOPED ROOF SNOW LOAD) = 10 PSF
WL (WIND LOAD) = SEE LOADING DIAGRAM ON THIS DRAWING: WIND LOADING IS SERVICE LEVEL
P = 500 LB (SERVICE LEVEL) (CONCENTRATED LOAD DUE TO LATERAL WIND OR SEISMIC FORCES FROM MASONRY WALLS. LOAD WILL BE APPLIED TO BOTTOM CHORD AND MUST BE TRANSFERRED THROUGH THE ROOF TRUSSES TO THE STEEL ROOF DECK DIAPHRAGM THAT IS ATTACHED TO THE TOP CHORD. LOAD "P" WILL BE APPLIED AT EACH SUPPORTING WALL LOCATION.)
 3. TRUSS MANUFACTURER SHALL DESIGN AND PROVIDE THE REQUIRED BRIDGING (LATERAL BRACING) REQUIRED TO ENSURE STABILITY OF TRUSSES.
 4. LOAD COMBINATIONS FOR TRUSS DESIGN SHALL BE IN ACCORDANCE WITH THE 2006 INTERNATIONAL BUILDING CODE.

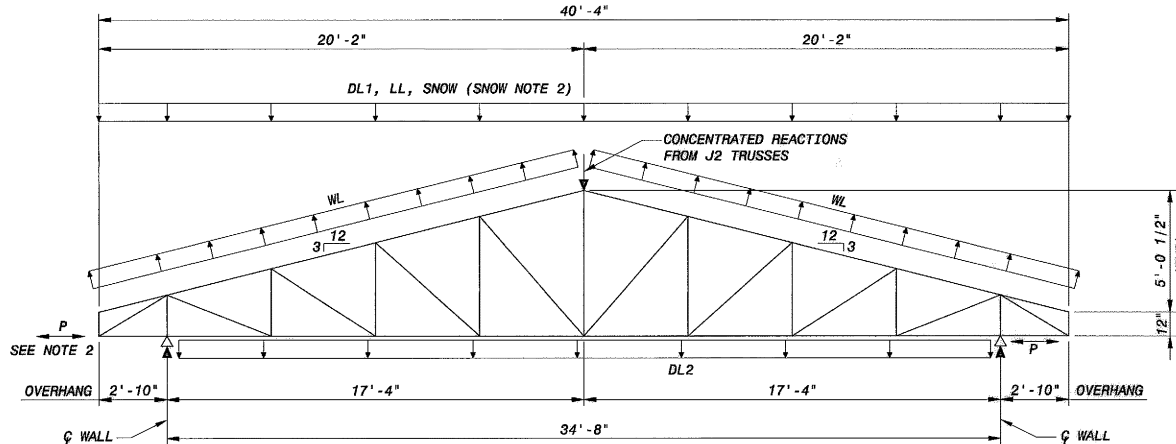


ROOF TRUSS J4
NO SCALE

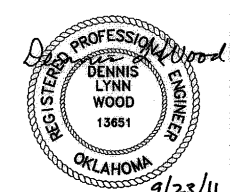


REVISION	BY	DATE

LOWER BIRD CREEK WWTP EXPANSION TMAU PROJECT NO. ES 2006-01 CONTRACT 1B			
OPERATIONS BUILDING STRUCTURAL SECTIONS, DETAILS & ROOF TRUSS LOADS			
CITY OF TULSA, OKLAHOMA TULSA METROPOLITAN UTILITY AUTHORITY ENGINEERING SERVICES DEPARTMENT			
PLANS AND ESTIMATES PREPARED BY:			
BLACK & VEATCH Building a world of difference	Holloway, Updike and Bollen Consulting Engineers Muskegon - Broken Arrow	OWGATES Engineering Services	
PLAN SCALE:	DRAWN	NMC	APPROVED:
	DESIGNED	DLW	
	SURVEY		
PROFILE SCALE:	FIELD MGR.	10/10/11	
HORIZONTAL:	SECT. MGR.	10/10/11	
	PROJ. MGR.	10/10/11	
	RECOMMENDED:	10/10/11	
FILE:	DRAWING: AS-4	DATE 10/28/2011	
ATLAS PAGE NO:		SHEET 180 OF 261 SHEETS	

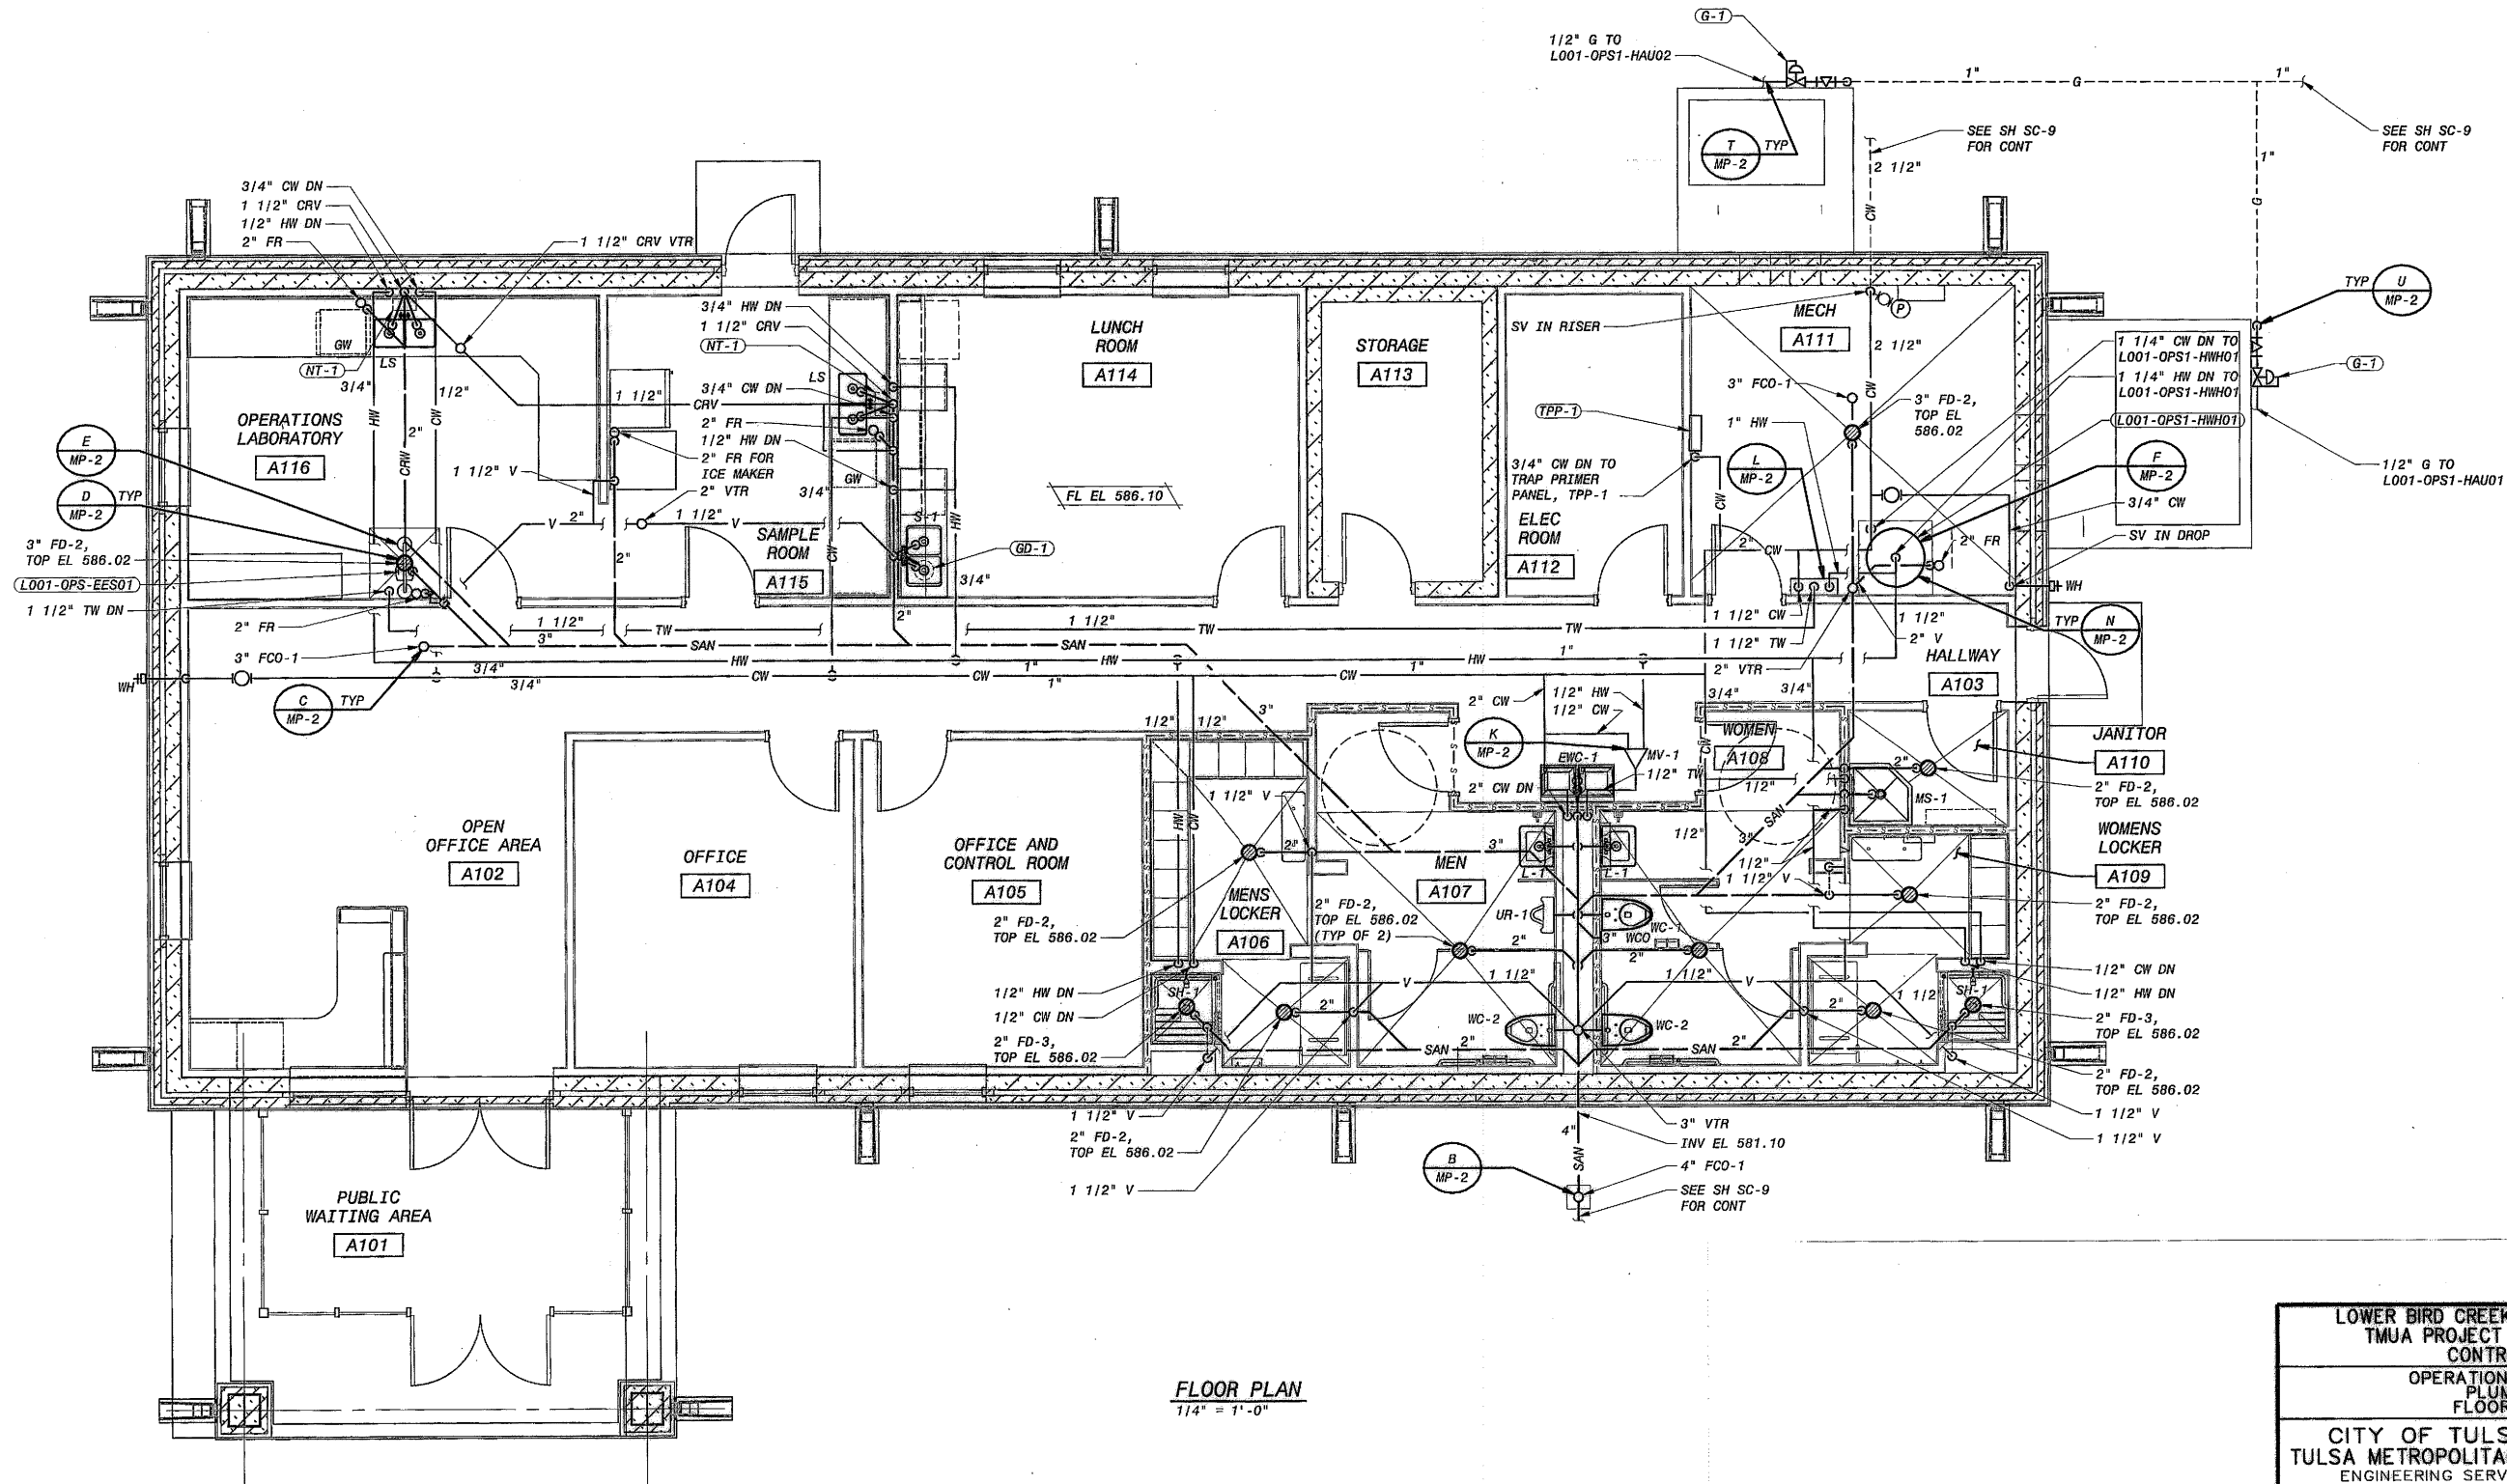


FLOOR PLAN
1/4" = 1'-0"


LOWER BIRD CREEK WWTP EXPANSION TMUA PROJECT NO. ES 2006-01 CONTRACT 1B			
OPERATIONS BUILDING PLUMBING FLOOR PLAN			
CITY OF TULSA, OKLAHOMA TULSA METROPOLITAN UTILITY AUTHORITY ENGINEERING SERVICES DEPARTMENT			
PLANS AND ESTIMATES PREPARED BY:			
BLACK & VEATCH Building a world of difference		Holloway, Hoffman and Bolton Consulting Engineers Mechanical - Electrical - Plumbing	
PLANNED PROFESSIONAL ENGINEER 			
REVISION BY DATE	DRAWN DESIGNED SURVEY FIELD MGR. SECT. MGR. PROJ. MGR. RECOMMENDED:	BDL TRD 708 10/11 10/11/11 HBS 10/30/11	APPROVED: DIRECTOR DATE 10/28/2011 SHEET 181 OF 261 SHEETS
FILE: AP-01.DWG ATLAS PAGE NO:		DRAWING: AP-1 DATE 10/28/2011	

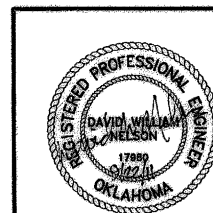

REVISION	BY	DATE


PLAN SCALE:	DRAWN	BDL	APPROVED:
1/4" = 1'-0"	DESIGNED	TRD	
PROFILE SCALE:	SURVEY		
1" =	FIELD MGR.	708 10/11	
	SECT. MGR.		
	PROJ. MGR.	10/11/11	
	RECOMMENDED:	HBS 10/30/11	

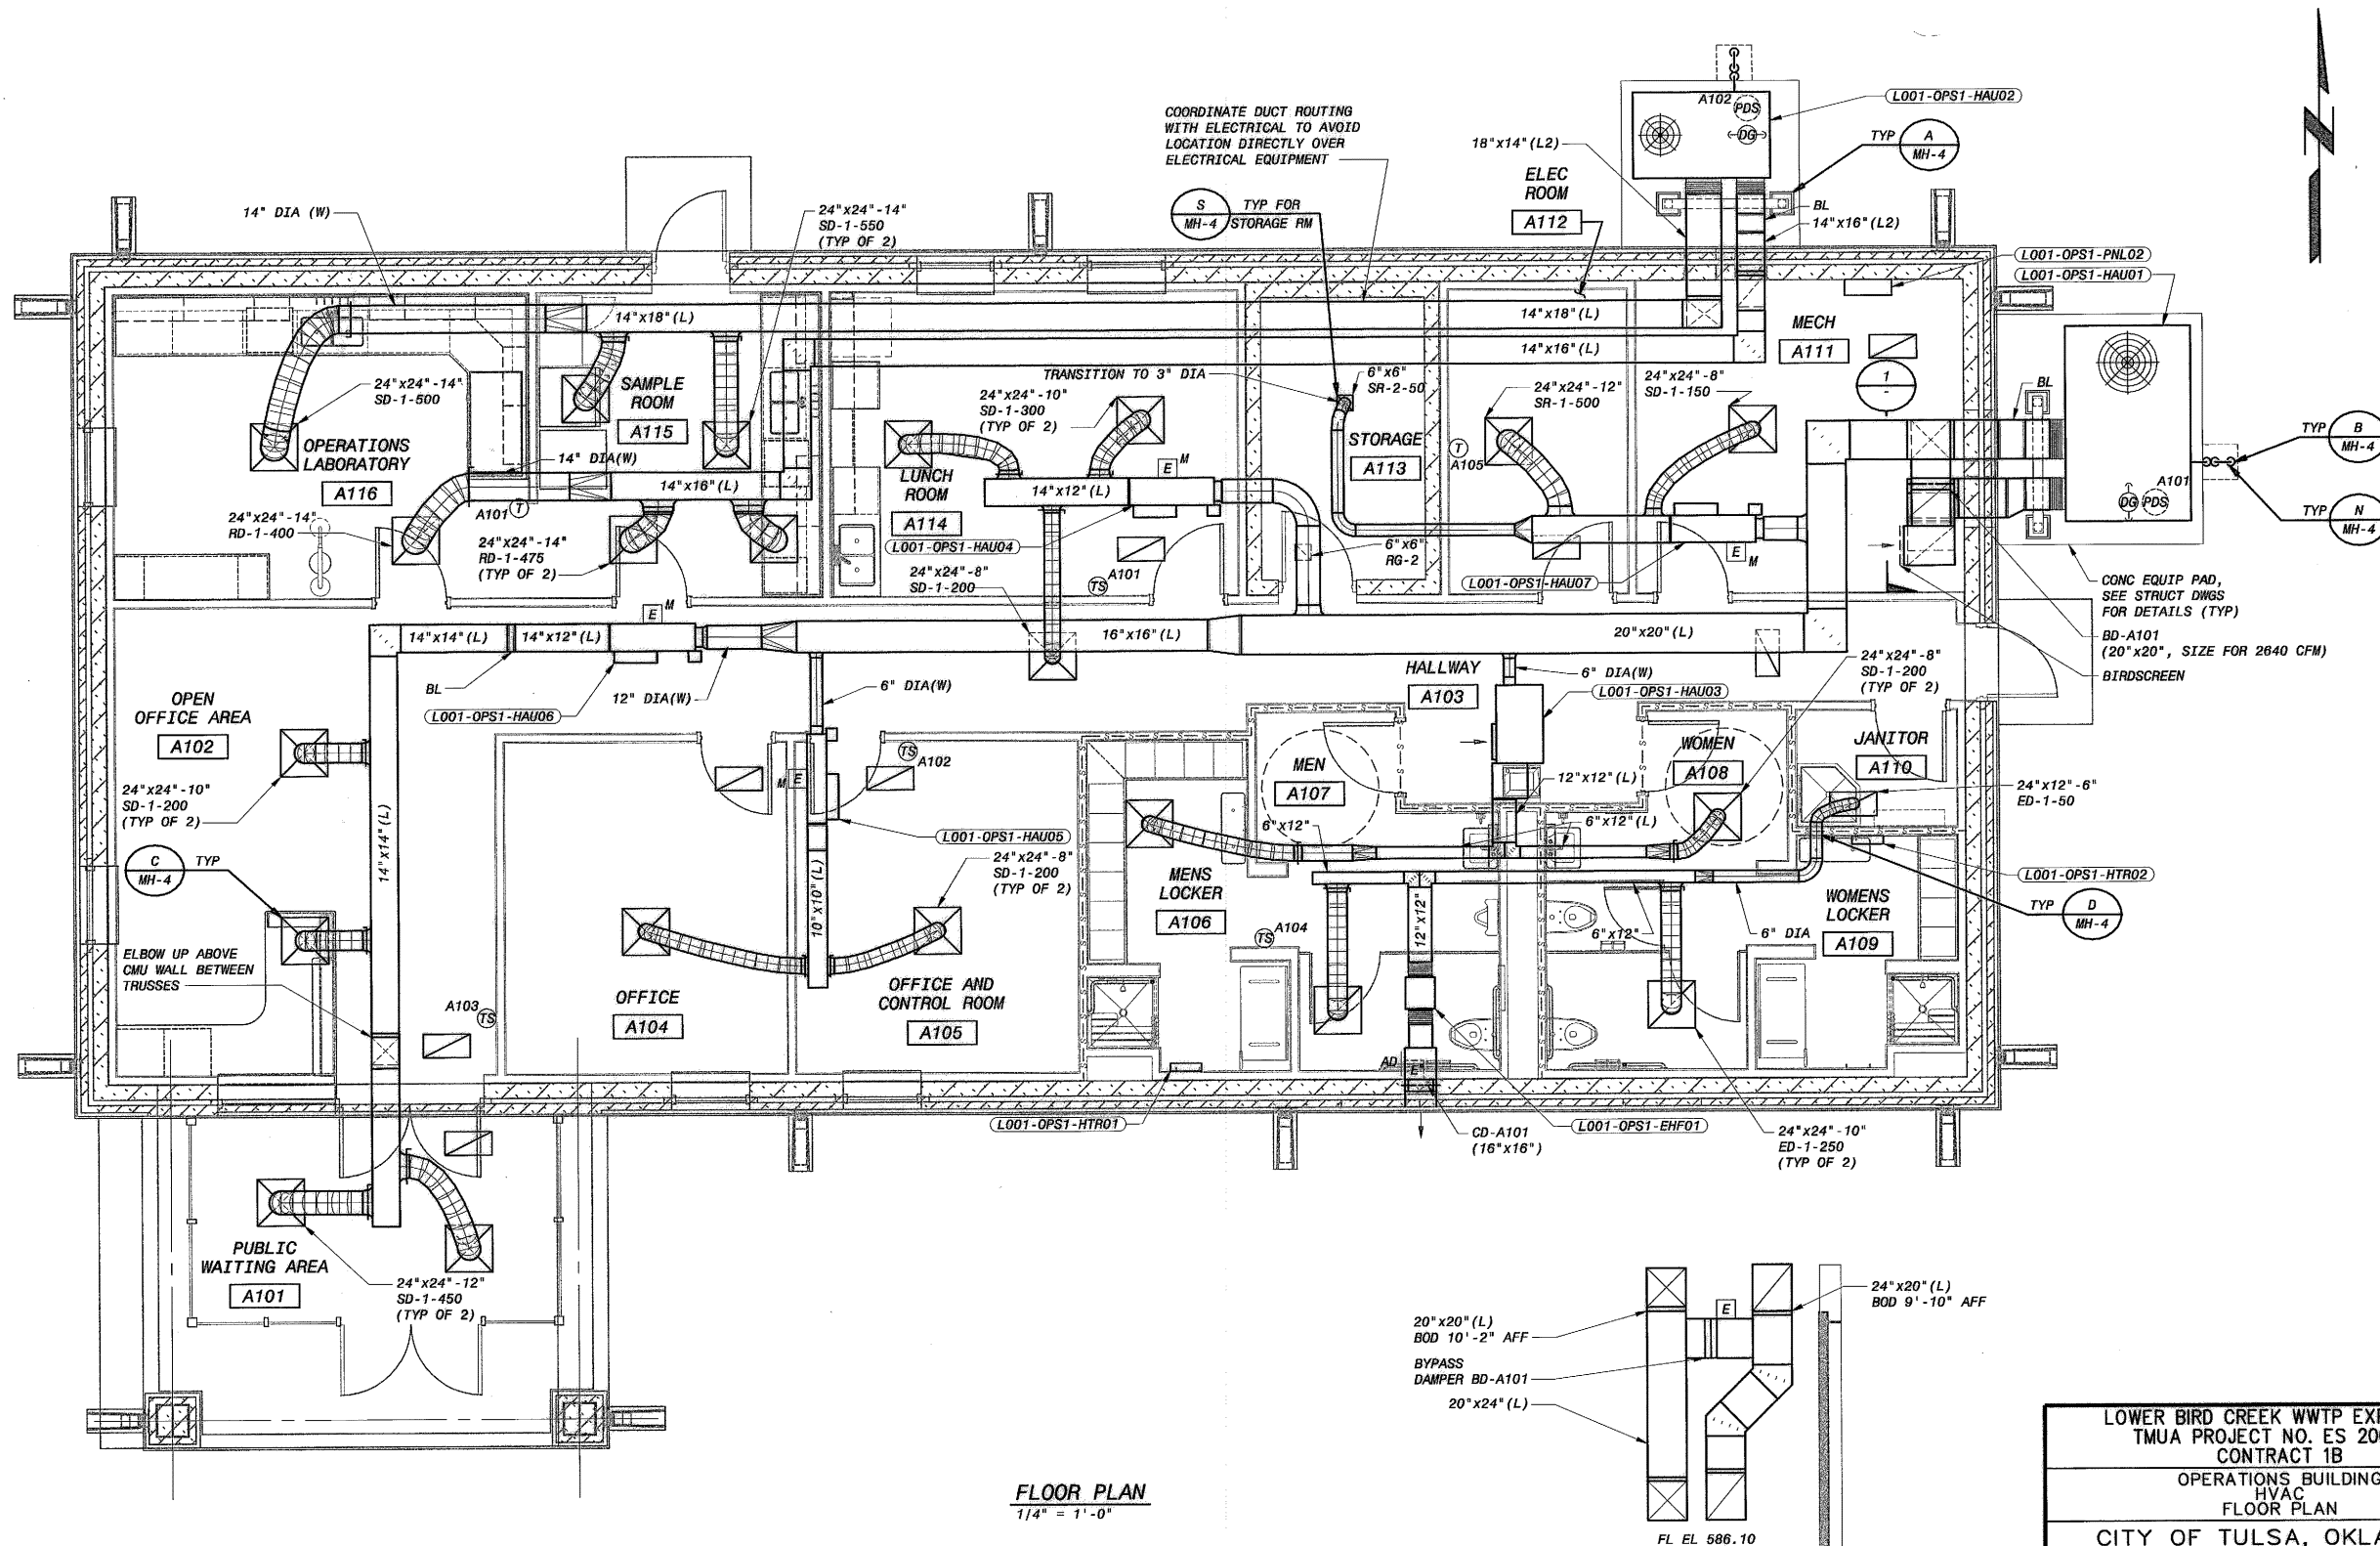

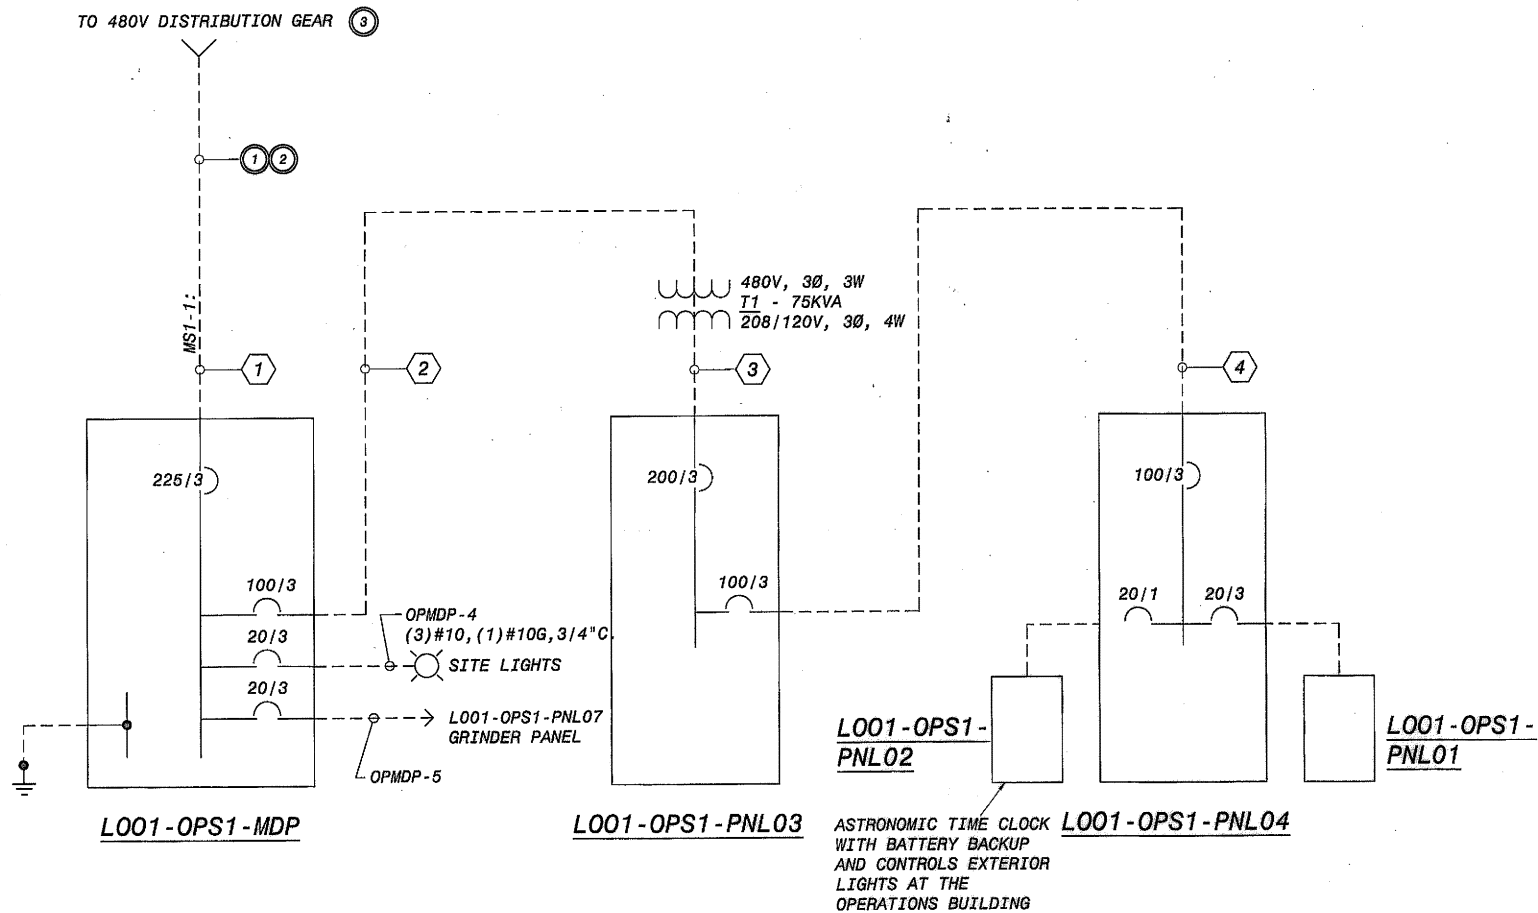


ELECTRICAL - RISER DIAGRAMS
SCALE: NONE

FEEDER SCHEDULE		
No.	CONDUIT	WIRE SIZE
①	(1) - 4" (1) - 4" SPARE	(3) - #4/0 & (1) - #2G
②	(1) - 1 1/2"	(3) - #3 THWN & (1) - #8G
③	(1) - 2"	(4) - #3/0 THWN & (1) - #6G
④	(1) - 1 1/2"	(4) - #3 THWN & (1) - #8G

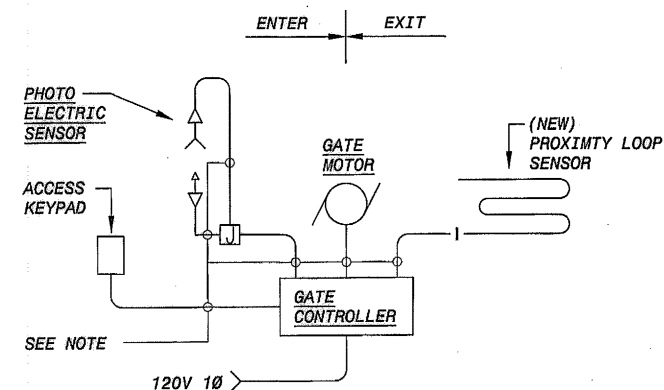

ELECTRIC OPERATED ACCESS GATE
SCALE: NONE

NOTE: CIRCUIT FOR GATE CONTROLLER TO USE DUCT BANK AND CONDUIT SHOWN ON CIVIL SITE PLAN SE-4. INSTALL 3-#12, 1-#12G AND 6-#14 CONTROL IN 2" PVC CONDUIT TO OPERATIONS BUILDING. INITIAL UNIT IS RELOCATED CITY OF TULSA GATE CONTROLLER. PROVIDE NEW PROXIMITY LOOP SENSOR AND CONNECT RELOCATED GATE CONTROLLER, KEYPAD AND PHOTO ELECTRIC SENSOR AND ASSOCIATED SUPPORTS. ALL EXPOSED CONDUIT TO BE 3/4" RIGID GALVANIZED STEEL.

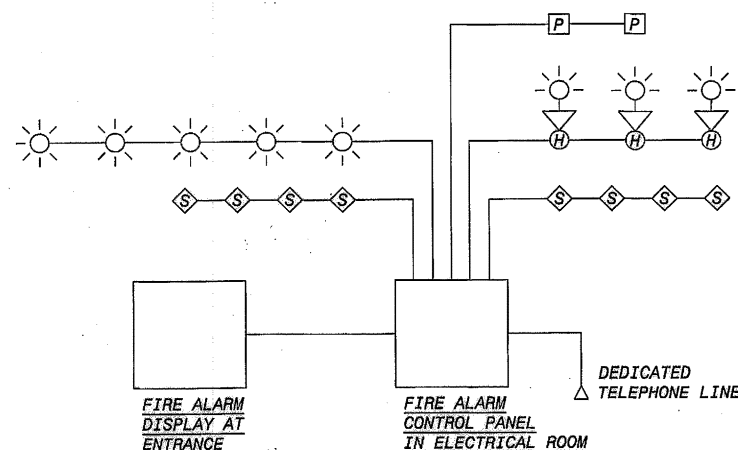

FIRE ALARM RISER DIAGRAM - SEE SPECIFICATIONS FOR REQUIREMENTS
SCALE: NONE

NOTE:
FIRE ALARM RISER DIAGRAM IS PROVIDED FOR REFERENCE. SEE SPECIFICATIONS FOR ADDITIONAL INFORMATION. IF THERE IS A CONFLICT BETWEEN THE SPECIFICATIONS AND THE DIAGRAM, THE SPECIFICATIONS SHALL APPLY.

		REVISION	BY	DATE	PLAN SCALE:	DRAWN	FLT	APPROVED:
						DESIGNED	AC	
					PROFILE SCALE:	FIELD MGR.	708 10/11	
					HORIZONTAL:	SECT. MGR.	201 10/11	
					VERTICAL:	RECOMMENDED:	10/11	
					FILE: AE01	DRAWING: AE-1	DATE 10/28/2011	
					ATLAS PAGE NO:	SHEET 183 OF 261 SHEETS		


NOTES:

- RUN (1) ADDITIONAL 4" CONDUIT FOR POWER SPARE. SEE SITE PLAN FOR ROUTING.
- RUN (2) - 2" CONDUITS FOR CONTROL. STUB UP CONDUITS IN ELECTRICAL ROOM.
- REFER TO SITE POWER PLAN FOR LOCATION OF EXISTING OUTDOOR 480V MAIN GEAR AND DUCT BANK SYSTEM.
- GROUND SYSTEM PER ELECTRICAL CODE REQUIREMENTS WITH A 3/4" x 10' COPPER-CLAD STEEL ROD. CONNECT TO GROUND BUS IN MDP WITH A GREEN INSULATED 4/0 COPPER WIRE.

LOWER BIRD CREEK WWTP EXPANSION
TMUA PROJECT NO. ES 2006-01
CONTRACT 1B
OPERATIONS BUILDING
ELECTRICAL
RISER DIAGRAMS
CITY OF TULSA, OKLAHOMA
TULSA METROPOLITAN UTILITY AUTHORITY
ENGINEERING SERVICES DEPARTMENT

PLANS AND ESTIMATES PREPARED BY:
BLACK & VEATCH
Building a world of difference
Hollaway, Updike and Bellon
Consulting Engineers
Markings - Broken Arrow
Black & Veatch Corporation
Tulsa, Oklahoma

NOTE:
FRONT GATE & SIGN ARE
SHOWN ON CIVIL OVERALL
SITE PLAN SC-2

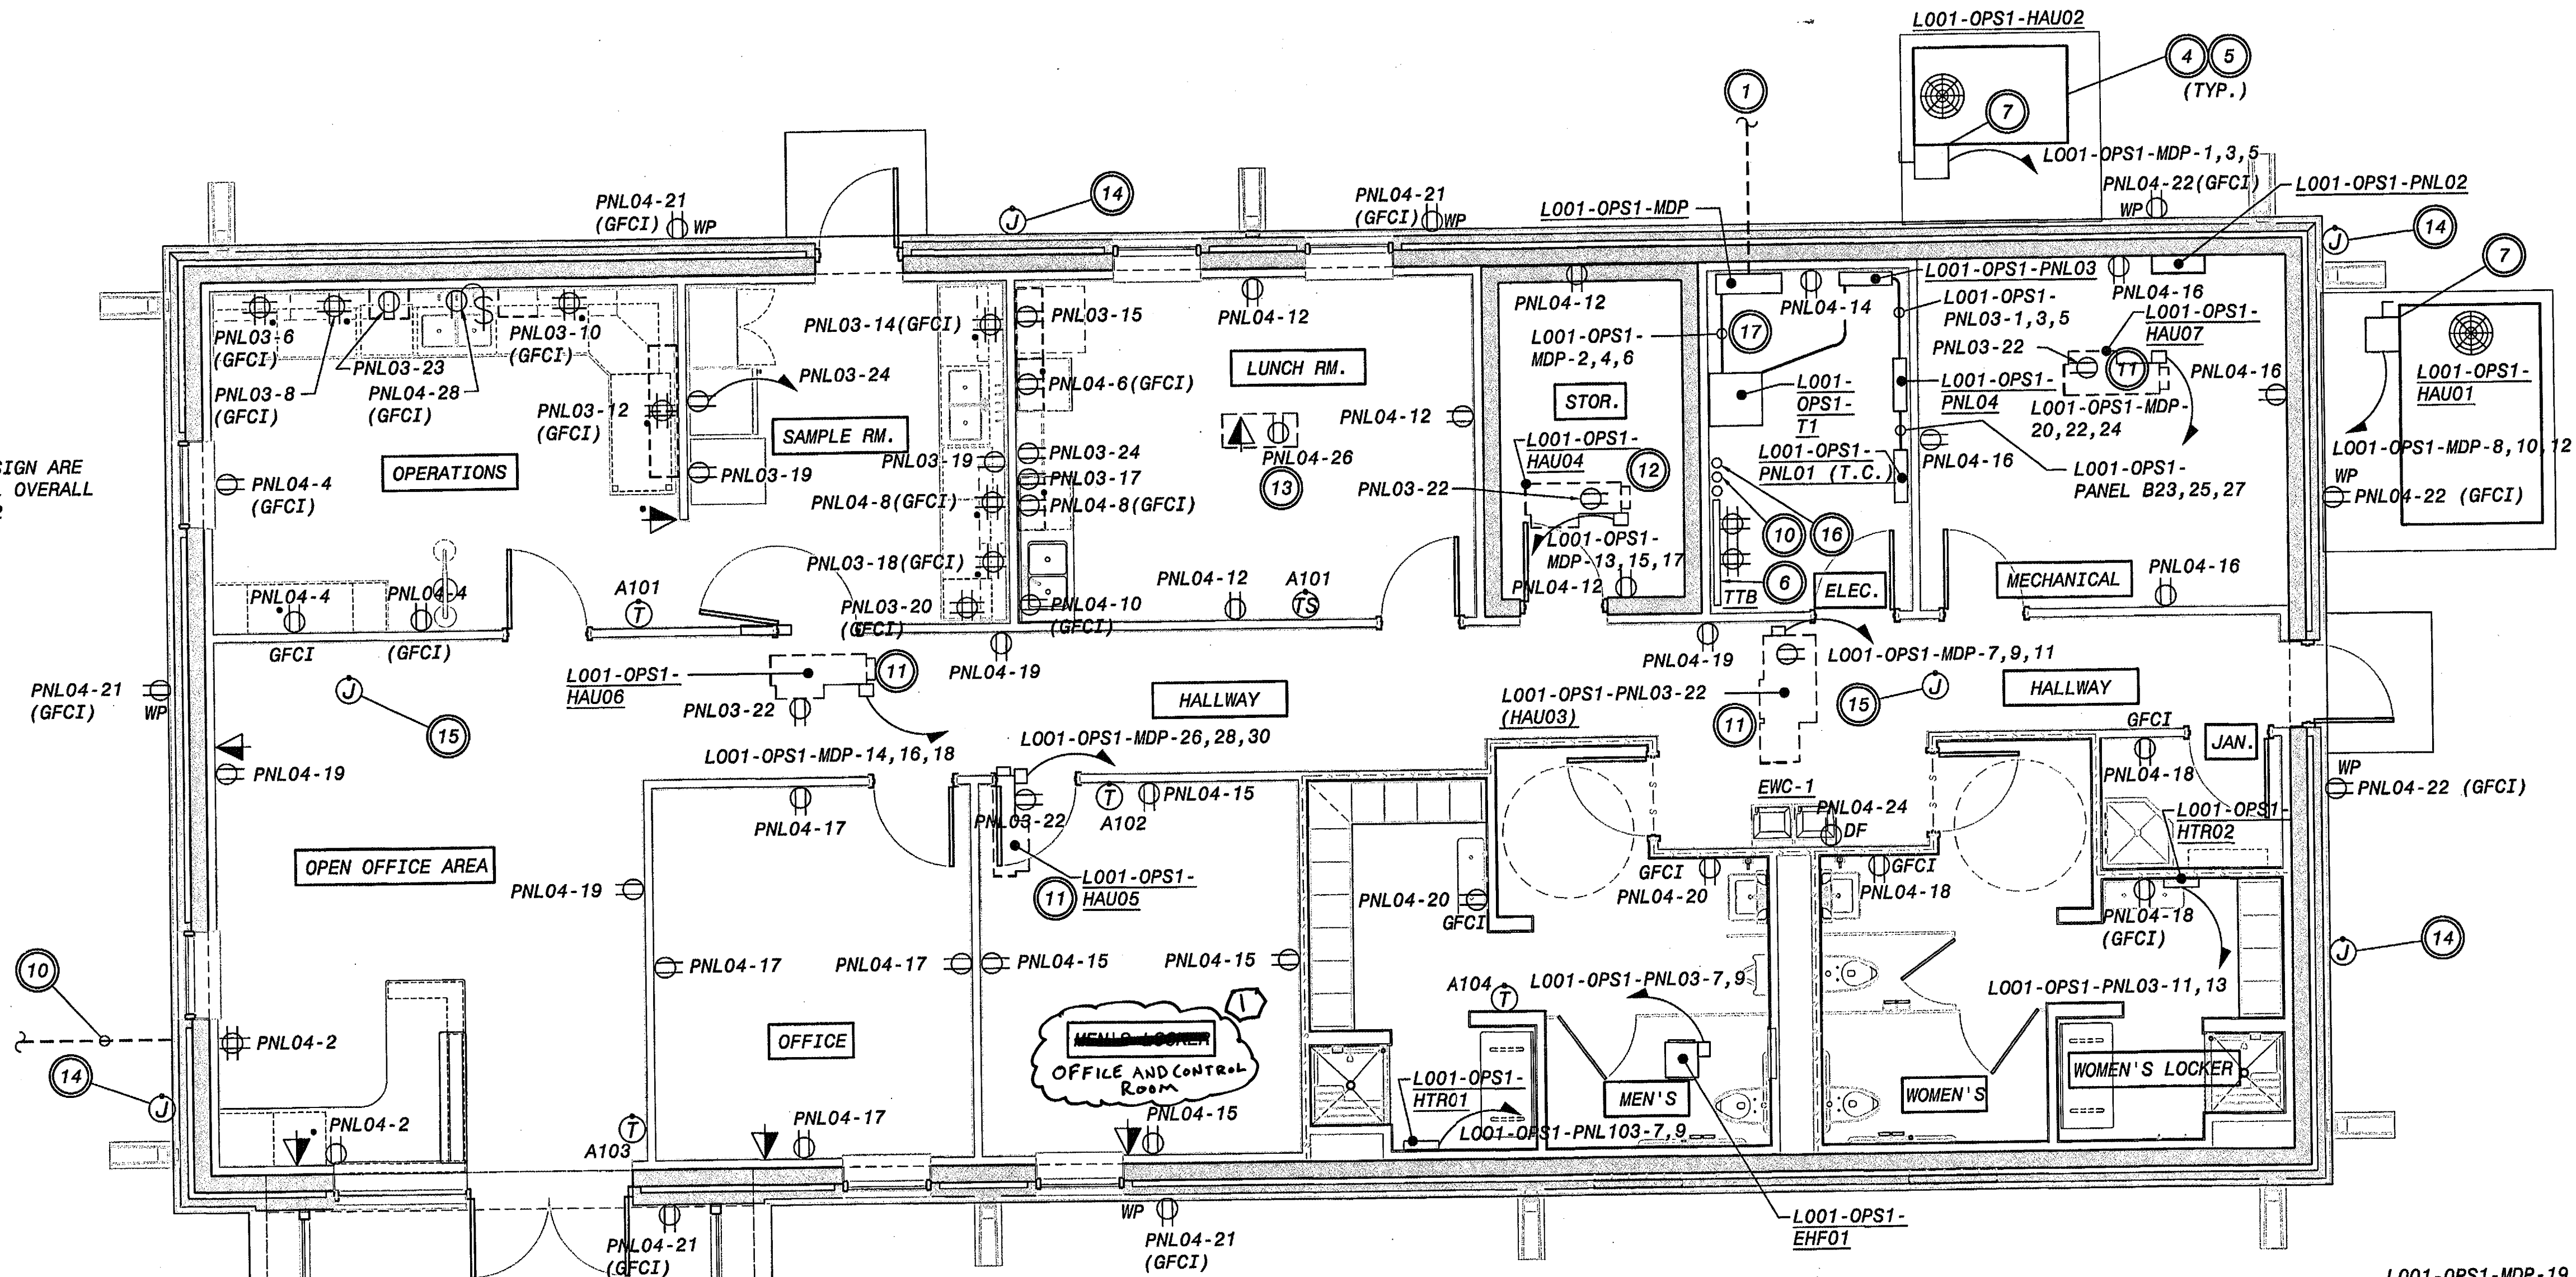

NOTES:


- 1 NEW UNDERGROUND FEED TO NEW PANEL MDP. REFER TO ONE-LINE DIAGRAM FOR CONDUIT AND WIRE SIZES. REFER ALSO TO SITE UTILITY PLAN.
- 2 CONNECT CIRCULATING PUMP CP-1 TO 120V CIRCUIT. REFER TO PANEL SCHEDULE. REFER TO MECHANICAL PLAN FOR EXACT LOCATION.
- 3 CONNECT FIRE ALARM SYSTEM TO TAMPER SWITCH AND FLOW VALVE ON SPRINKLER SYSTEM RISER. REFER TO MECHANICAL, PLUMBING AND FIRE ALARM DRAWINGS.
- 4 REFER TO MECHANICAL PLAN FOR EXACT LOCATION OF EQUIPMENT.
- 5 REFER TO PANEL SCHEDULES FOR CIRCUIT DESIGNATIONS ON EQUIPMENT.
- 6 INSTALL 4'x8' PLYWOOD PHONE/COMMUNICATIONS BOARD. PROVIDE (2) DOUBLE DUPLEX RECEPTACLES AT TELEPHONE BOARD. CONNECT RECEPTACLES TO PNL04-30.
- 7 FURNISH AND INSTALL A NEMA 3R, 3P, 480V, 3PH, 100A, NON-FUSED DISCONNECT, UNLESS SUPPLIED WITH UNIT.
- 8 FURNISH AND INSTALL A NEMA 3R, 3P, 480V, 3PH, 30A, NON-FUSED DISCONNECT FOR PHP-A102.
- 9 FURNISH AND INSTALL ALL NECESSARY CONDUIT AND WIRE FOR HVAC CONTROLS. COORDINATE WITH HVAC CONTRACTOR.
- 10 OUTGOING CIRCUIT TO UTILIZE DUCT BANK SHOWN ON CIVIL SITE PLAN SE-4. SEE DETAIL, SHEET AE-1 FOR KEYPAD/OPERATOR INFORMATION.
- 11 UNIT IS LOCATED ABOVE CEILING AND BELOW ROOF.
- 12 GRINDER PUMP STATION VAULT IS LOCATED IN APPROX. LOCATION. REFER TO CIVIL DWG. SC-9.
- 13 INSTALL FLOOR BOX (FLUSH MOUNT) WITH DUPLEX RECEPTACLE AND PHONE/DATA RECEPTACLE FOR PORTABLE COMPUTER/AV PROJECTOR. COVER PLATE TO BE BRASS WITH FOLD DOWN RECEPTACLE COVERS.
- 14 INSTALL EXTERIOR CAMERA JUNCTION BOX 9' ABOVE GRADE. ROUTE EMPTY 3/4" CONDUIT, WITH PULL STRING, ABOVE CEILING TO PHONE BOARD IN ELECTRICAL ROOM.
- 15 INSTALL CAMERA J-BOX ABOVE CEILING FOR CEILING MOUNT CAMERA. ROUTE EMPTY 3/4" CONDUIT, WITH PULL STRING, ABOVE CEILING TO PHONE BOARD IN ELECTRICAL ROOM.
- 16 INSTALL 4" PVC CONDUIT UNDERGROUND FROM TELEPHONE BOARD SOUTH TO FENCE LINE. SEE SHEET SE-4 FOR ADDITIONAL INFORMATION. CONTACT BARRY WILSON, AT&T AT (918) 596-6368 FOR UTILITY COORDINATION. COORDINATE WITH CIVIL SITE PLAN SE-4. CONTACT BARRY WILSON OF AT&T (918) 596-6368 FOR UTILITY COORDINATION.
- 17 MINIMUM CLEAR DISTANCE BETWEEN MDP AND ANY EQUIPMENT IN FRONT OF PANEL IS 42"

SEE SITE PLAN SE-4
FOR DUCT BANK PATH
FROM GRINDER TO
OPERATIONS BUILDING.


ALL ELECTRICAL WORK
IN GRINDER VAULT AND
WITHIN 3' OF LID TO
BE CLASS 1, DIV. 2
GROUP D.

ELECTRICAL - POWER PLAN
SCALE: 1/4"=1'-0"

LOWER BIRD CREEK WWT EXPANSION TMAA PROJECT NO. ES 2006-01 CONTRACT 1B			
OPERATIONS BUILDING ELECTRICAL POWER PLAN			
CITY OF TULSA, OKLAHOMA TULSA METROPOLITAN UTILITY AUTHORITY ENGINEERING SERVICES DEPARTMENT			
PLANS AND ESTIMATES PREPARED BY:			
BLACK & VEATCH Building a world of difference Kansas City, Missouri		Hatchery, Updegraff and Sellen Consulting Engineers Managers - Broken Arrow	
BVGATES Engineers Broken Arrow			

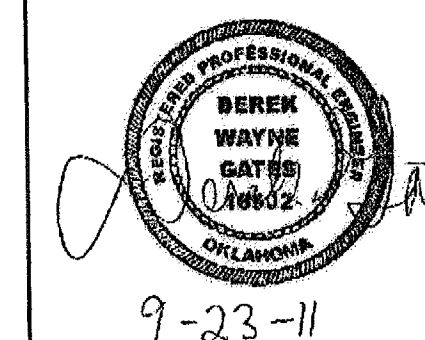

REVISION	BY	DATE	PLAN SCALE:	DRAWN	FLT	APPROVED:
Attention No. 10	PSB	1-1-12	DESIGNED	AC		
			SURVEY			
			PROFILE SCALE:	FIELD MGR.	7/08	10/11
			HORIZONTAL:	SECT. MGR.	2/09	10/11
			VERTICAL:	PROJ. MGR.	10/11	10/11
			RECOMMENDED:			
			FILE: AE02	DRAWING: AE-2	DATE 10/28/2011	
			ATLAS PAGE NO:		SHEET 184 OF 261 SHEETS	

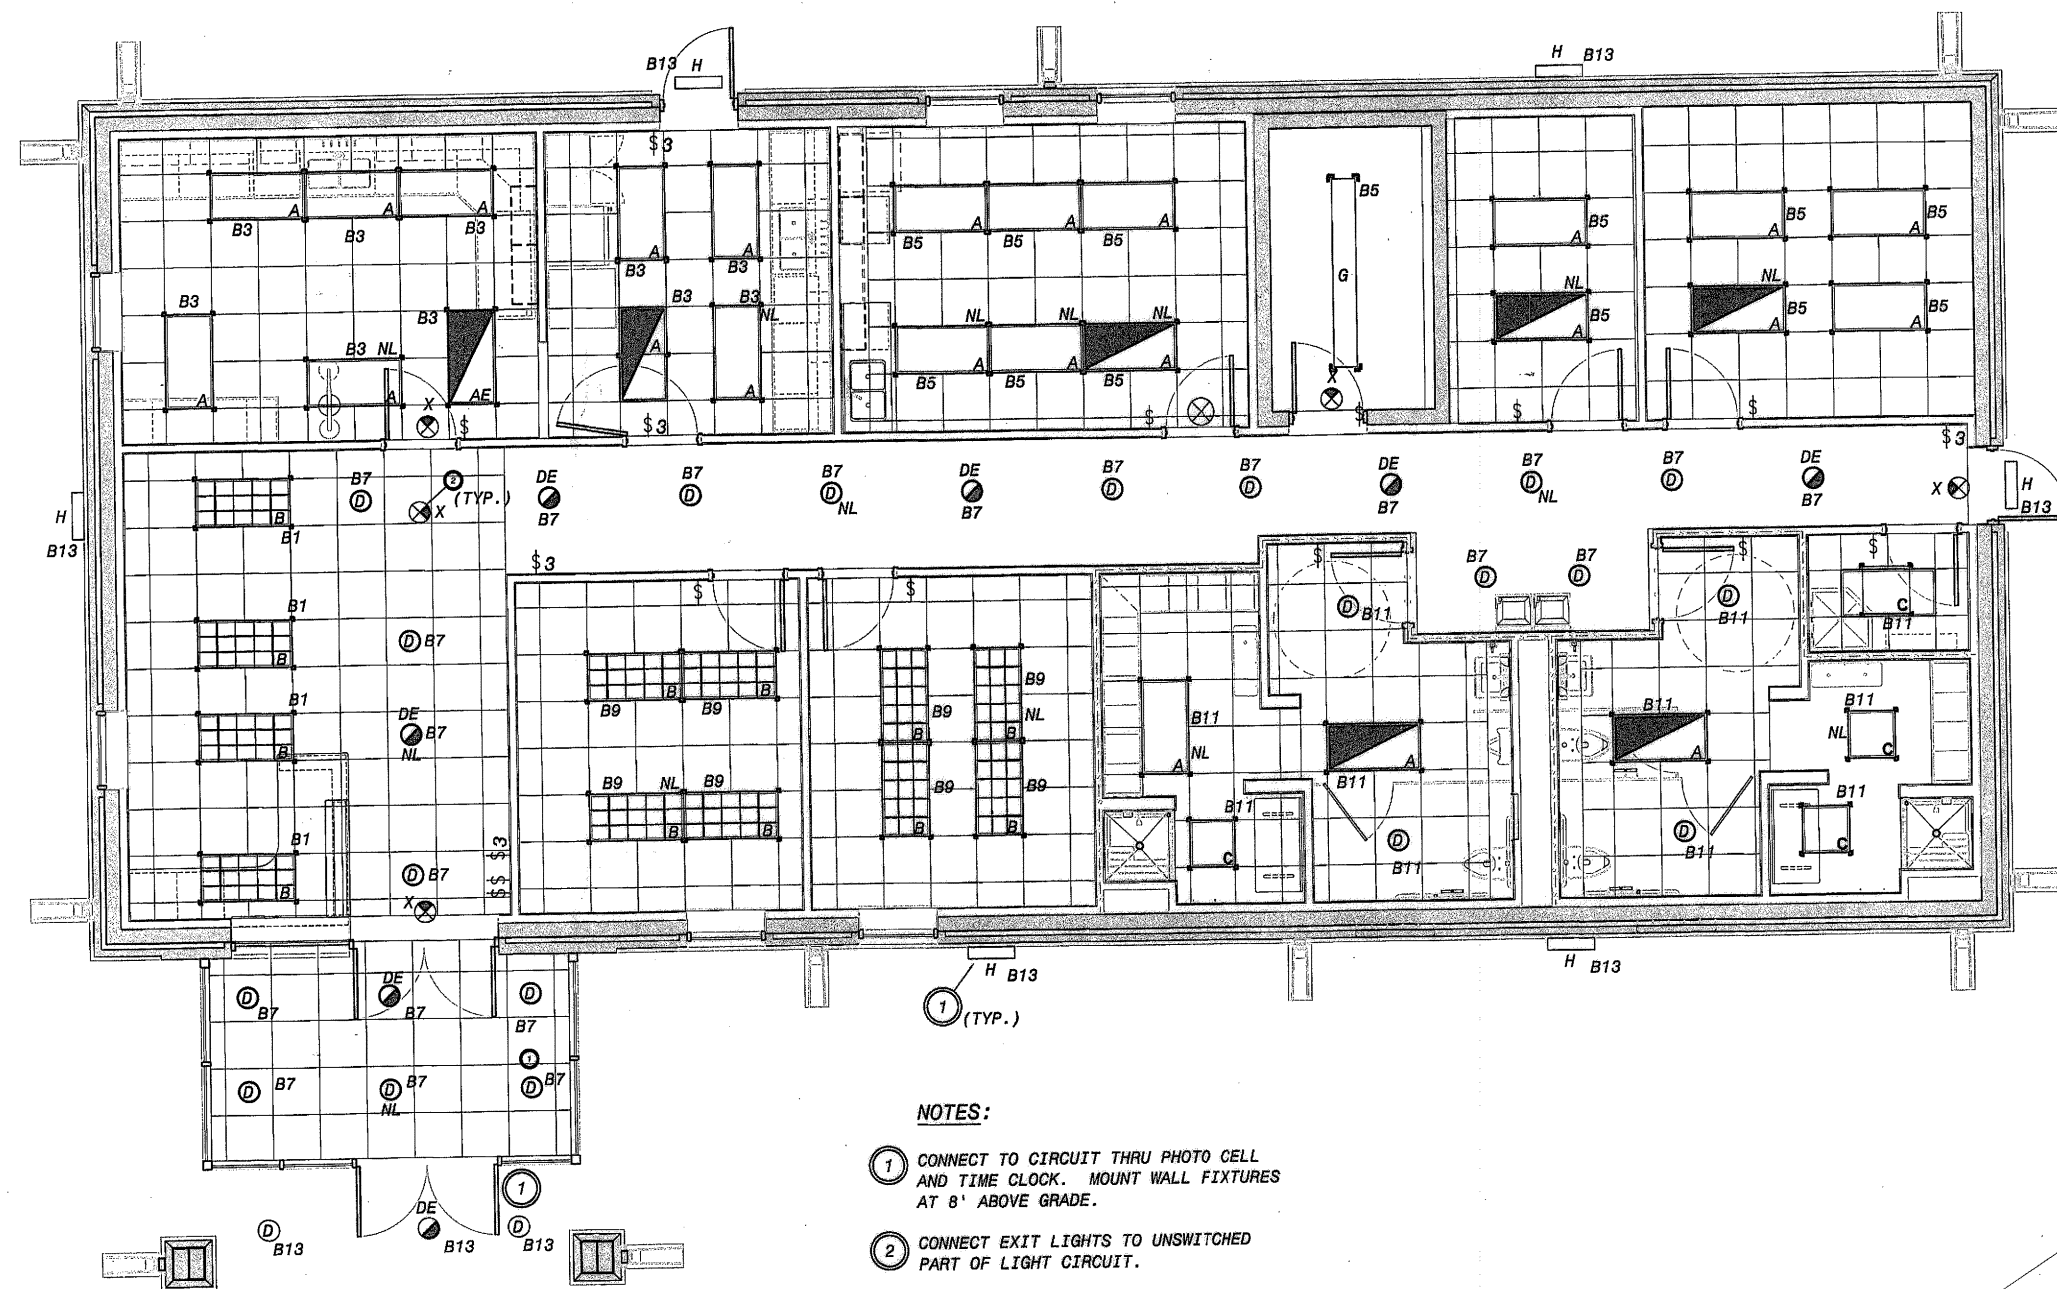


- NOTES:**
- ① CONNECT TO CIRCUIT THRU PHOTO CELL AND TIME CLOCK. MOUNT WALL FIXTURES AT 8' ABOVE GRADE.
 - ② CONNECT EXIT LIGHTS TO UNSWITCHED PART OF LIGHT CIRCUIT.
 - ③ CONNECT NIGHT LIGHT (NL) TO UNSWITCHED PORTION OF CIRCUIT.

LIGHTING PLAN
SCALE: 1/4"=1'-0"

LOWER BIRD CREEK WWTP EXPANSION
TMUA PROJECT NO. ES 2006-01
CONTRACT 1B
OPERATIONS BUILDING
ELECTRICAL
LIGHTING PLAN
CITY OF TULSA, OKLAHOMA
TULSA METROPOLITAN UTILITY AUTHORITY
ENGINEERING SERVICES DEPARTMENT

PLANS AND ESTIMATES PREPARED BY:
BLACK & VEATCH
Building a world of difference
Kansas City, Missouri

REVISION	BY	DATE	PLAN SCALE:	DRAWN	FLT	APPROVED:
				DESIGNED	AC	
				SURVEY		
			PROFILE SCALE:	FIELD MGR.	Yed 10/11	
			HORIZONTAL:	SECT. MGR.	2/24/10/11	
			1" =	PROJ. MGR.		
			VERTICAL	RECOMMENDED:	11/23/10/11	
			1" =			
			FILE: AE03	DRAWING: AE-3	DATE JUN 2011	
			ATLAS PAGE NO:		SHEET 185 OF 261 SHEETS	

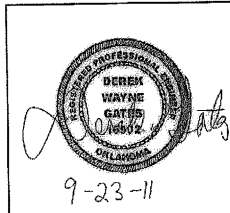

PNL: L001-OPS1-MDP SERVICE: 480V 3PH ISC RATING: 42,000 A.I.C. NO SERIES RATINGS ACCEPTED				PNL TYPE:.. BUS: 400A COPPER WITH GROUND BUS				CAB: SURFACE NEMA 1 MAIN: 225A BREAKER FEED: BOTTOM							
SERVING	WIRE SIZE	AMPS	POLES	CIRC. NO.	PHASE LOADING AMPS						CIRC. NO.	POLES	AMPS	WIRE SIZE	SERVING
					A		B		C						
L001-OPS1-HAU02	12	20	3	1	11.7	94.8					2	3	100	3	TRANSFORMER 75KVA 1Ø L001-OPS1-PNL03
				3			11.7	104.1			4				
				5				11.7	61.3	6					
L001-OPS1-HAU03	12	20	3	7	4.6	22.7					8	3	30	10	L001-OPS1-HAU01
				9			4.6	22.7			10				
				11				4.6	22.7	12					
L001-OPS1-HAU04	12	20	3	13	3.6	6.6					14	3	20	12	L001-OPS1-HAU06
				15			3.6	6.6			16				
				17					3.6	6.6	18				
L001-OPS1-PNL07 GRINDER PANEL	12	20	3	19	10.0	3.0					20	3	20	12	L001-OPS1-HAU07
				21			10.0	3.0			22				
				23					10.0	3.0	24				
SPACE				25		2.4					26	3	20	12	L001-OPS1-HAU05
				27				2.4			28				
				29					2.4		30				
SPACE				31		4.0					32	3	20	12	SITE LIGHTING
				33				4.0			34				
				35					4.0		36				
SPACE				37							38	3	20	12	L001-OPS1-HWH01
				39							40				
				41							42				
TOTALS:					163.4		172.7		129.9						

PNL: L001-OPS1-PNL03					PNL TYPE:.					CAB: SURFACE NEMA 1				
SERVICE 120/208V 3PH 4W					BUS: 225A COPPER					MAIN: 200A BREAKER				
ISC RATING: 22,000 A.I.C.					WITH GROUND BUS					FEED: BOTTOM OR TOP				
NO SERIES RATINGS ACCEPTED														
SERVING	WIRE SIZE	AMPS	POLES	CIRC. NO.	PHASE LOADING AMPS			CIRC. NO.	POLES	AMPS	WIRE SIZE	SERVING		
					A	B	C							
L001-OPS1-PNL04	3	100	3	1	34.6	40.0		2	2	50	6	OVEN (RANGE)		
				3		45.0	40.0		4					
				5				39.7	10.0	6	1	20	10	FRONT GATE
L001-OPS1-HTR01	12	20	2	7	5.6	3.0		8	1	20	12	RECEPTACLES (GFCI)		
				9		5.6	3.0		10	1	20	12	RECEPTACLES (GFCI)	
L001-OPS1-HTR02	12	20	2	11				5.6	3.0	12	1	20	12	RECEPTACLES (GFCI)
				13	5.6	3.0				14	1	20	12	RECEPTACLES (GFCI)
REFRIGERATOR	12	20	1	15			7.0	3.0		16	1	20	12	RECEPTACLES (GFCI)
MICROWAVE	12	20	1	17				8.0	3.0	18	1	20	12	RECEPTACLES (GFCI)
ICE MACHINE	12	20	1	19	5.0	3.0				20	1	20	12	RECEPTACLES (GFCI)
REFRIGERATOR	12	20	1	21			7.0	7.5		22	1	20	12	RECEPTACLES (GFCI)
WASHER	12	20	1	23				5.0		24	1	20	12	FRONT SIGN
SPACE				25						26				SPACE
SPACE				27						28				SPACE
SPACE				29						30				SPACE
SPACE				31						32				SPACE
SPACE				33						34				SPACE
SPACE				35						36				SPACE
SPACE				37						38				SPACE
SPACE				39						40				SPACE
SPACE				41						42				SPACE
TOTALS:					99.8		103.6		74.3					


PNL: L001-OPS1-PNL04					PNL TYPE:..					CAB: SURFACE NEMA 1					
SERVICE 208/120V 3PH 4W					BUS: 100A COPPER					MAIN: 100A M.L.O.					
ISC RATING: 22,000 A.I.C.					WITH GROUND BUS					FEED: BOTTOM OR TOP					
NO SERIES RATINGS ACCEPTED															
SERVING	WIRE SIZE	AMPS	POLES	CIRC. NO.	PHASE LOADING AMPS			CIRC. NO.	POLES	AMPS	WIRE SIZE	SERVING			
					A	B	C								
LIGHTS	12	20	1	1	4.0	4.5			2	1	20	12	RECEPTACLES (GFCI)		
LIGHTS	12	20	1	3			8.3	6.0	4	1	20	12	RECEPTACLES (GFCI)		
LIGHTS	12	20	1	5					10.0	3.0	6	1	20	12	RECEPTACLES (GFCI)
LIGHTS	12	20	1	7	6.5	3.0			8	1	20	12	RECEPTACLES (GFCI)		
LIGHTS	12	20	1	9			6.7	3.0	10	1	20	12	RECEPTACLES (GFCI)		
LIGHTS	12	20	1	11					5.7	3.0	12	1	20	12	RECEPTACLES (GFCI)
LIGHTS	12	20	1	13	4.6	3.0			14	1	20	12	RECEPTACLES (GFCI)		
RECEPTACLES	12	20	1	15			6.0	3.0	16	1	20	12	RECEPTACLES (GFCI)		
RECEPTACLES	12	20	1	17					6.0	3.0	18	1	20	12	RECEPTACLES (GFCI)
RECEPTACLES	12	20	1	19	6.0	3.0			20	1	20	12	RECEPTACLES (GFCI)		
RECEPT'S OUTSIDE(GFCI)	12	20	1	21			7.5	4.5	22	1	20	12	RECEPT'S OUTSIDE(GFCI)		
L001-OPS1-PANEL 01 TIME CLOCK			3	23					24	1	20	12	EW-1 (DRINKING FOUN.)		
				25					26	1	20	12	FLOOR RECEPTACLE		
				27					28	1	20	12	RECEPTACLE (GFCI) DISPOSAL		
L001-OPS1-EHF01	12	20	1	29					1.0	6.0	30	1	20	12	RECEPTACLES (TTB)
SPARE	12	20	1	31					32						SPACE
SPARE	12	20	1	33					34						SPACE
SPARE	12	20	1	35					36						SPACE
SPARE	12	20	1	37					38						SPACE
SPARE	12	20	1	39					40						SPACE
SPARE	12	20	1	41					42						SPACE
TOTALS:					34.6		45.0		39.7						


LIGHTING FIXTURE LEGEND & SCHEDULE

FIXTURE NO.	MANUFACTURER & CATALOG NO.	VOLTS WATTS	LAMPS	MOUNTING	NOTES & REMARKS
A	LIGHTOLIER XP2GVA332UNV	120 96	F32T8/SP41/ECO	RECESSED	
AE	LIGHTOLIER XP2GVA332UNV-FBP50	120 96	F32T8/SP41/ECO	RECESSED	1350 LUMEN EM BALLAST
B	LIGHTOLIER PLA2G18LS332UNVH3GLR	120 96	F32T8	RECESSED	
C	LIGHTOLIER XP2GVA26U-UNVH3GLR	120 52	2T8U6	RECESSED	
D	LIGHTOLIER 1001HCD/1001F26	120 28	F26TBX/841/A/ECO	RECESSED	
DE	LIGHTOLIER 1001HCD/1001F26EM	120 28	F26TBX/841/A/ECO	RECESSED	EM BALLAST
F	LIGHTOLIER	120 64	F32T8 - (2) LAMPS	SURFACE	WIRE GUARD
G	LIGHTOLIER SWT8T232HPF-AWG3W-CSP	120 128	F32T8 - (4) LAMPS	SURFACE	WIRE GUARD
H	EXCELINE GXSW42HFLBRW1	120 42	GXSW42HFLBRW1	SURFACE	OUTSIDE WALL PACK
X	LIGHTOLIER LLNCRW	120 5	LED	SURFACE	

LOWER BIRD CREEK WWTP EXPANSION TMAA PROJECT NO. ES 2006-01 CONTRACT 1B			
OPERATIONS BUILDING ELECTRICAL SCHEDULES			
CITY OF TULSA, OKLAHOMA TULSA METROPOLITAN UTILITY AUTHORITY ENGINEERING SERVICES DEPARTMENT			
PLANS AND ESTIMATES PREPARED BY:			
BLACK & VEATCH Building a world of difference	Holloway, Upshaw and Bolton Consulting Engineers Muskogee - Broken Arrow		APPROVED:
PLAN SCALE:	DRAWN:	FLT:	DESIGNED:
SURVEY:	FIELD MGR:	10/11	AC:
PROFILE SCALE:	SECT. MGR:	10/11	PROJ. MGR:
HORIZONTAL:	RECOMMENDED:	10/11	DIRECTOR:
VERTICAL:	FILE: AE04	DRAWING: AE-4	DATE 10/28/2011
ATLAS PAGE NO:	SHEET 186 OF 261 SHEETS	B&V PROJECT NO. 145120	

ELECTRICAL - SCHEDULES
SCALE: NONE

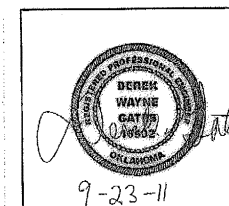

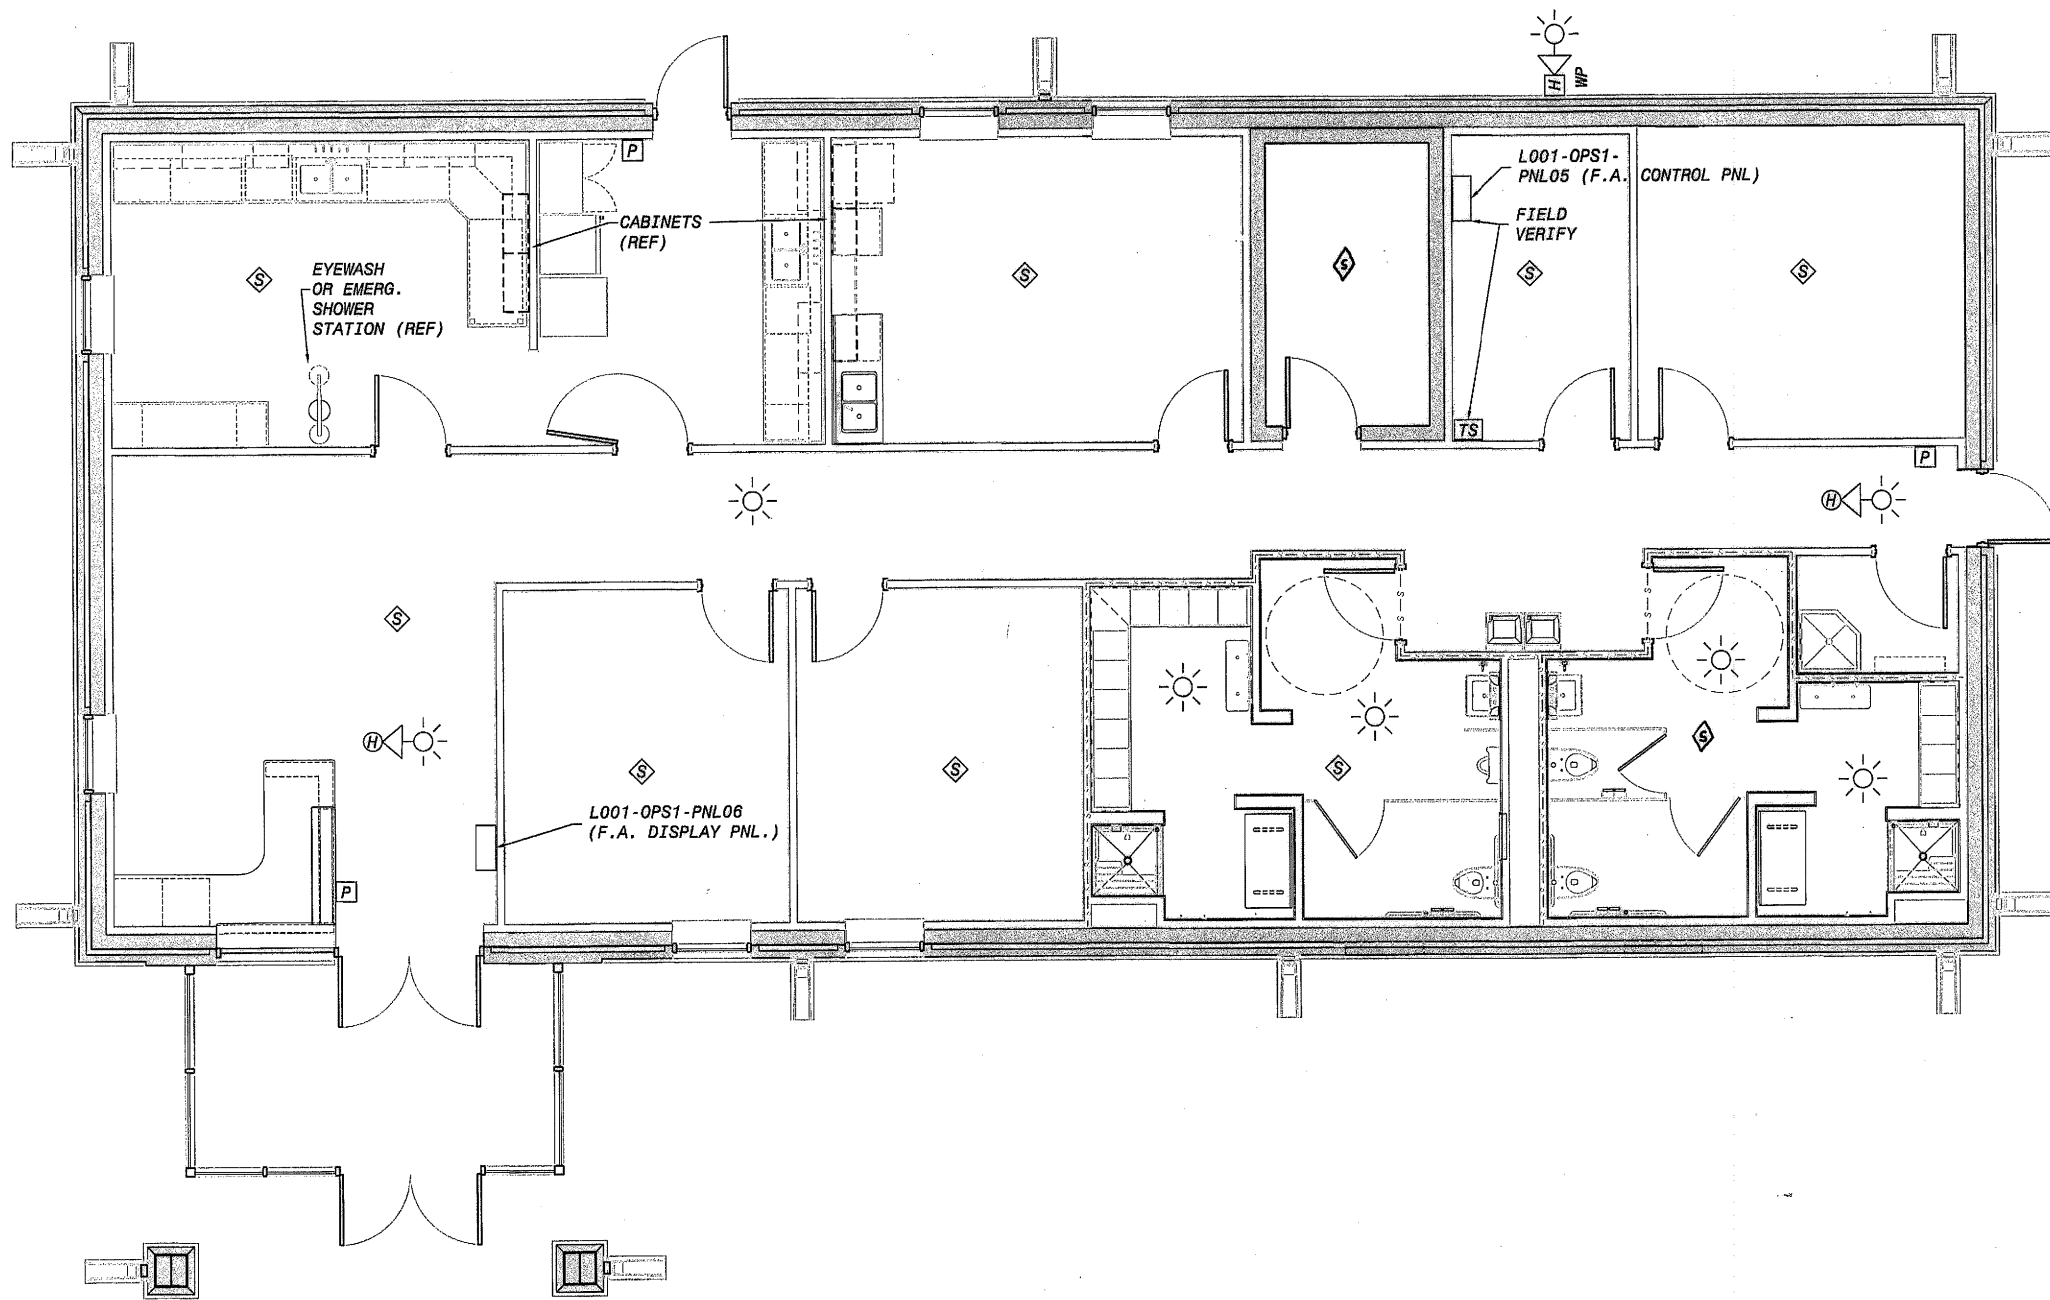

FIRE ALARM - SYMBOL LEGEND	
	FIRE ALARM DISPLAY
	TAMPER SWITCH
	PULL STATION
	STROBE, CEILING MOUNTED
	CEILING MOUNTED HORN-STROBE
	SMOKE DETECTOR
	CEILING MOUNTED HORN-STROBE
	FIRE ALARM CONTROL PANEL (REMOTE)


FOR REFERENCE IN CASE OF CONFLICT
WITH SPECIFICATIONS,
SPECIFICATIONS SHALL APPLY.

FIRE PROTECTION PLAN
SCALE: 1/4"=1'-0"

LOWER BIRD CREEK WWTP EXPANSION
TMUA PROJECT NO. ES 2006-01
CONTRACT 1B
OPERATIONS BUILDING
ELECTRICAL
FIRE PROTECTION PLAN
CITY OF TULSA, OKLAHOMA
TULSA METROPOLITAN UTILITY AUTHORITY
ENGINEERING SERVICES DEPARTMENT

PLANS AND ESTIMATES PREPARED BY:
BLACK & VEATCH
Building a world of difference
Holloway, Uppike and Bell
Consulting Engineers
Mechanical - Electrical - Structural
Black & Veatch Corporation
Tulsa City, Oklahoma

 9-23-11	REVISION	BY	DATE	PLAN SCALE:	DRAWN	FLT	APPROVED:
--	----------	----	------	-------------	-------	-----	---

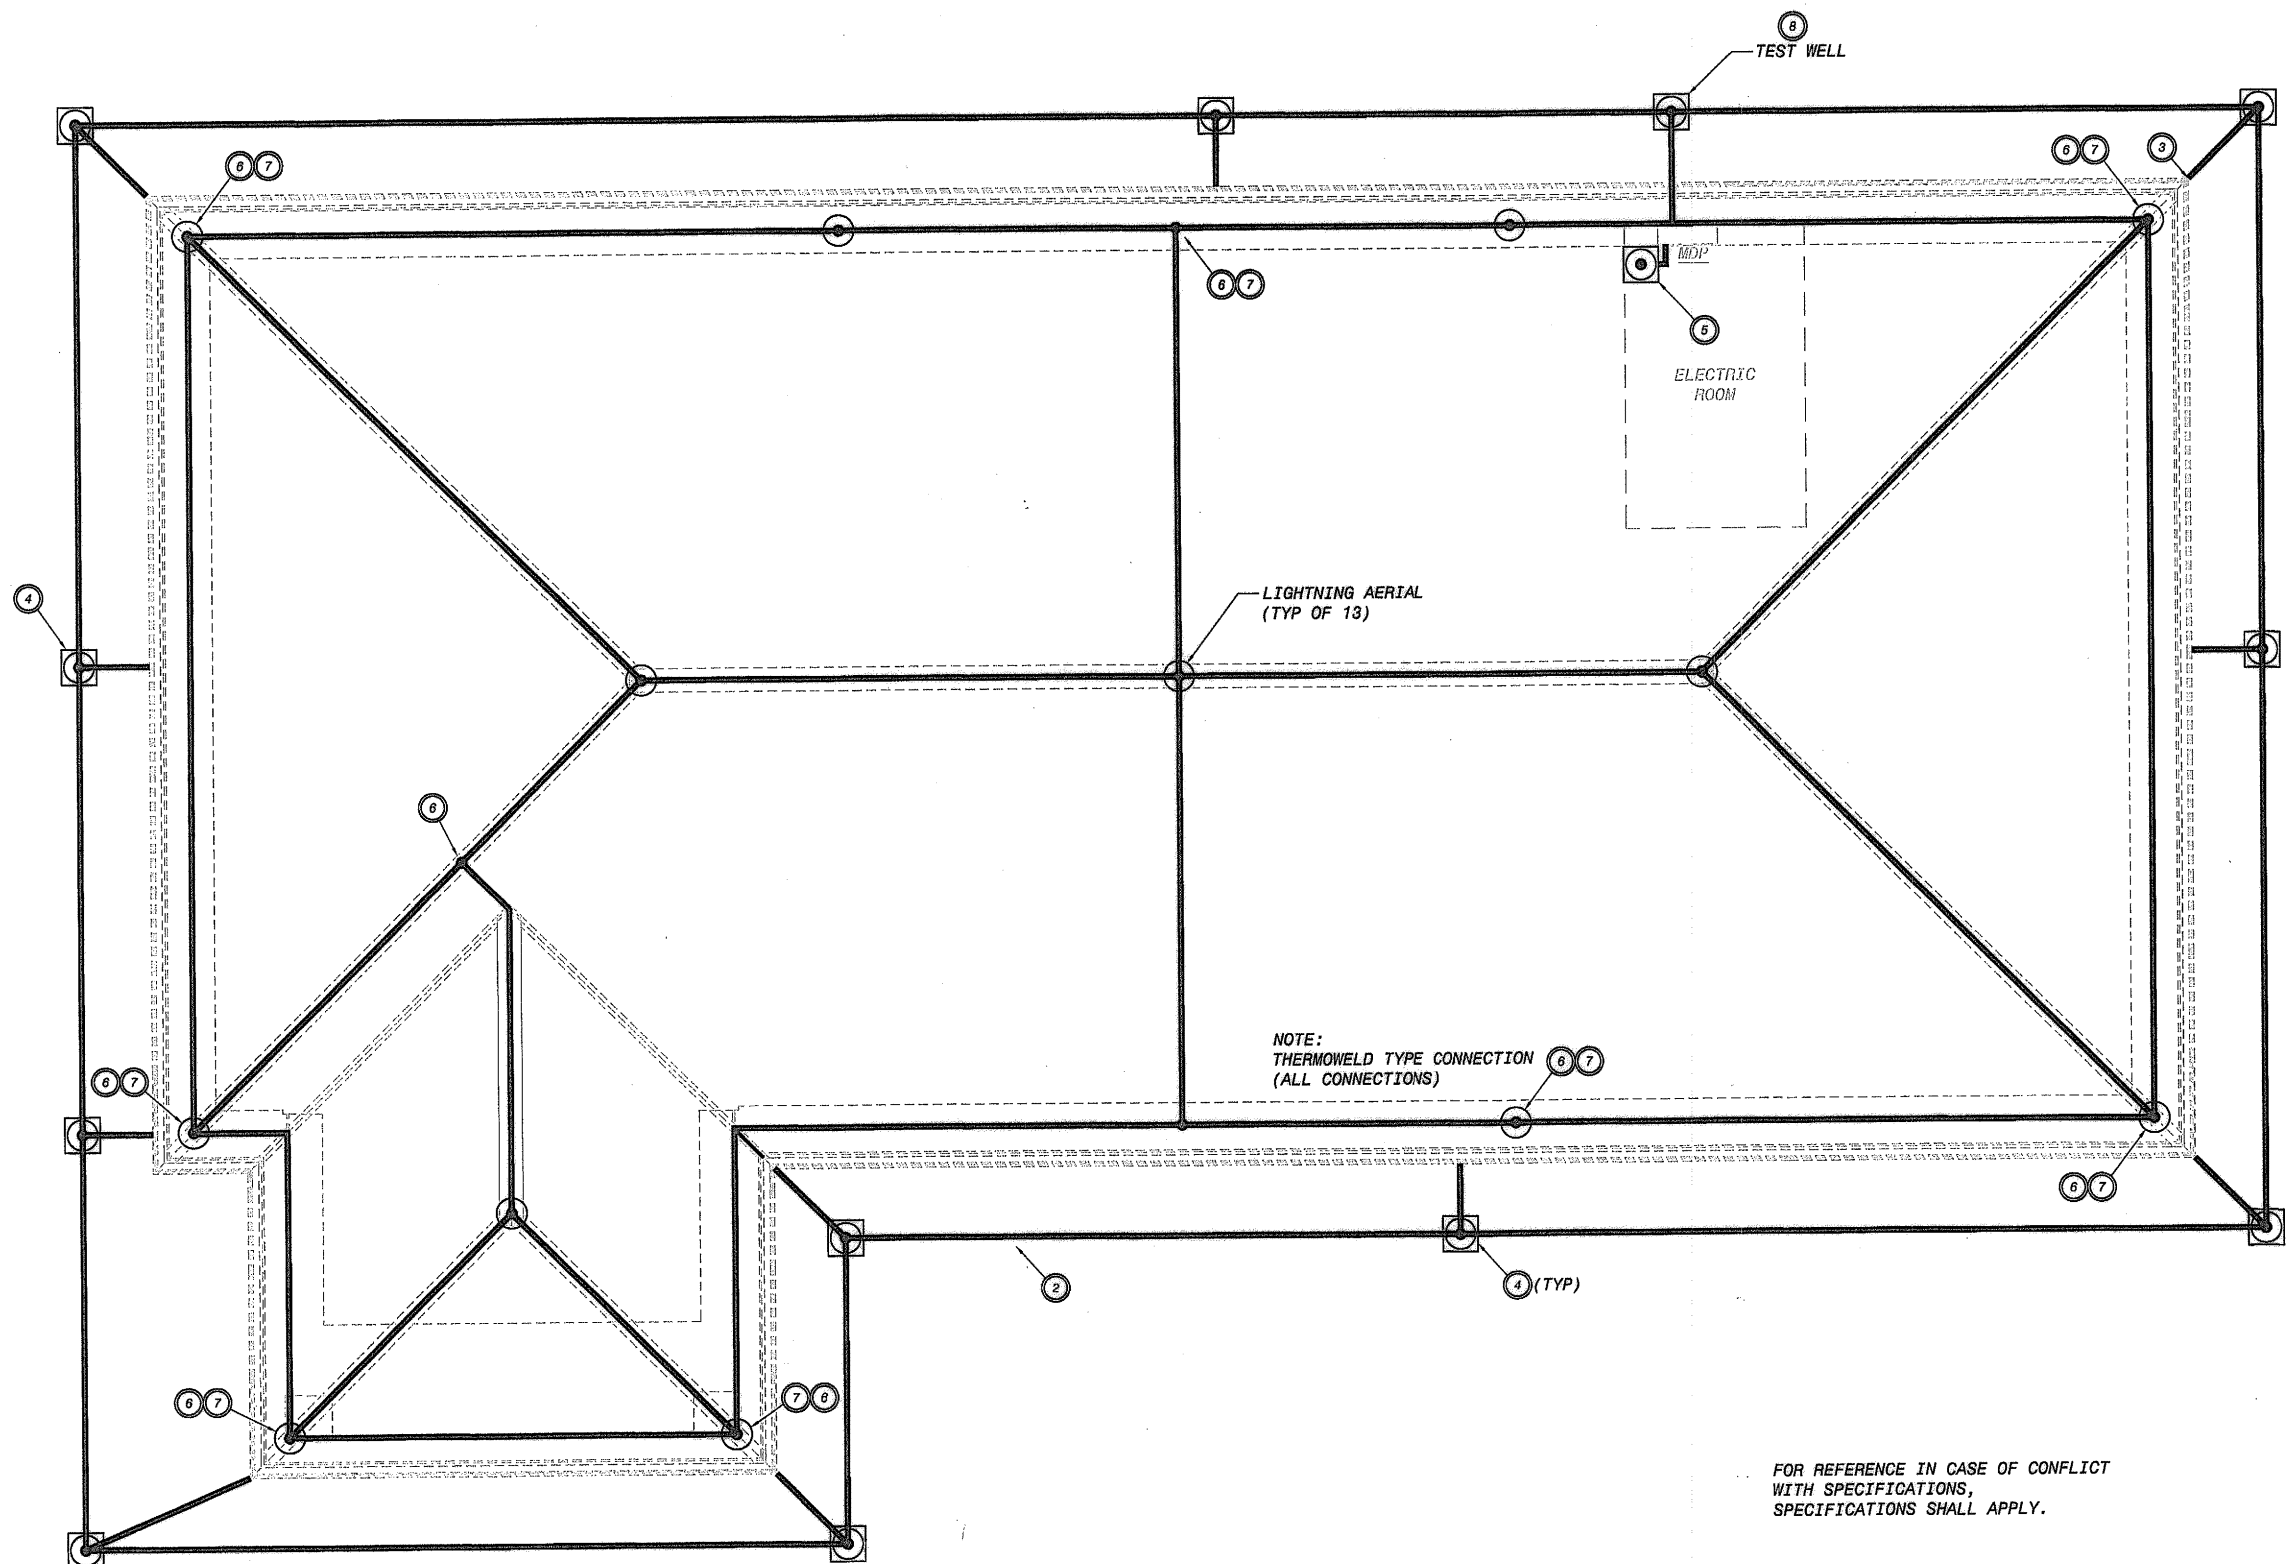

- NOTES:**
- SEE SPECIFICATION SECTION 16050 FOR DETAILS ON GROUNDING MATERIAL AND INSTALLATION.
 - INSTALL BARE STRANDED 4/0 CU, 18" BELOW FINAL GRADE.
 - EXOTHERMIC WELD, TYPICAL
 - EXOTHERMIC WELD GROUND ROD TO CONDUCTOR(S)
 - IN ELECTRICAL ROOM, BOND 4/0 GROUND CONDUCTOR FROM GROUND LOOP TO GROUND BAR IN MDP. ALSO INSTALL GROUND ROD IN THE ELECTRICAL ROOM AND BOND CONDUCTOR TO GROUND BUS IN MDP. BOND TO BUILDING STEEL AND COLD WATER PIPE TO MDP GROUND BUS ALSO.
 - FURNISH AND INSTALL 4/0 COPPER DOWN CONDUCTOR IN 1" SCHEDULE 40 PVC IMBEDDED IN WALL. STUB OUT 18" BELOW FINAL GRADE AND BELOW ROOF INSIDE BUILDING. USE THRU-ROOF ASSEMBLY THAT IS SUITABLE FOR ROOF SYSTEM. COORDINATE WITH ARCH.
 - CONNECT DOWN CONDUCTOR TO GROUNDING SYSTEM WITH THERMOWELD TYPE CONNECTION.
 - INSTALL AND CONNECT GROUND TEST WELL WITH THERMOWELD TYPE CONNECTION.

- SYMBOLS:**
- ⊙ GROUND ROD
 - ⊙ LIGHTNING ARRESTOR
 - THERMOWELD CONNECTION

NOTE:
THERMOWELD TYPE CONNECTION
(ALL CONNECTIONS)

FOR REFERENCE IN CASE OF CONFLICT
WITH SPECIFICATIONS,
SPECIFICATIONS SHALL APPLY.

LIGHTNING PROTECTION AND GROUNDING PLAN
SCALE: 1/4"=1'-0"

LOWER BIRD CREEK WWTP EXPANSION
TMUA PROJECT NO. ES 2006-01
CONTRACT 1B

OPERATIONS BUILDING
ELECTRICAL
LIGHTNING PROTECTION AND GROUNDING PLAN

CITY OF TULSA, OKLAHOMA
TULSA METROPOLITAN UTILITY AUTHORITY
ENGINEERING SERVICES DEPARTMENT

PLANS AND ESTIMATES PREPARED BY:

BLACK & VEATCH
Building a world of difference
Black & Veatch Corporation
Kansas City, Missouri

Holloway, Updike and Ballen
Engineering Engineers
Managers - Broken Arrow


ORIGATES
Engineering Services

	REVISION	BY	DATE	PLAN SCALE:	DRAWN	FLT	APPROVED:
					DESIGNED	AC	
					SURVEY		
					FIELD MGR.	7/28 10/11	
				PROFILE SCALE:	SECT. MGR.	10/28/11	
				HORIZONTAL:	PROJ. MGR.	10/28/11	
				RECOMMENDED:			
				VERTICAL:			
				FILE: AE06	DRAWING: AE-6	DATE 10/28/2011	SHEET 188 OF 261 SHEETS
				ATLAS PAGE NO:			


PLOTTED DATE: 9/27/2011 5:18:11 PM
 SAVED DATE: 9/27/2011 5:18:11 PM
 C:\NET ID: 145120\DWG

9-23-11

(GRINDER PUMP STATION CONTROL PANEL)
L001-OPS1-PNL07

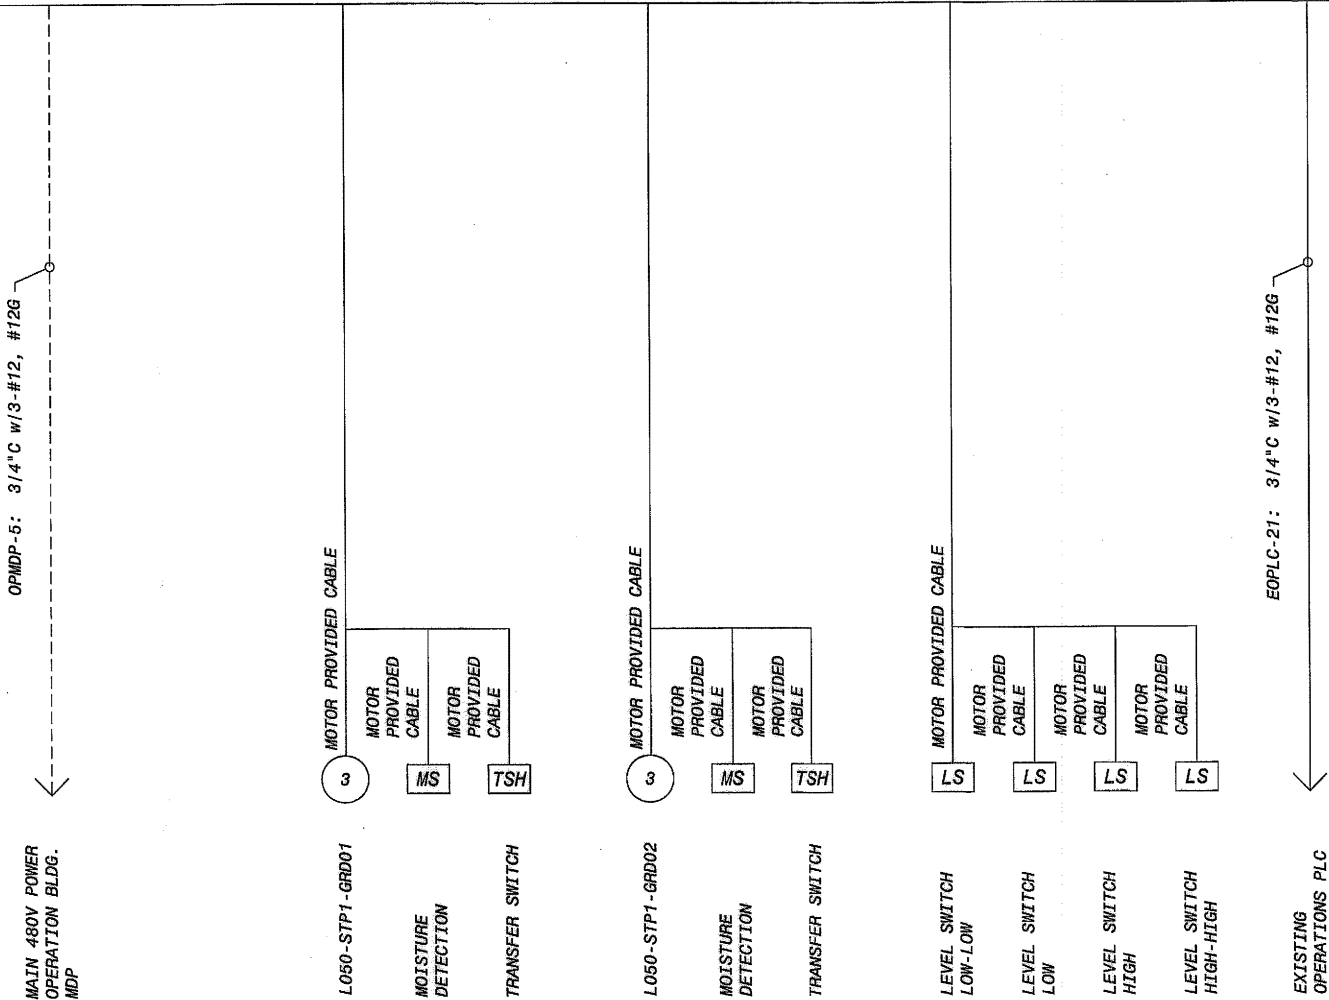

ONE-LINE DIAGRAM
SCALE: NONE

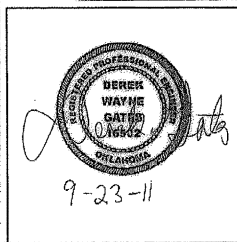

REVISION	BY	DATE	PLAN SCALE:	DRAWN	SS	APPROVED:
				DESIGNED	AC	
				SURVEY		
			PROFILE SCALE:	FIELD MGR.	700 w/11	
			HORIZONTAL:	SECT. MGR.	100 w/11	
			VERTICAL:	PROJ. MGR.	100 w/11	
				RECOMMENDED:	100 w/11	
			FILE: AE07	DRAWING: AE-7	DATE 10/28/2011	
			ATLAS PAGE NO:		SHEET 189 OF 261 SHEETS	

LOWER BIRD CREEK WWTP EXPANSION
TMUA PROJECT NO. ES 2006-01
CONTRACT 1B

OPERATIONS BUILDING
ELECTRICAL
ONE-LINE DIAGRAM

CITY OF TULSA, OKLAHOMA
TULSA METROPOLITAN UTILITY AUTHORITY
ENGINEERING SERVICES DEPARTMENT


PLANS AND ESTIMATES PREPARED BY:

BLACK & VEATCH
Building a world of difference


Stationery, Update and Reprint
Consulting Engineers
Mechanical - Electrical - Plumbing

BLACK & VEATCH CORPORATION
Kansas City, Missouri


ORIGATE
Engineering Services

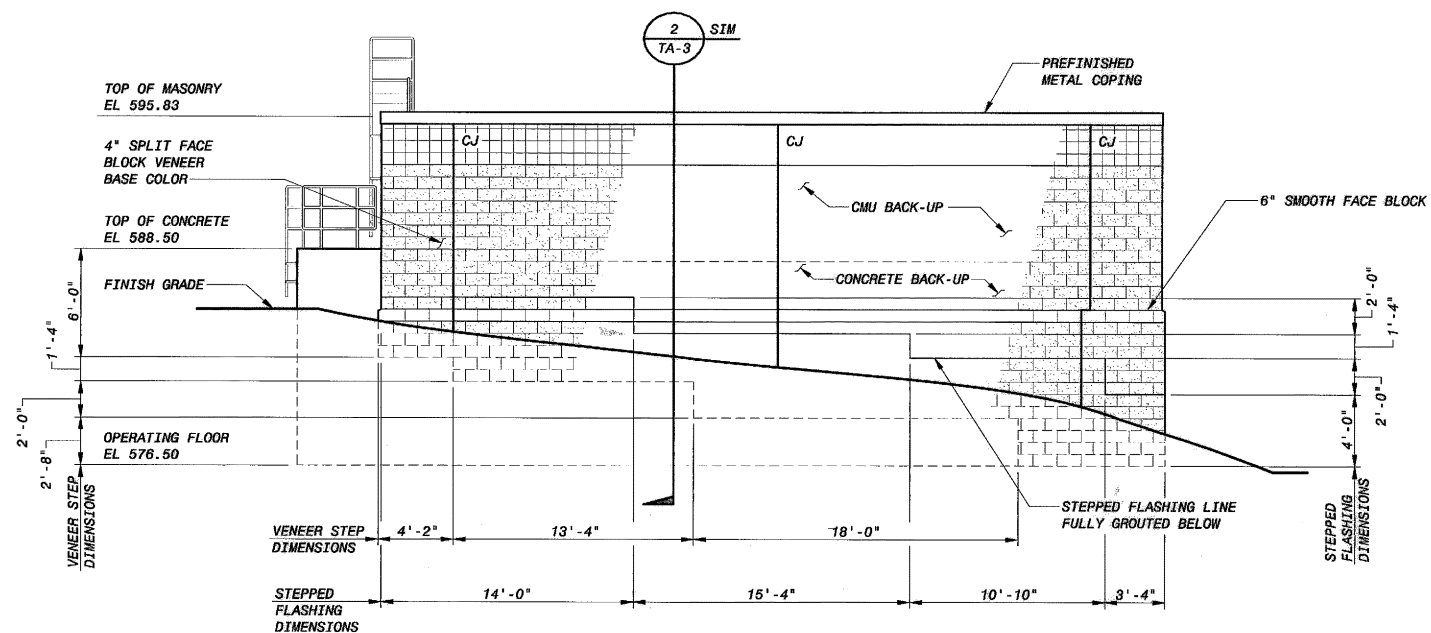


EAST ELEVATION
3/16" = 1'-0"

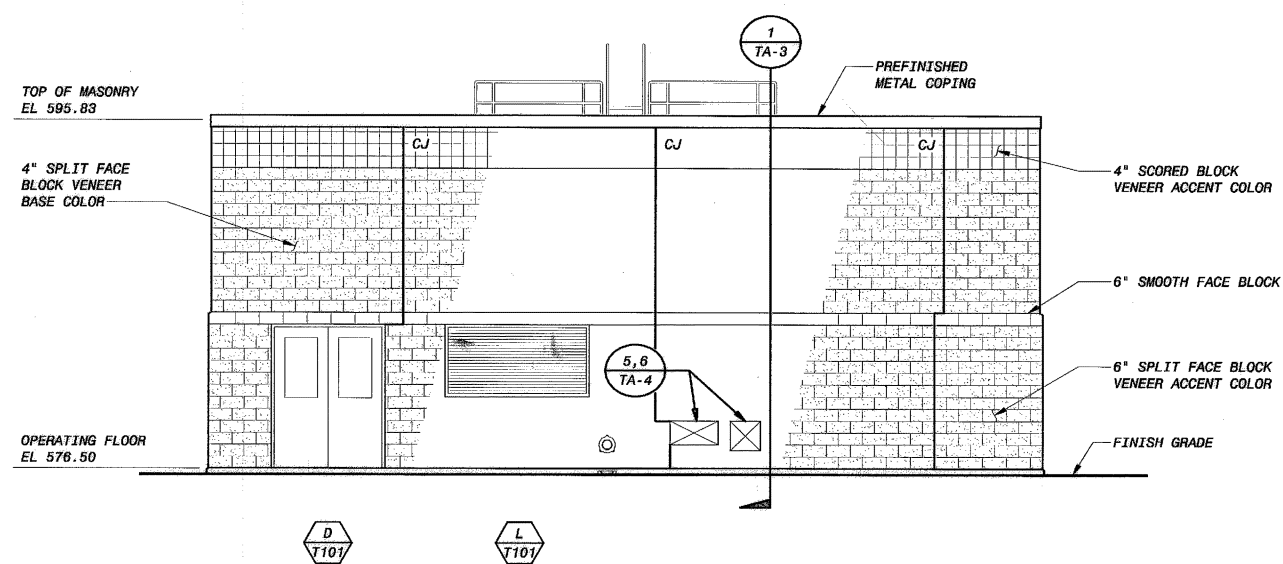

NORTH ELEVATION
3/16" = 1'-0"

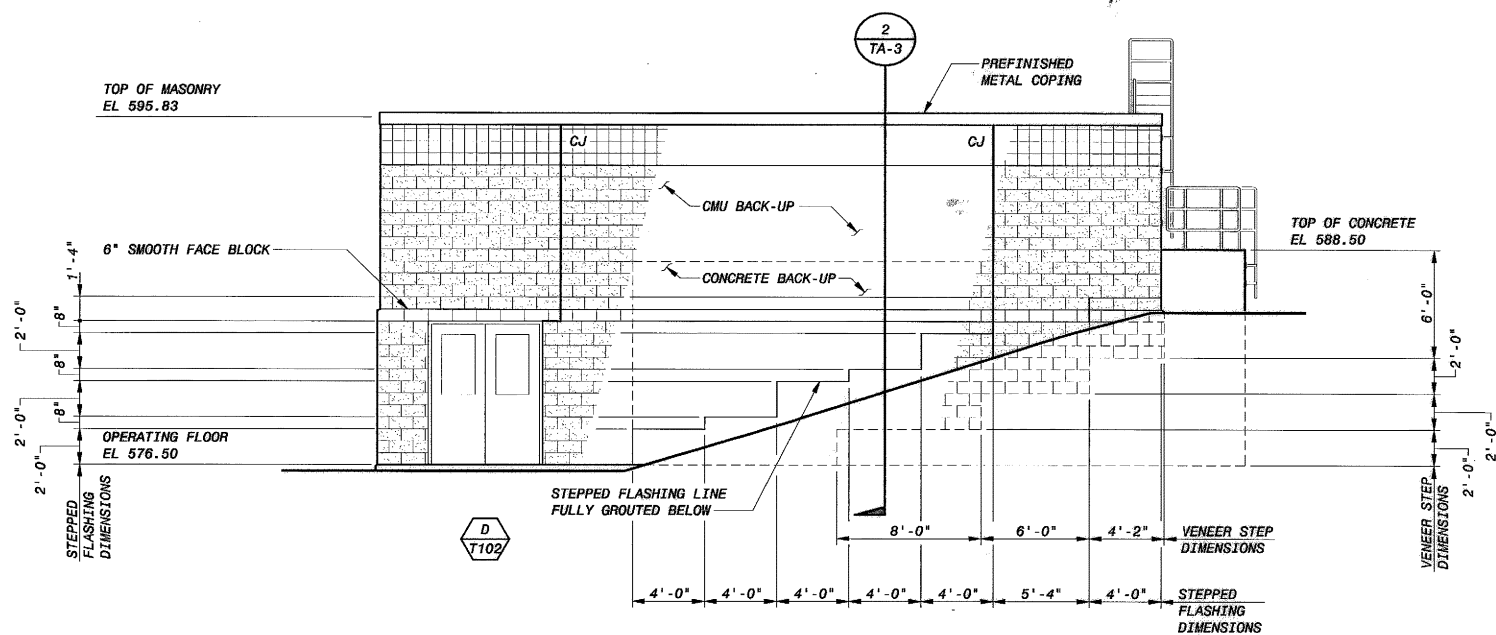


WEST ELEVATION
3/16" = 1'-0"

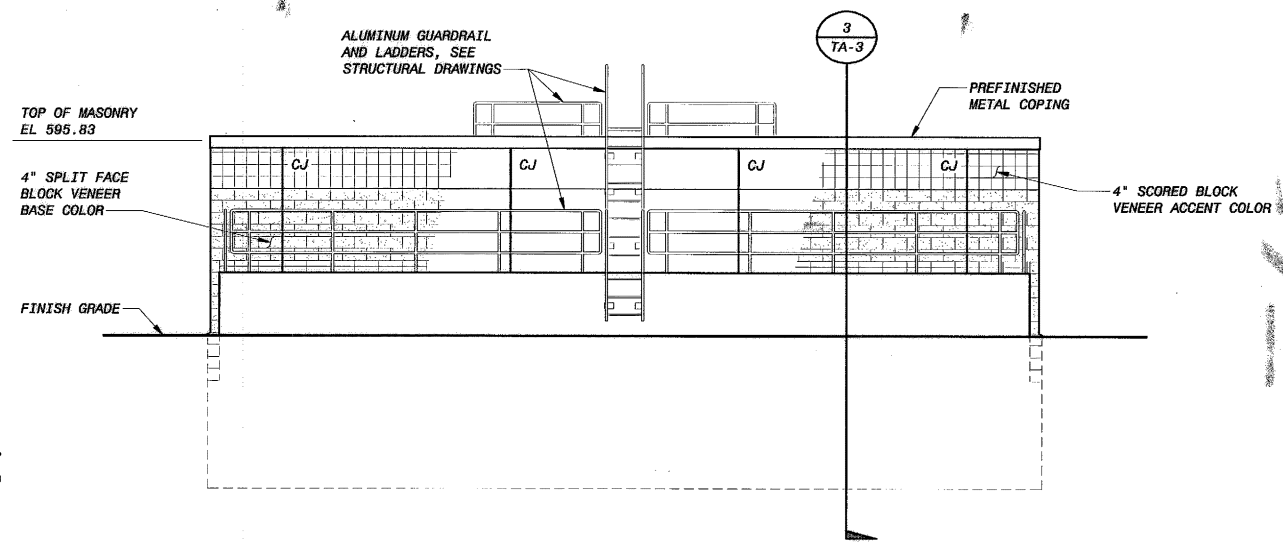


SOUTH ELEVATION
3/16" = 1'-0"



 
- NOTES:**
1. VENEER FACE BLOCK CONTROL JOINT (CJ).
SEE STRUCTURAL DRAWINGS
FOR BACKUP CONCRETE MASONRY UNITS (CMU) WALL
CONTROL JOINT LOCATIONS.




LOWER BIRD CREEK WWTP EXPANSION TMUA PROJECT NO. ES 2006-01 CONTRACT 1B			
SLUDGE TRANSFER PUMP STATION ARCHITECTURAL BUILDING ELEVATIONS			
CITY OF TULSA, OKLAHOMA TULSA METROPOLITAN UTILITY AUTHORITY ENGINEERING SERVICES DEPARTMENT			
PLANS AND ESTIMATES PREPARED BY:			
BLACK & VEATCH Building a world of difference		McIlroy, Updegraff and Ballen Consulting Engineers Managers - Broken Arrow	
Black & Veatch Corporation Kansas City, Missouri		OWGATES Engineering Services	
PLAN SCALE: DRAWN DESIGNED SURVEY	MDE PDR	APPROVED:	
PROFILE SCALE: FIELD MGR. HORIZONTAL: 1" = PROJ. MGR. VERTICAL: 1" =	TDS 10/11 PW 10/11 HOS 10/11	DATE 10/28/2011	
FILE: TA-01 ATLAS PAGE NO:	DRAWING: TA-1	SHEET 190 OF 261 SHEETS	

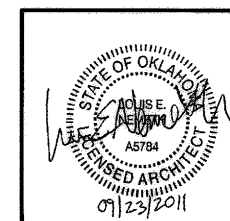

REVISION	BY	DATE

 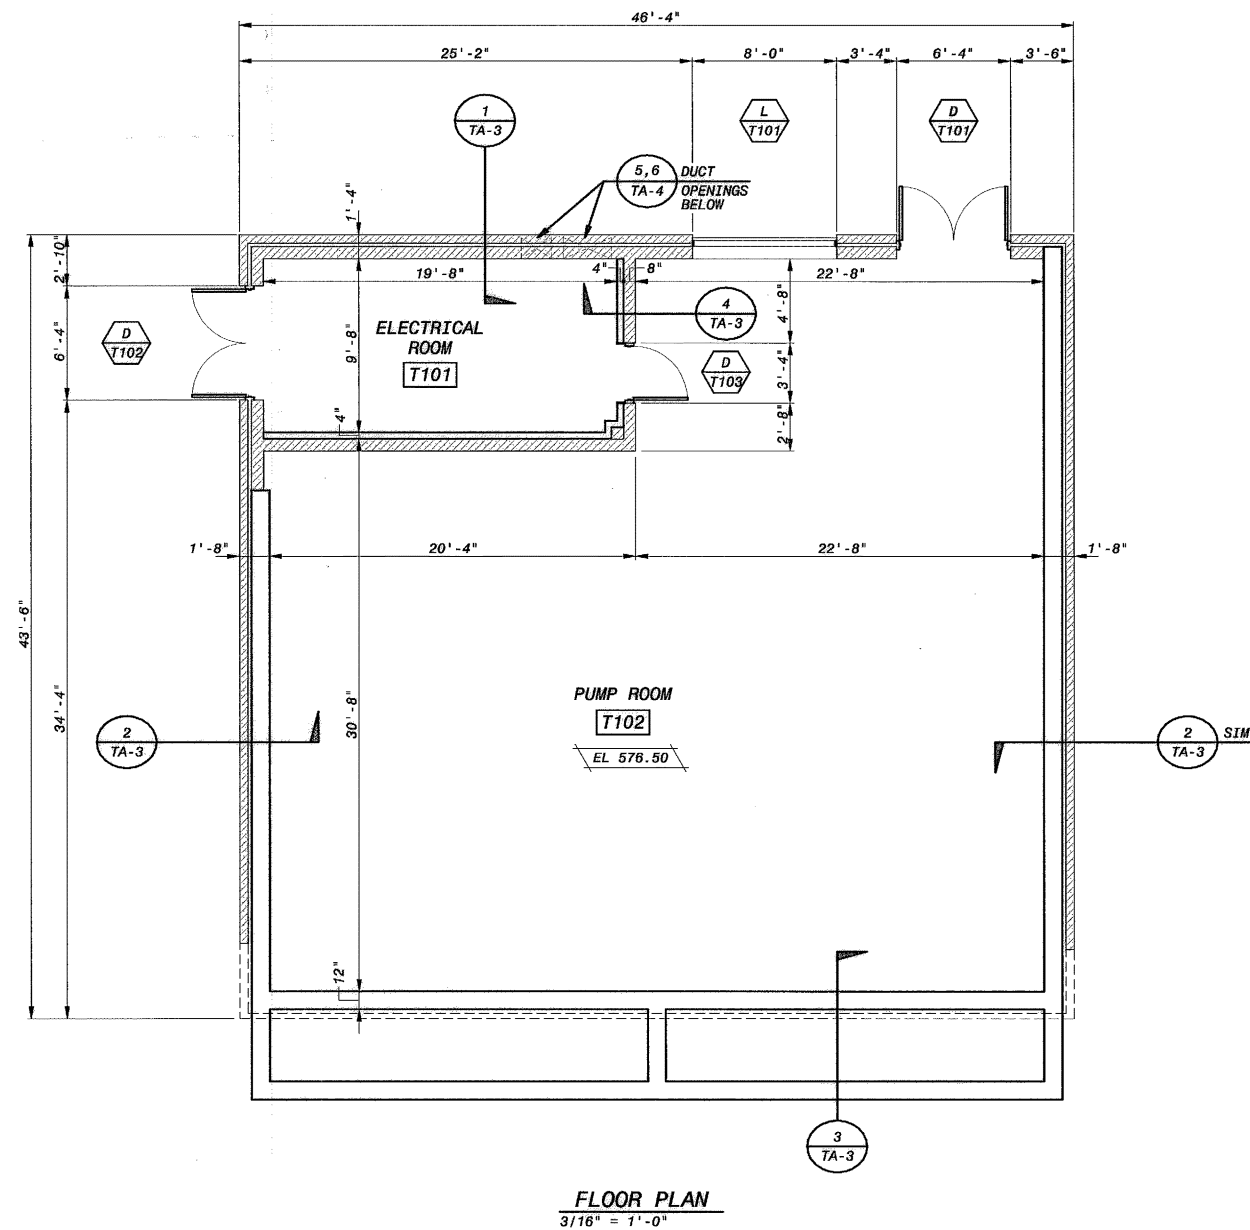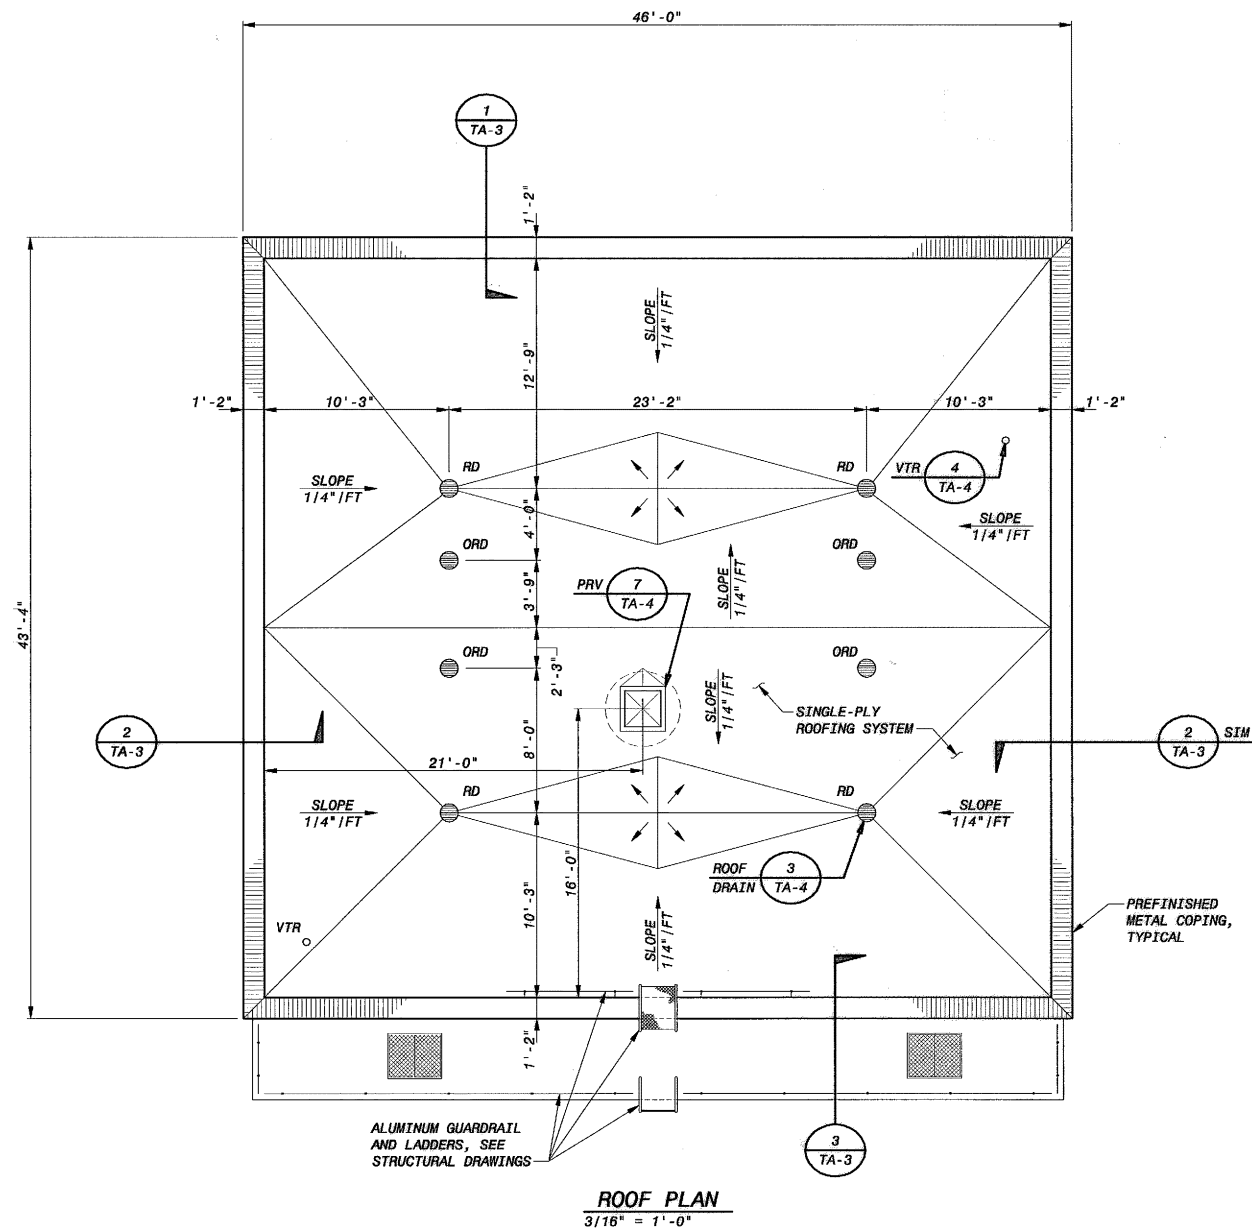


LOWER BIRD CREEK WWTP EXPANSION TMUA PROJECT NO. ES 2006-01 CONTRACT 1B			
SLUDGE TRANSFER PUMP STATION ARCHITECTURAL FLOOR PLAN AND ROOF PLAN			
CITY OF TULSA, OKLAHOMA TULSA METROPOLITAN UTILITY AUTHORITY ENGINEERING SERVICES DEPARTMENT			
PLANS AND ESTIMATES PREPARED BY:			
BLACK & VEATCH Building a world of difference		Holloway, Updeke and Sellen Consulting Engineers Mustang, Oklahoma	
Black & Veatch Corporation Kansas City, Missouri		DUGANES Engineering Services	
PLAN SCALE: DRAWN DESIGNED SURVEY	MDE PDR	APPROVED:	
PROFILE SCALE: FIELD MGR. SECT. MGR.	7/23 10/11 10/3/11	DIRECTOR	
HORIZONTAL: 1" =	PROJ. MGR. 10/3/11	DATE 10/28/2011	
VERTICAL: 1" =	10/3/11	SHEET 191 OF 261 SHEETS	
FILE: TA-02 ATLAS PAGE NO:		DRAWING: TA-2 B&V PROJECT NO. 145120	

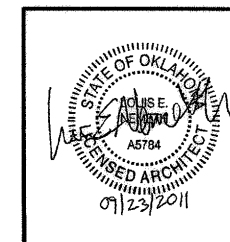


REVISION	BY	DATE


PLOTTED DATE: EDM7043, 9/21/2011 9:10:21 AM
 SAVED DATE: EDM7043, 9/20/2011 2:51:02 PM
 CREDIT ID: 145120-3000-A-00000000-17

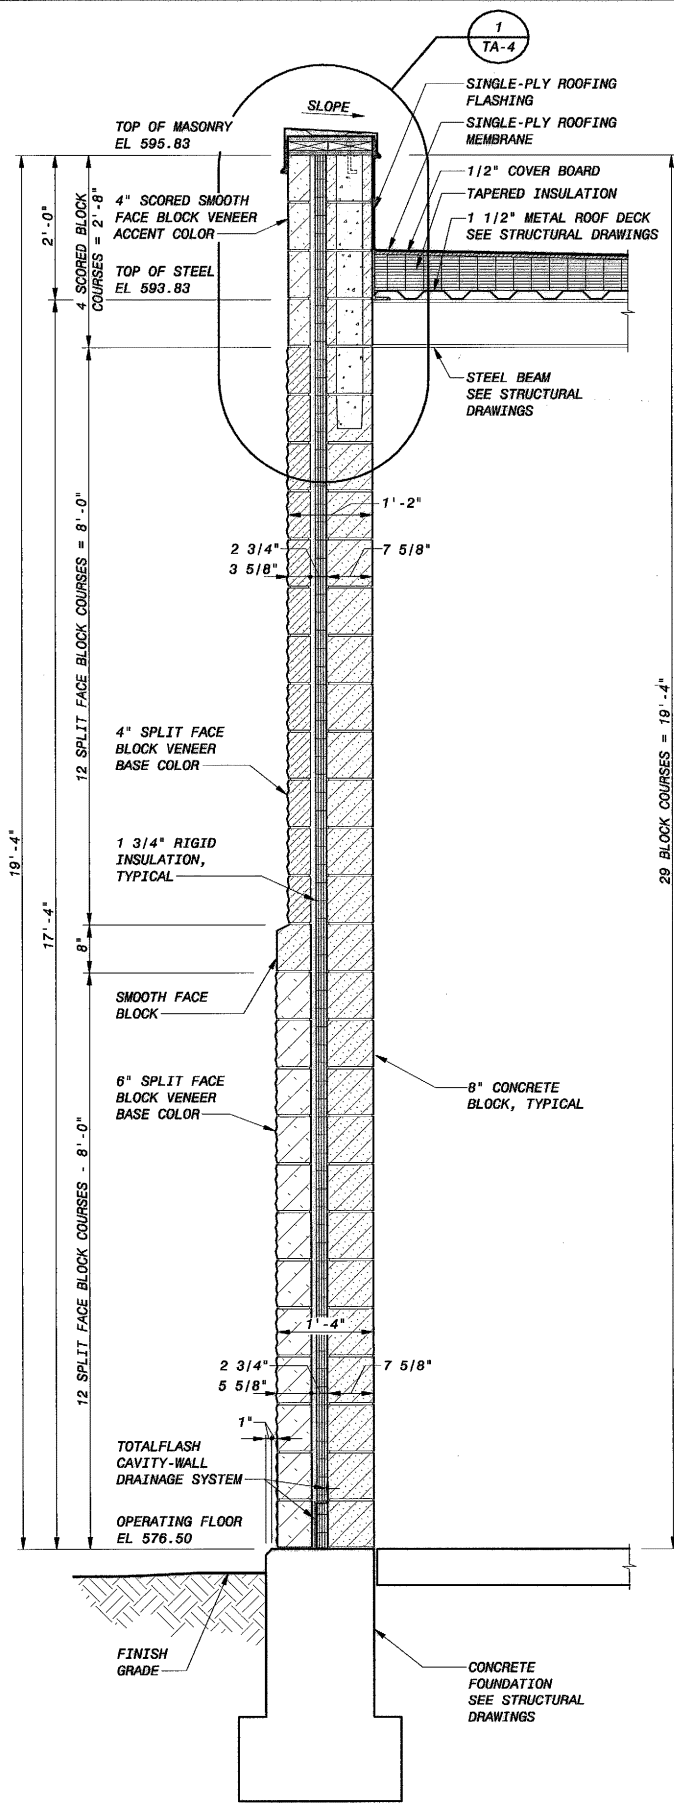


SECTION 1
3/4" = 1'-0"

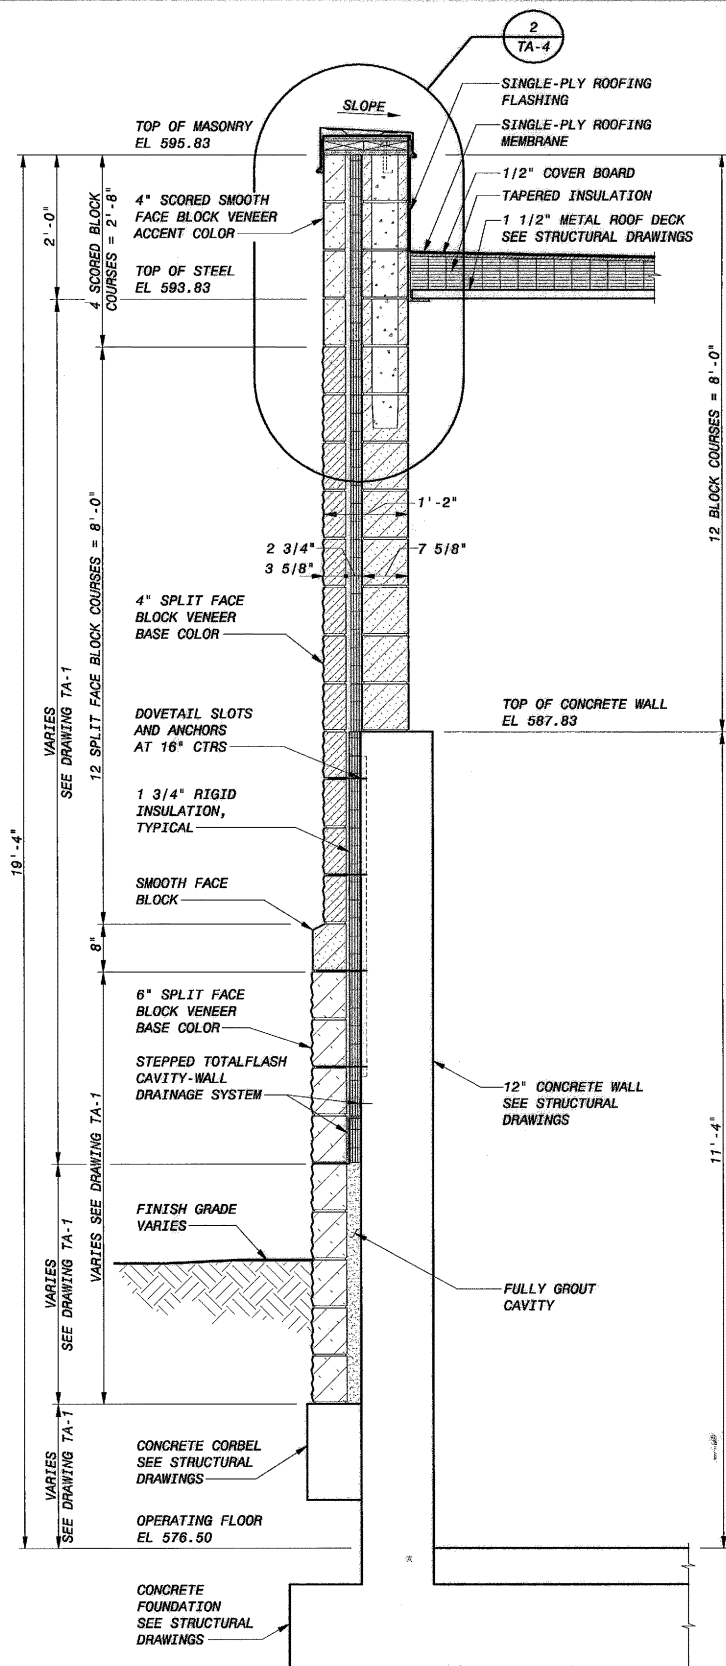

SECTION 2
3/4" = 1'-0"

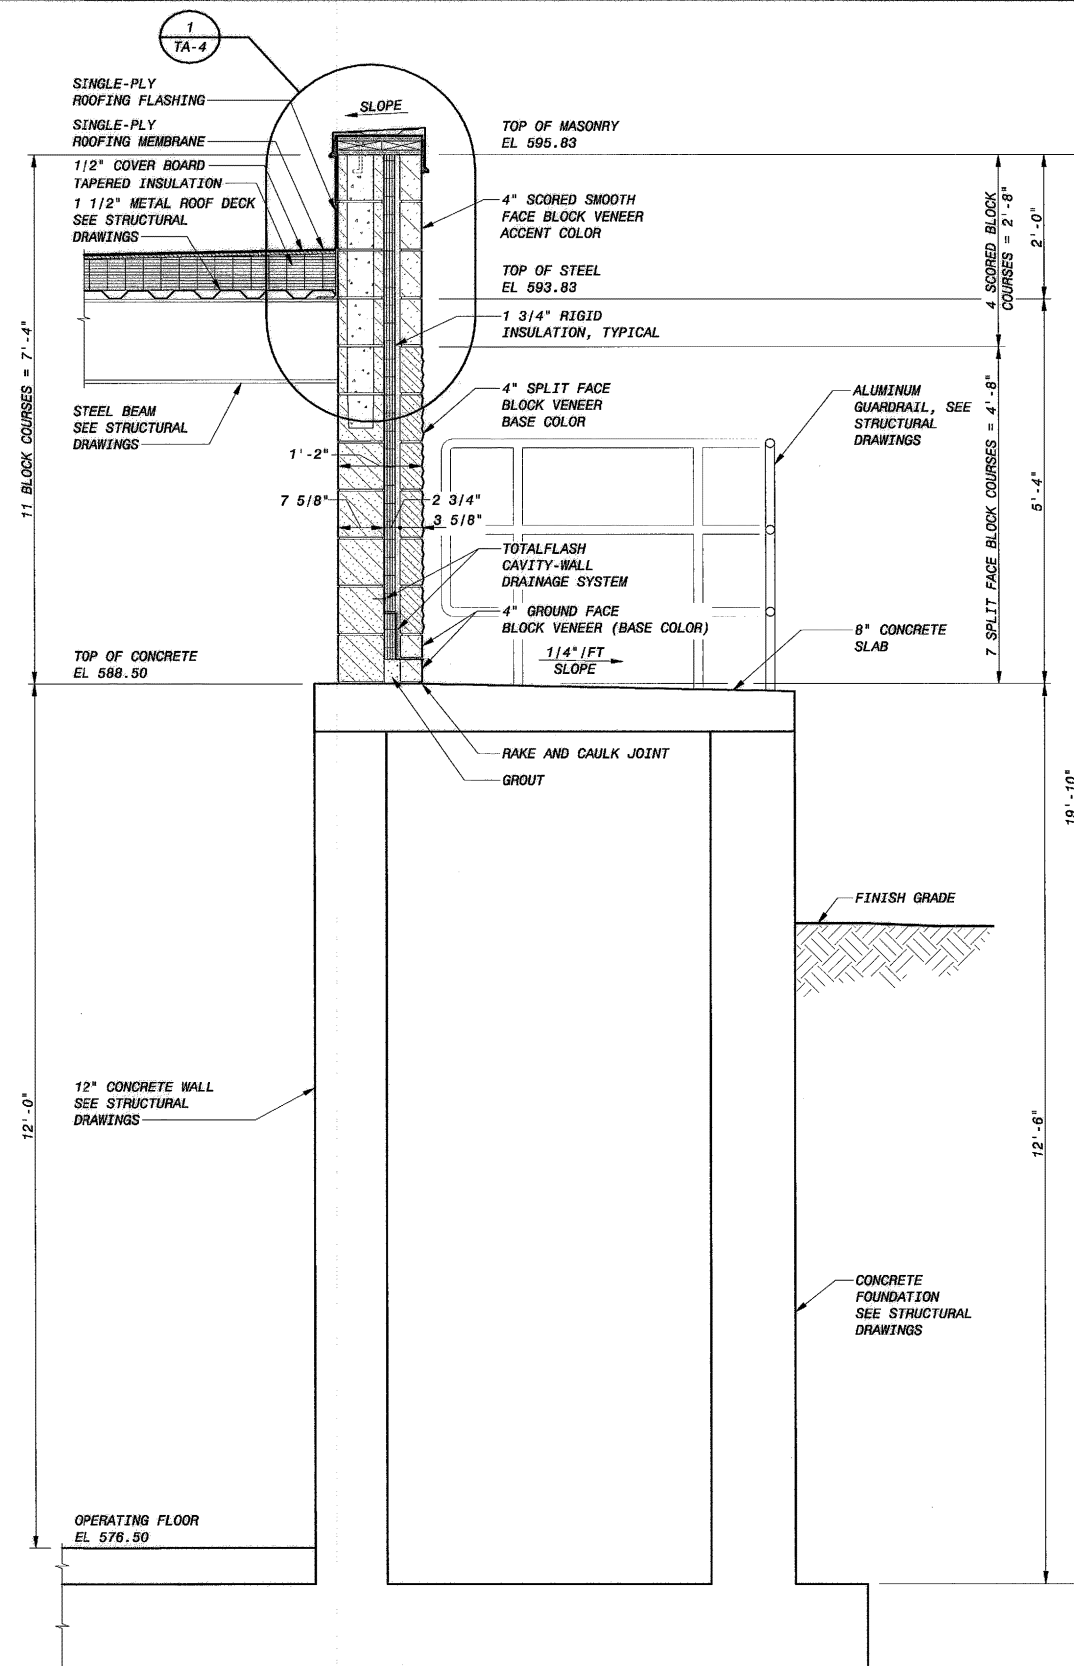


SECTION 3
3/4" = 1'-0"

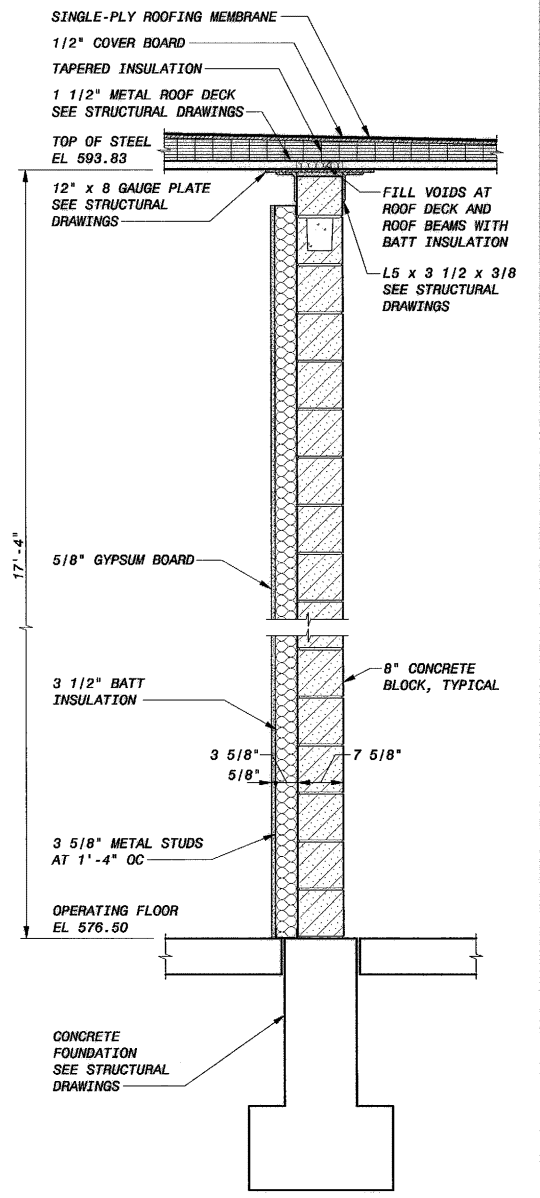

SECTION 4
3/4" = 1'-0"

- NOTES:
1. FOR VERTICAL REINFORCING, BOND BEAM LOCATIONS AND WALL PENETRATIONS. SEE STRUCTURAL DRAWINGS
 2. SEE SPECIFICATION SECTION 04200 BUILDING MASONRY FOR HORIZONTAL JOINT REINFORCING

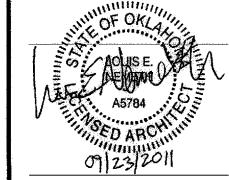

REVISION	BY	DATE

LOWER BIRD CREEK WWTP EXPANSION
TMUA PROJECT NO. ES 2006-01
CONTRACT 1B
SLUDGE TRANSFER PUMP STATION
ARCHITECTURAL
WALL SECTIONS

CITY OF TULSA, OKLAHOMA
TULSA METROPOLITAN UTILITY AUTHORITY
ENGINEERING SERVICES DEPARTMENT

PLANS AND ESTIMATES PREPARED BY:


BLACK & VEATCH
Building a world of difference

Holloway, Updike and Bullen
Consulting Engineers
Muskegon - Broken Arrow


ORIGATE
Engineering Services

Black & Veatch Corporation
Kansas City, Missouri


PLAN SCALE:	DRAWN	MDE	APPROVED:
	DESIGNED	PDR	
PROFILE SCALE:	SURVEY		
	FIELD MGR.	701 10/11	
HORIZONTAL:	SECT. MGR.		
1" =	PROJ. MGR.	224 10/11	
VERTICAL	RECOMMENDED:		
1" =			
FILE: TA-03	DRAWING: TA-3	DATE 10/28/2011	
ATLAS PAGE NO:		SHEET 192 OF 261 SHEETS	

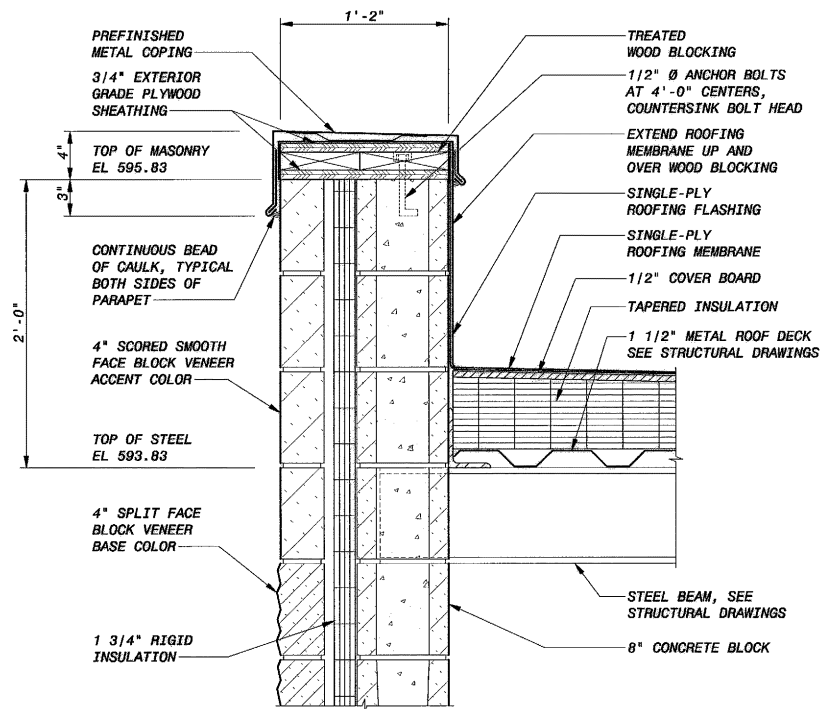


DETAIL 1
1 1/2" = 1'-0" TA-3

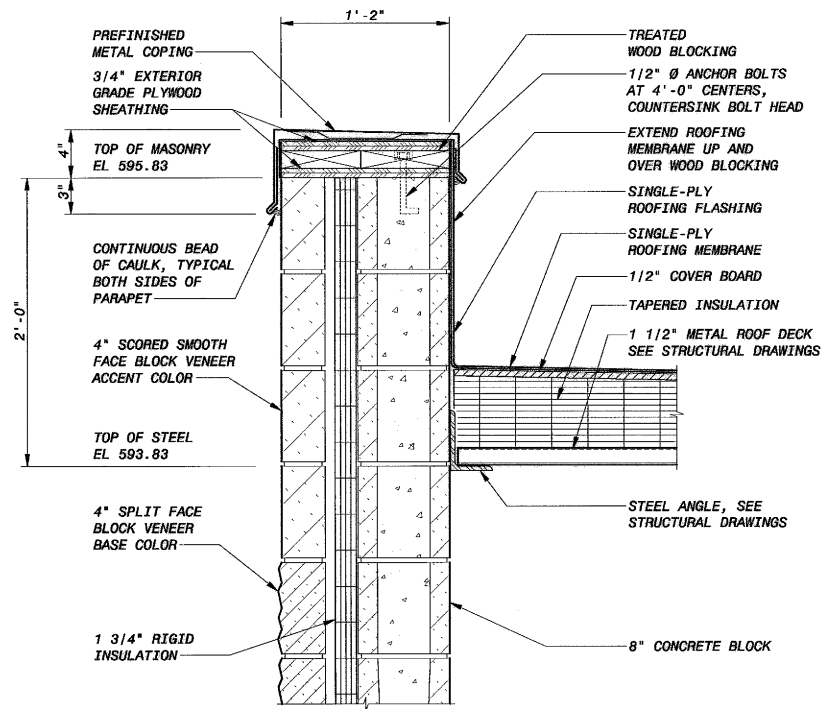


DETAIL 2
1 1/2" = 1'-0" TA-3

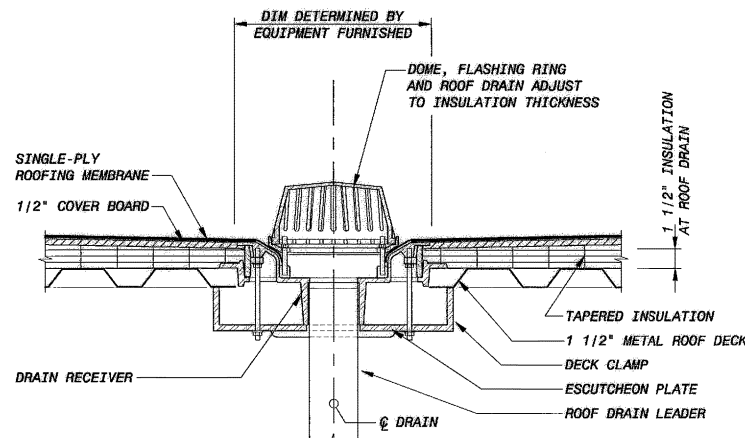


DETAIL 3
1 1/2" = 1'-0" TA-2

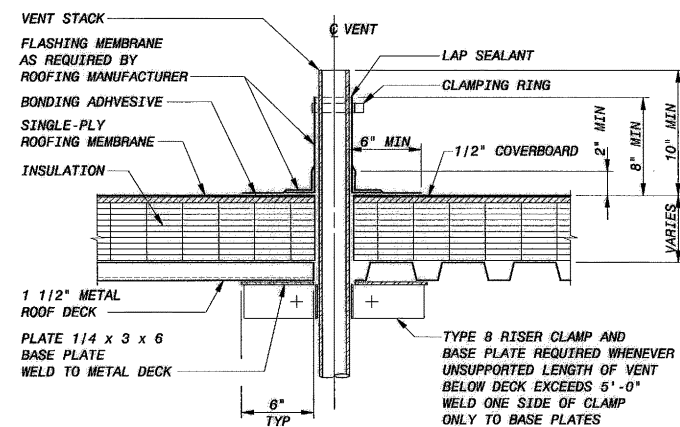


DETAIL 4
1 1/2" = 1'-0" TA-2

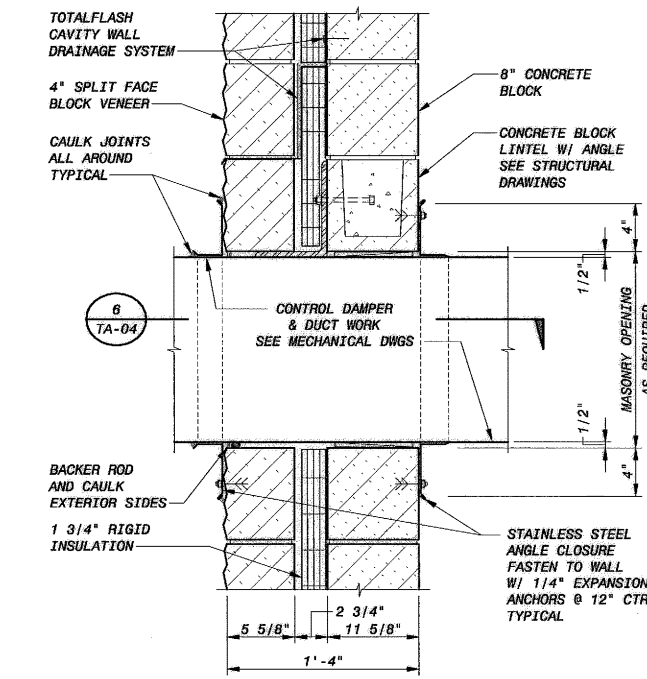

DETAIL 5
1 1/2" = 1'-0" TA-1, TA-2

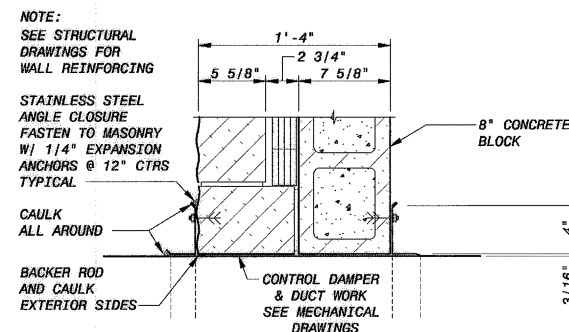

DETAIL 6
1 1/2" = 1'-0" TA-1, TA-2

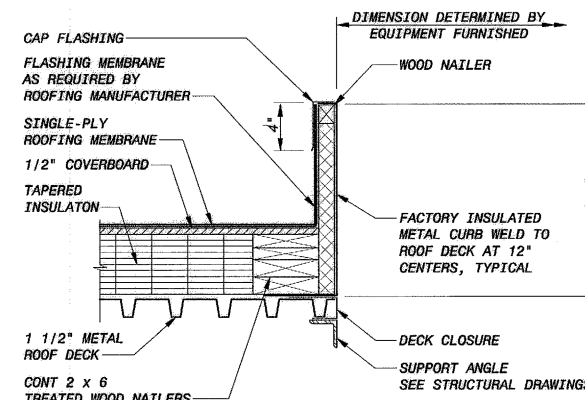

DETAIL 7
1 1/2" = 1'-0" TA-2


12" 9" 6" 3" 0 1'
1 1/2" = 1'-0"


LOWER BIRD CREEK WWTP EXPANSION
TMUA PROJECT NO. ES 2006-01
CONTRACT 1B
SLUDGE TRANSFER PUMP STATION
ARCHITECTURAL
MISCELLANEOUS DETAILS
CITY OF TULSA, OKLAHOMA
TULSA METROPOLITAN UTILITY AUTHORITY
ENGINEERING SERVICES DEPARTMENT

PLANS AND ESTIMATES PREPARED BY:

BLACK & VEATCH
Building a world of difference
Holloway, Updike and Bolton
Consulting Engineers
Muskogee - Broken Arrow
DINGATE
Engineering
Services

REVISION	BY	DATE	PLAN SCALE:	DRAWN	MDE	APPROVED:
				DESIGNED	PDR	
				SURVEY		
			PROFILE SCALE:	FIELD MGR.	10/11	
			HORIZONTAL:	SECT. MGR.	10/11	
			1" =	PROJ. MGR.	10/11	
			VERTICAL:	RECOMMENDED:	10/11	
			1" =			
			FILE: TA-04	DRAWING: TA-4		DATE 10/28/2011
			ATLAS PAGE NO:			SHEET 193 OF 261 SHEETS

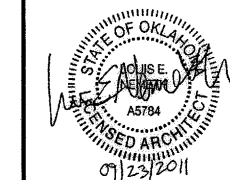

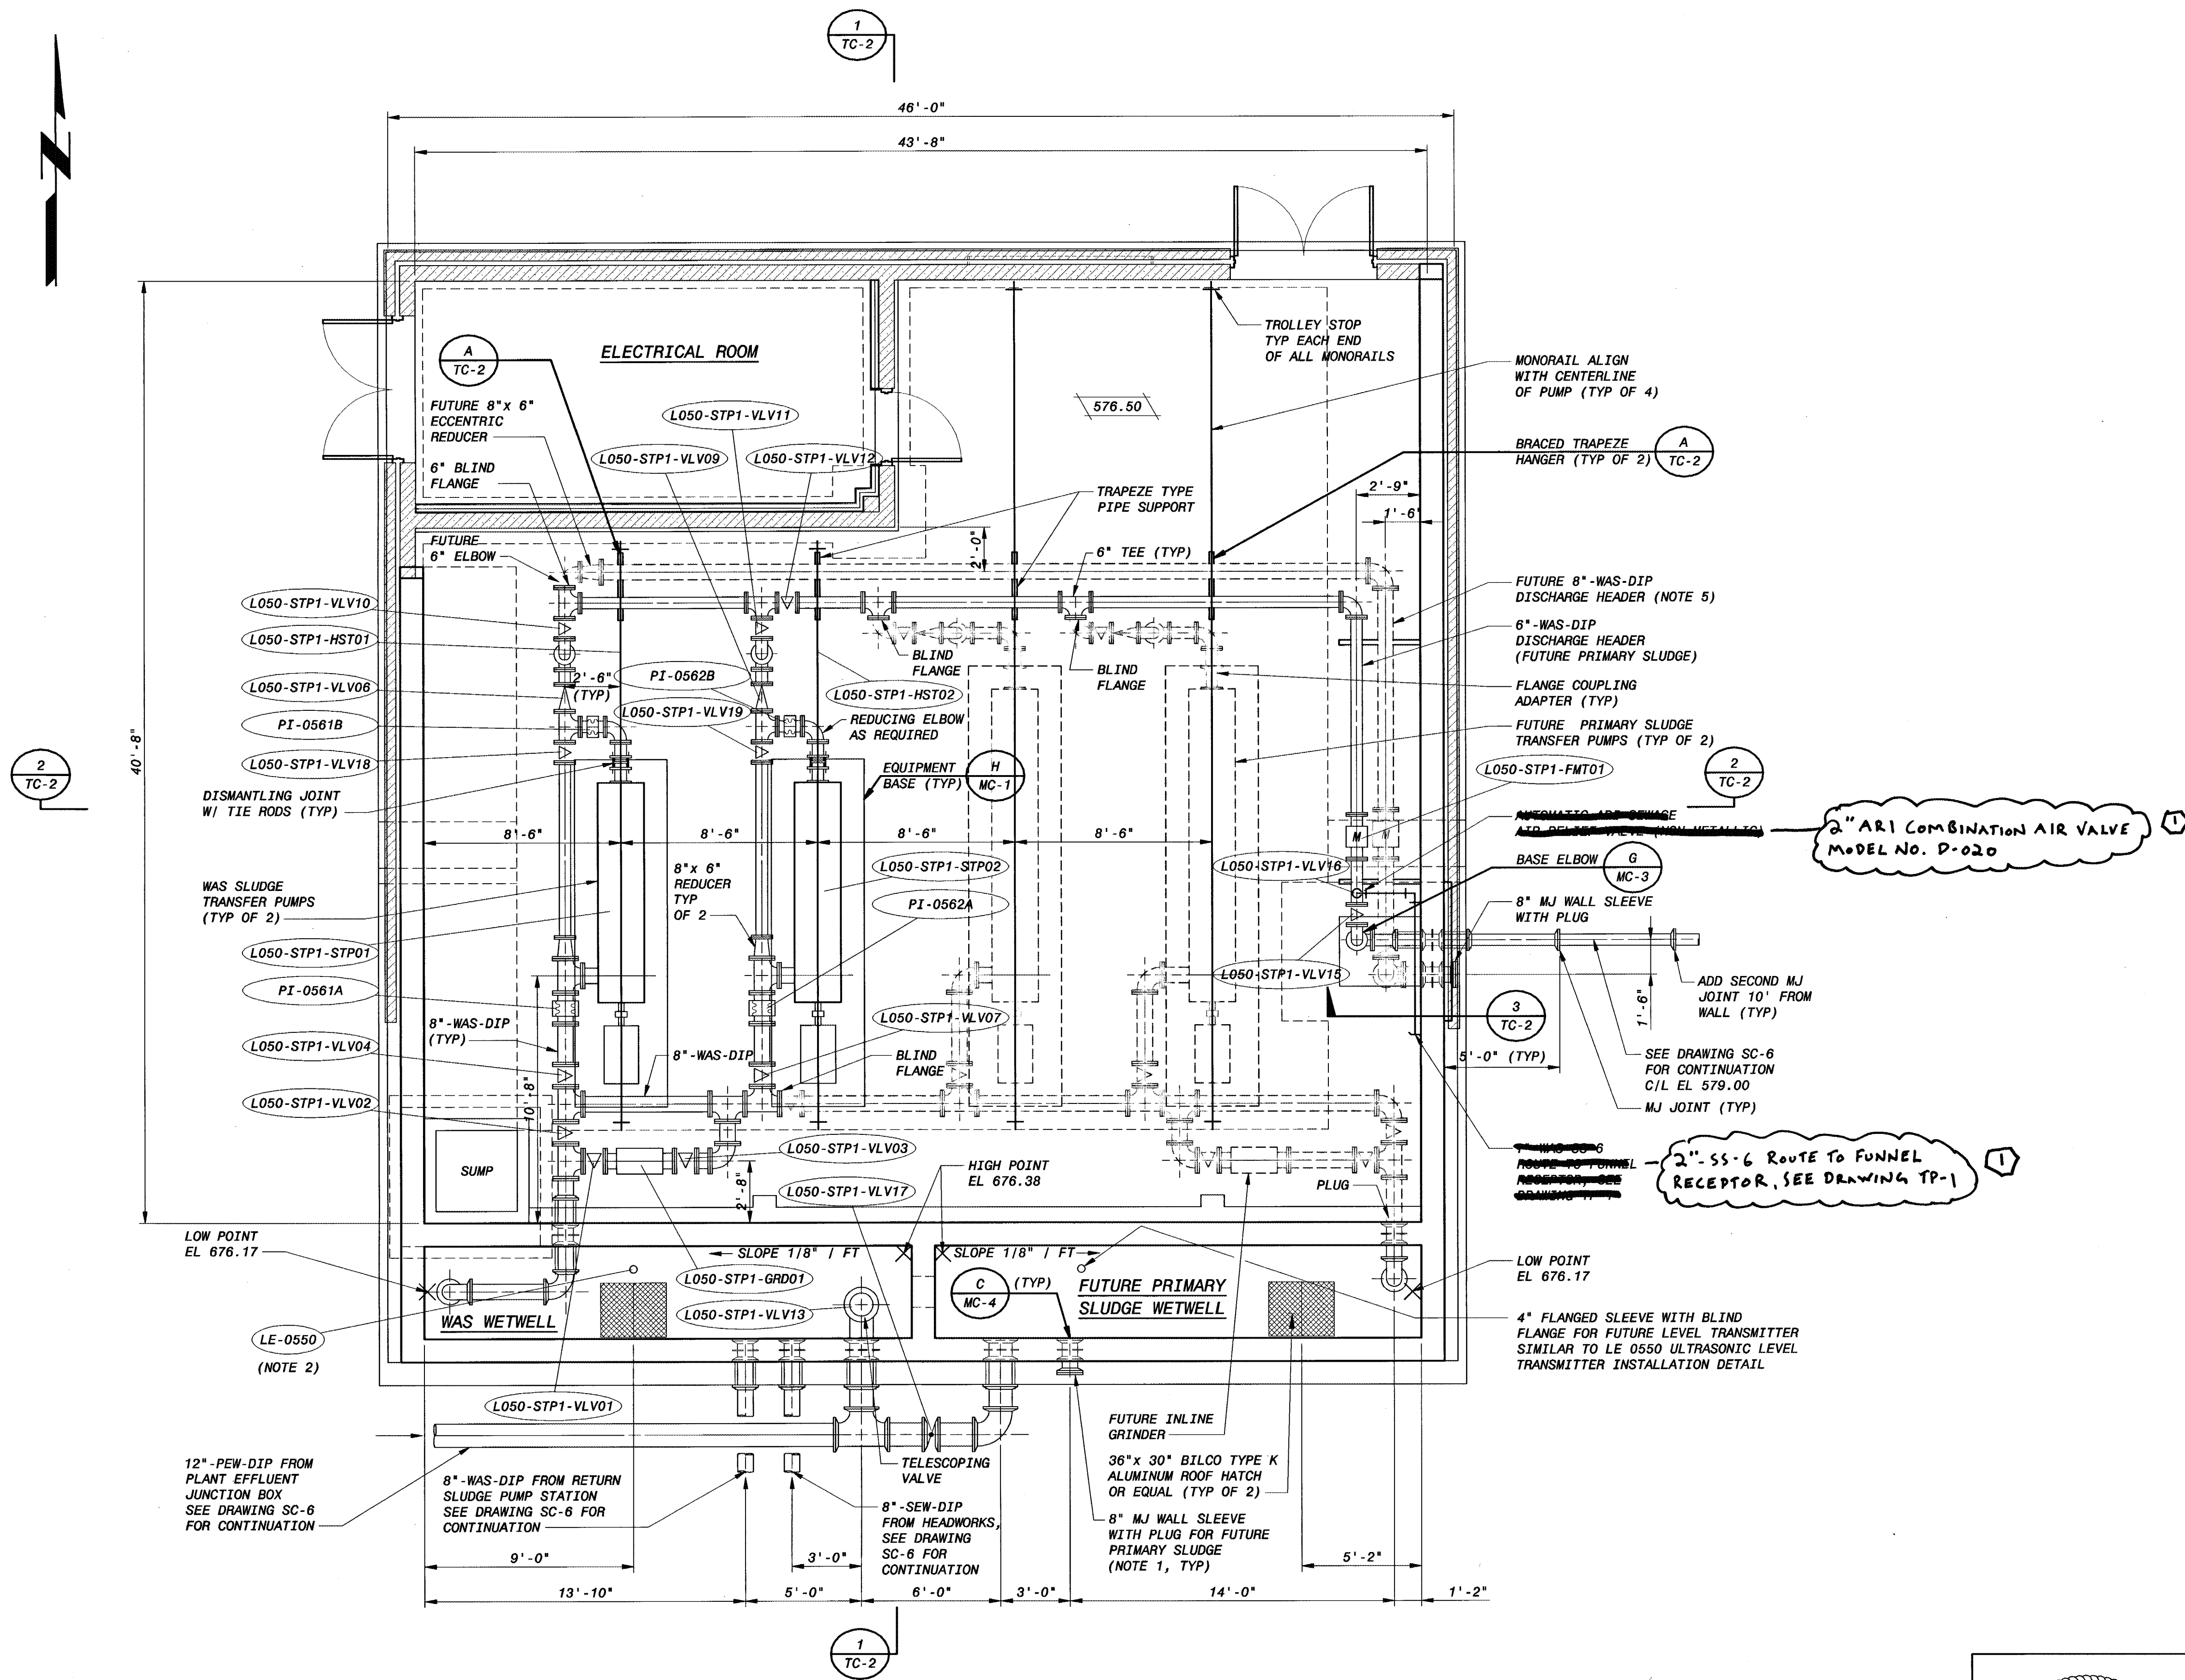

SLUDGE TRANSFER PUMP STATION
OPERATING FLOOR PLAN
 1/4" = 1'-0"

NOTES:


1. ALL MECHANICAL JOINT WALL PIPES SHALL BE RESTRAINED ON BOTH SIDES OF THE WALL UNLESS OTHERWISE NOTED.
2. SEE INSTRUMENTATION FOR INSTALLATION DETAIL FOR ULTRASONIC LEVEL TRANSMITTER.
3. DISMANTLING JOINT SHALL HAVE A 275 PSI RATING, WITH FLANGE DRILLING FOR ANSI CLASS 125 BOLT CIRCLE (ROMAC DJ 400 WITH CLASS E FLANGE AND ANSI 125 DRILLING OR EQUAL).
4. ALL PIPING SHALL BE SUPPORTED IN ACCORDANCE WITH SPECIFICATION 15140. PIPE SUPPORTS FOR THE SLUDGE DISCHARGE PIPING ARE SHOWN AND SHALL NOT BE RELOCATED WITHOUT APPROVAL OF ENGINEER.
5. FUTURE PLANT EXPANSIONS WILL ADD PRIMARY CLARIFIERS. THE PRIMARY SLUDGE WILL BE CONVEYED TO THE FUTURE PRIMARY SLUDGE WETWELL. VALVE L050-STP1-VLV12 WILL BE CLOSED TO DIVIDE THE DISCHARGE HEADER, WAS WILL FLOW TO THE WEST, THEN THROUGH THE 180° DOUBLE ELBOWS THROUGH THE FUTURE 8" WAS DISCHARGE HEADER WHILE PRIMARY SLUDGE WILL FLOW EAST THROUGH THE ORIGINAL 6" WAS DISCHARGE HEADER (FUTURE PRIMARY SLUDGE).
6. MANUAL RECIRCULATION VALVES SHALL BE OPENED PRIOR TO STARTING THE CORRESPONDING PUMP. RECIRCULATION VALVE SHALL BE SLOWLY CLOSED OVER A PERIOD OF APPROXIMATELY 5 MINUTES. THE RECIRCULATION VALVE SHALL BE CLOSED SLOWLY ENOUGH TO KEEP DISCHARGE PRESSURE BELOW 225 PSIG. TO SWITCH WHICH PUMP IS OPERATING, THE PUMP THAT IS INITIALLY ON SHALL BE SLOWLY RAMPED DOWN USING THE AFD, WHILE THE PUMP THAT IS INITIALLY OFF SHALL BE STARTED ONCE THE OPERATING PUMP IS AT LESS THAN 80%, AND SLOWLY RAMPED UP AT THE SAME RATE THE OTHER PUMP IS RAMPED DOWN.

LOWER BIRD CREEK WWTP EXPANSION
 TMUA PROJECT NO. ES 2006-01
 CONTRACT 1B





SLUDGE TRANSFER PUMP STATION
 CIVIL
 OPERATING FLOOR PLAN

CITY OF TULSA, OKLAHOMA
 TULSA METROPOLITAN UTILITY AUTHORITY
 ENGINEERING SERVICES DEPARTMENT

PLANS AND ESTIMATES PREPARED BY:

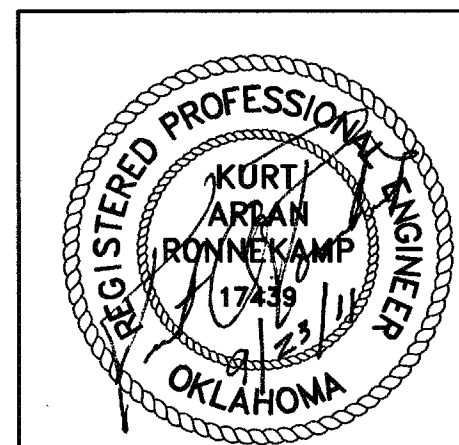

REVISION	BY	DATE	PLAN SCALE:	DRAWN	JKS	APPROVED:
Addendum No. 1	PSB	1-6-12		DESIGNED	AWL	
				SURVEY		
			PROFILE SCALE:	FIELD MGR.	703	W11
				SECT. MGR.		
			HORIZONTAL:	PROJ. MGR.	W11	10/28/11
				RECOMMENDED:		
			VERTICAL			
			FILE:	DRAWING: TC-1		DATE 10/28/2011
			ATLAS PAGE NO:			SHEET 194 OF 261 SHEETS

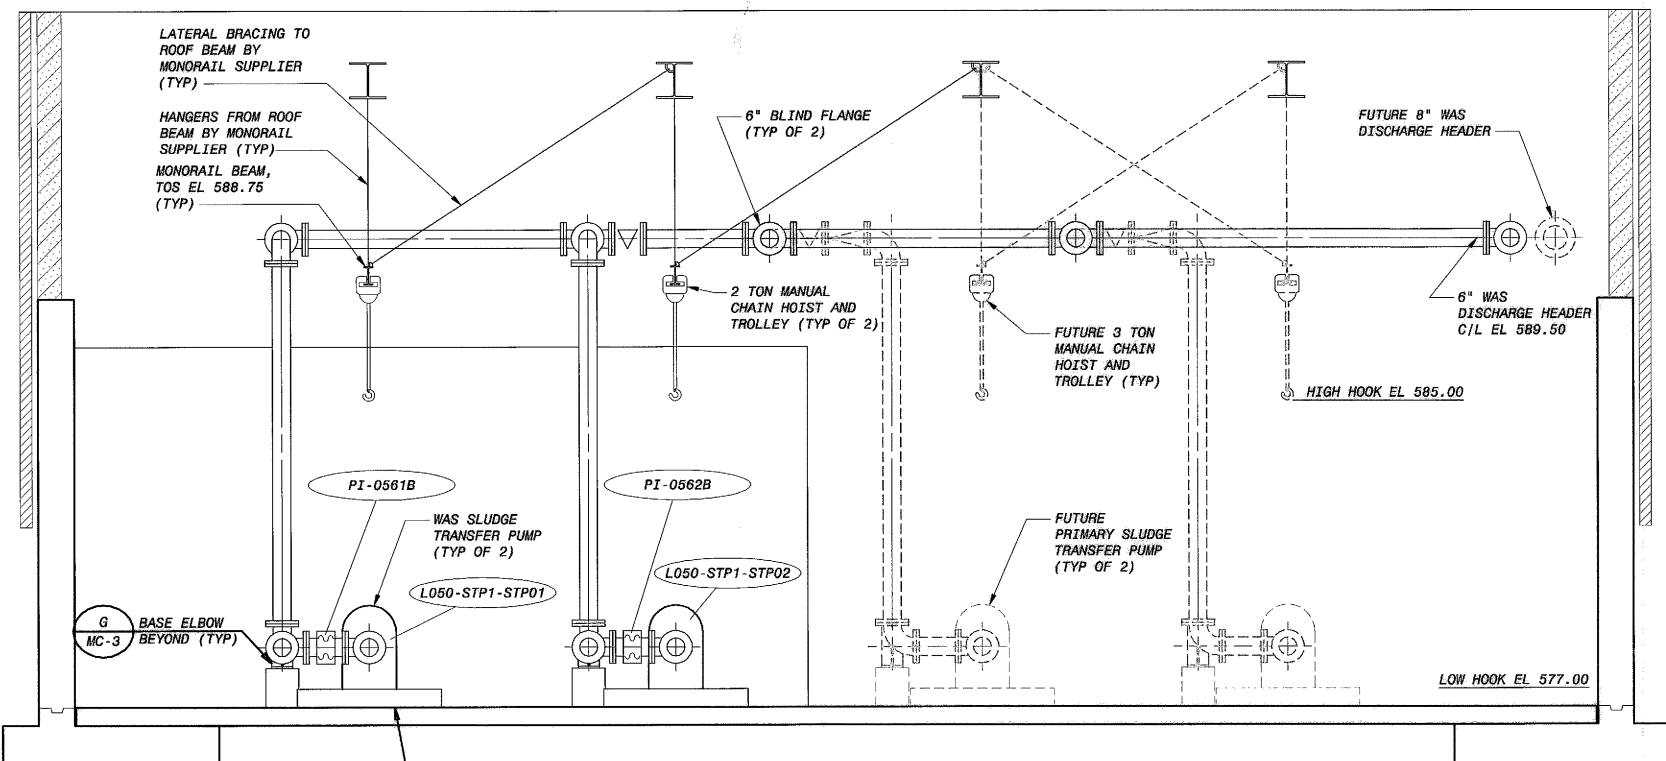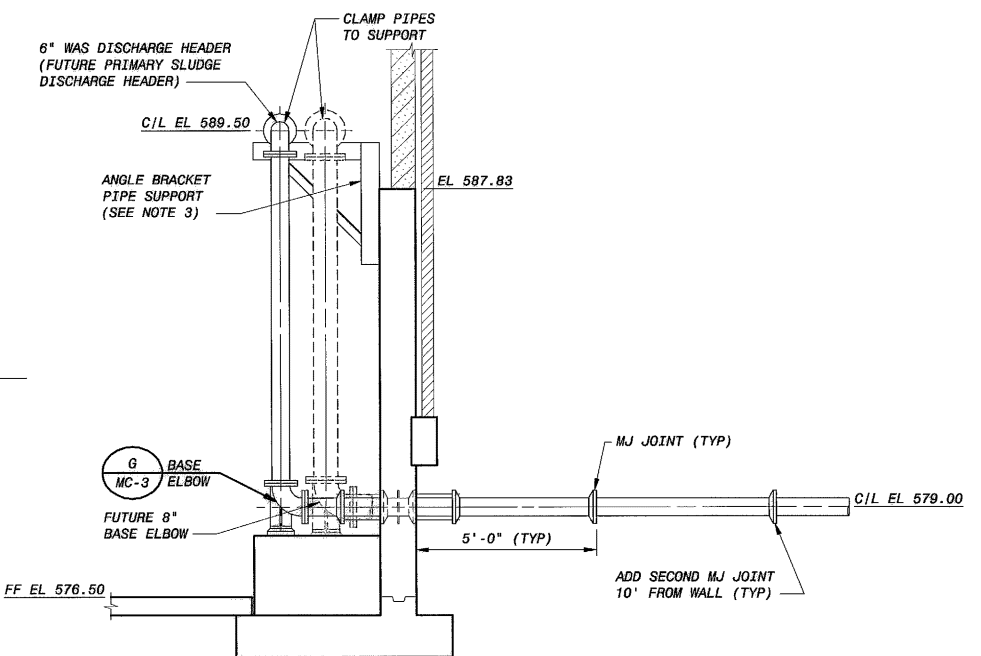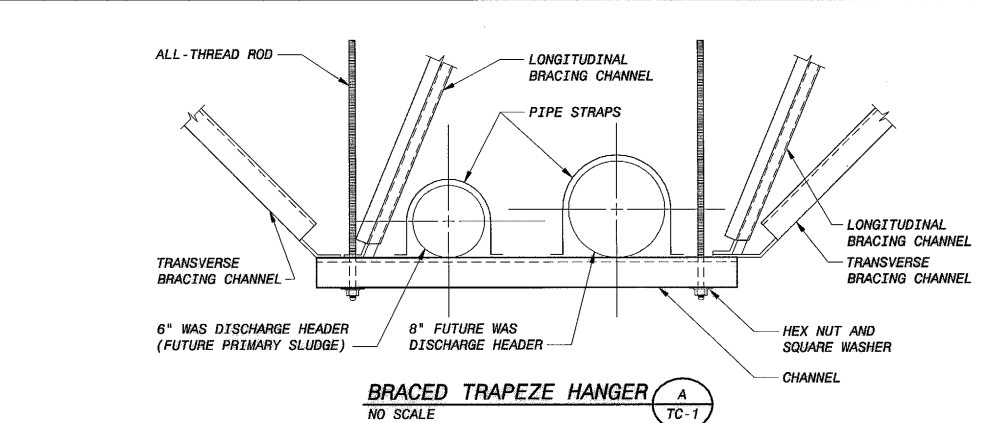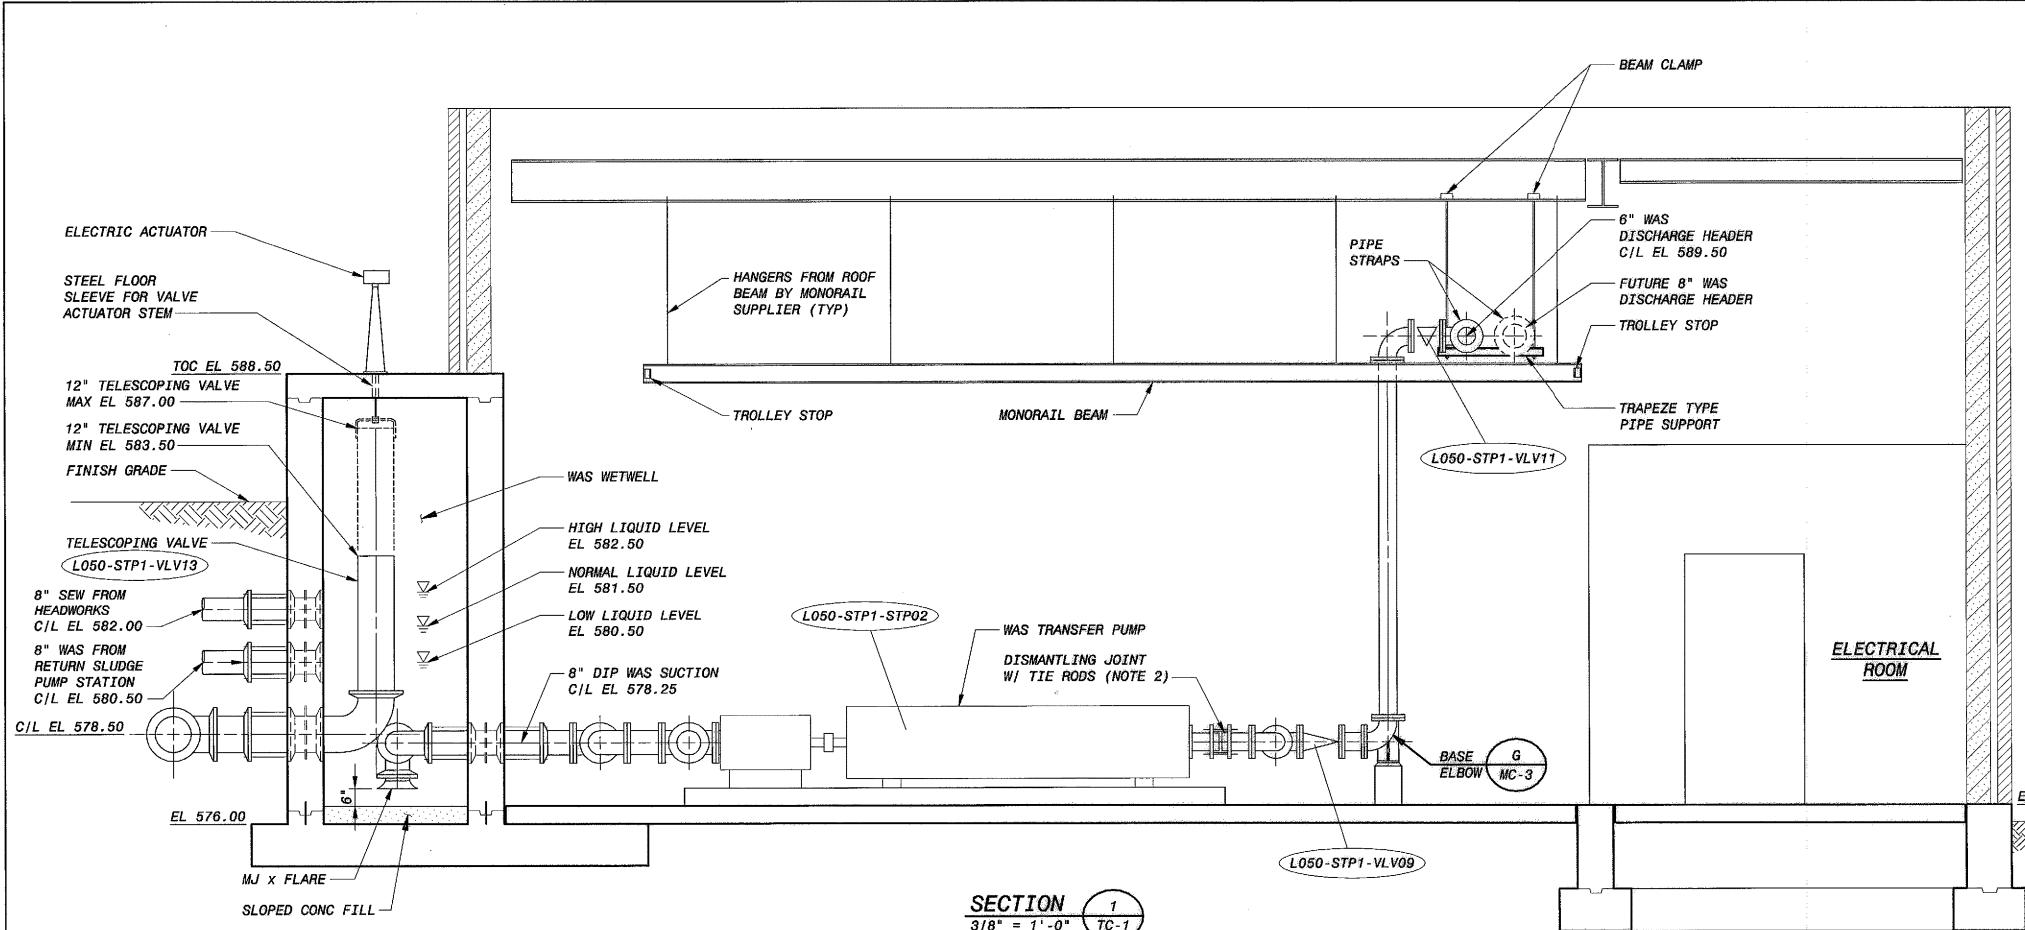


NOTES:

1. CONTRACTOR SHALL DESIGN THE BRACED TRAPEZE HANGER FOR A VERTICAL LOAD OF 1500 POUNDS, A TRANSVERSE LOAD OF 1500 POUNDS, AND A LONGITUDINAL LOAD OF 500 POUNDS.
2. DISMANTLING JOINT SHALL HAVE A 275 PSI RATING, WITH FLANGE DRILLING FOR ANSI CLASS 125 BOLT CIRCLE (ROMAC DJ 400 WITH CLASS E FLANGE AND ANSI 125 DRILLING OR EQUAL).
3. CONTRACTOR SHALL DESIGN ANGLE BRACKET PIPE SUPPORT FOR A VERTICAL LOAD OF 1500 POUNDS, A TRANSVERSE LOAD OF 3000 POUNDS, AND A LONGITUDINAL LOAD OF 500 POUNDS.

LOWER BIRD CREEK WWTP EXPANSION
 TMUA PROJECT NO. ES 2006-01
 CONTRACT 1B
 SLUDGE TRANSFER PUMP STATION
 CIVIL
 SECTIONS AND DETAILS
 CITY OF TULSA, OKLAHOMA
 TULSA METROPOLITAN UTILITY AUTHORITY
 ENGINEERING SERVICES DEPARTMENT


PLANS AND ESTIMATES PREPARED BY:
BLACK & VEATCH
 Building a world of difference
 Consulting Engineers
 1000 North Broadway
 Suite 100
 Tulsa, Oklahoma 74102
 (918) 581-1000
 FAX (918) 581-1001
 www.bv.com

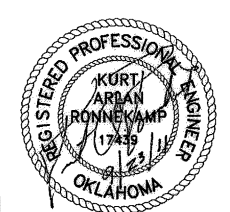

REVISION	BY	DATE	PLAN SCALE:	DRAWN	JKS	APPROVED:
				DESIGNED	AWL	
				SURVEY		
			PROFILE SCALE:	FIELD MGR.	10/3/11	
			HORIZONTAL:	SECT. MGR.	10/3/11	
			1" =	PROJ. MGR.	10/3/11	
			VERTICAL:	RECOMMENDED:	10/3/11	
			1" =			
			FILE:	DRAWING: TC-2		DATE 10/28/2011
			ATLAS PAGE NO:			SHEET 195 OF 261 SHEETS


PLOTTED DATE: 9/21/2011 5:06:05 PM Bales Plot
 SAVED DATE: 9/21/2011 2:47:35 PM
 C:\GAI\145120-3000-C-50000W40B

PLOTTED DATE: 6/16/2011 11:28:23 AM
 PLOTTER: HP DesignJet 1000
 C:\GNET\1045120-3000-S-0000000501

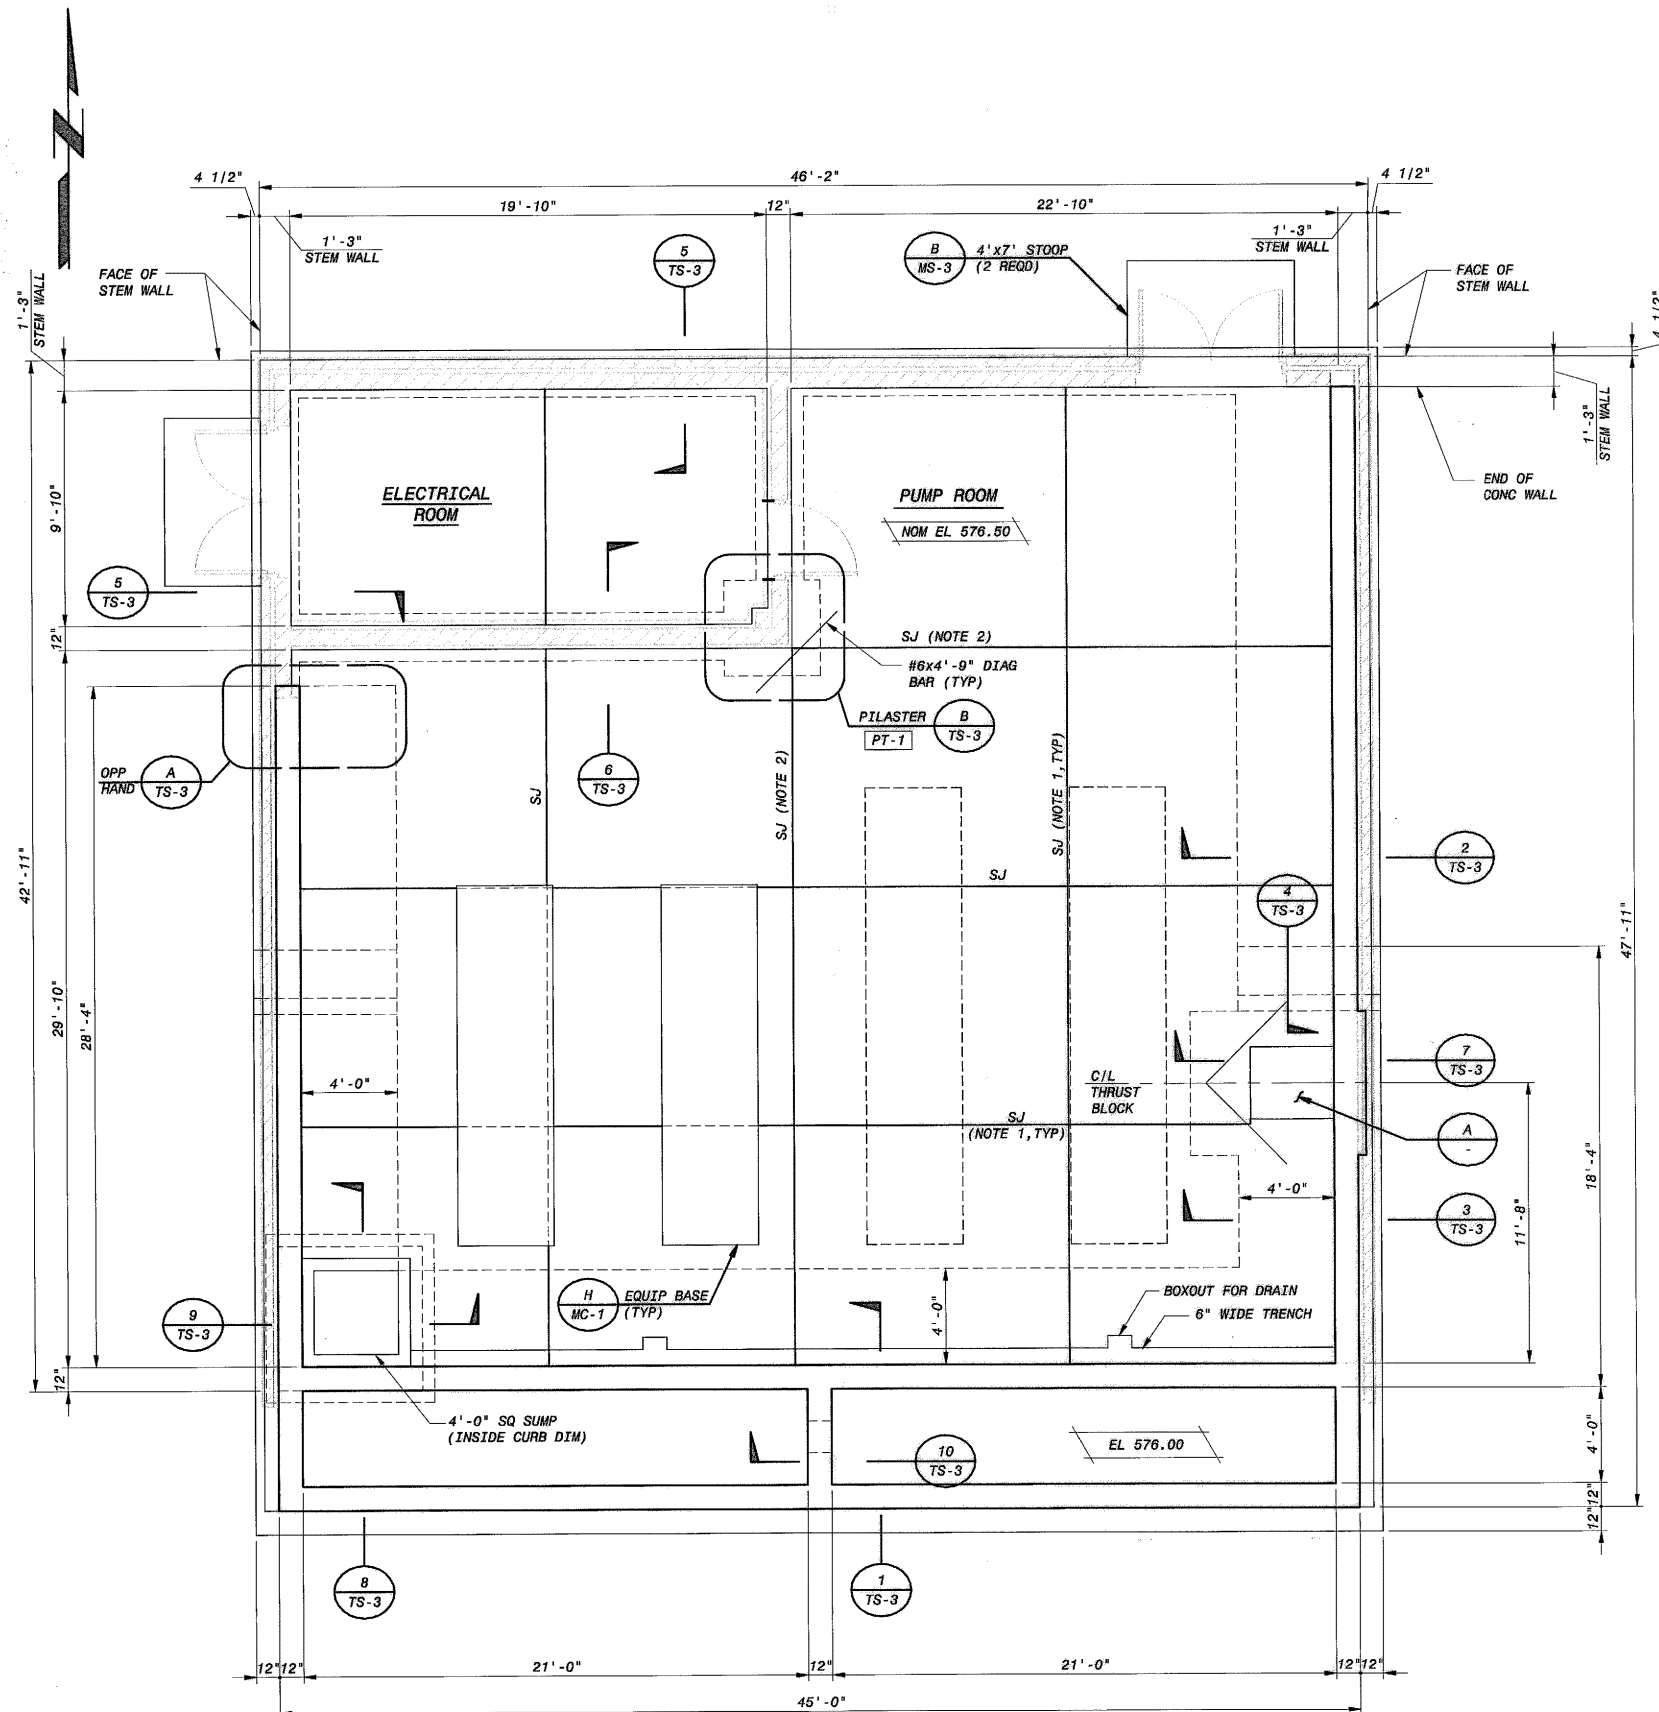


FOUNDATION PLAN
 1/4" = 1'-0"

- NOTES:
1. MAXIMUM SAWCUT JOINT SPACING = 12'-0".
 2. LOCATE SAWCUT JOINT AT REINFRANT CORNER OF PUMP ROOM.

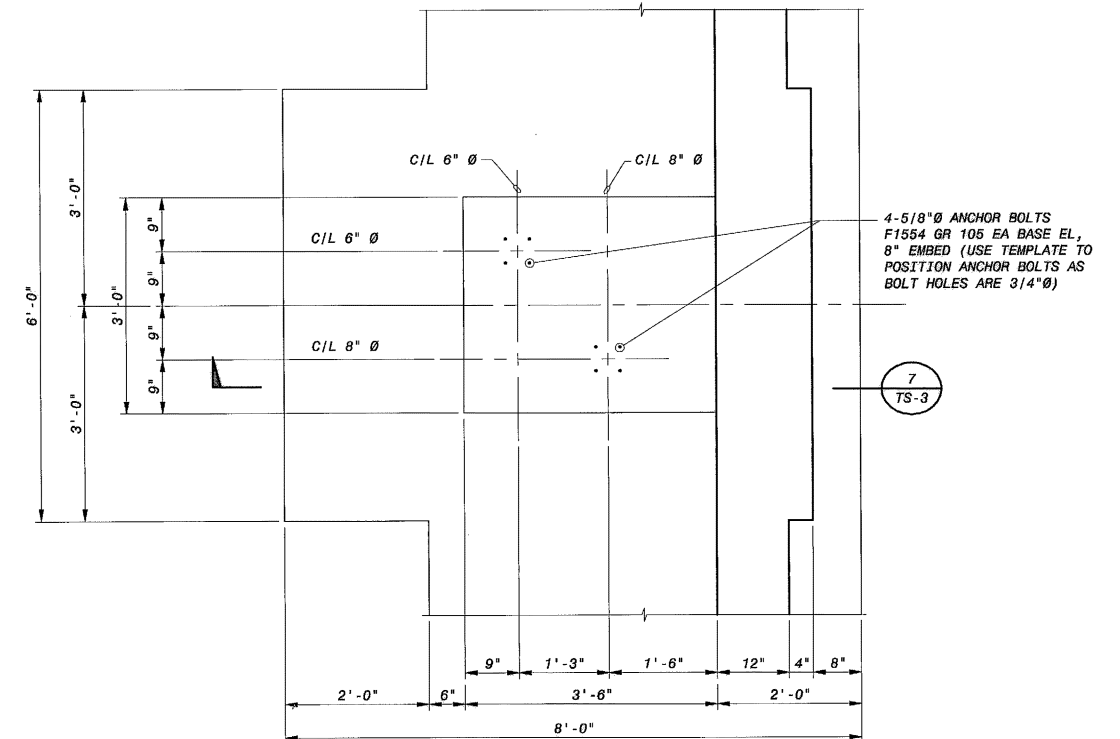


THRUST BLOCK DETAIL A
 3/4" = 1'-0"


LOWER BIRD CREEK WWTP EXPANSION TMUA PROJECT NO. ES 2006-01 CONTRACT 1B			
SLUDGE TRANSFER PUMP STATION STRUCTURAL FOUNDATION PLAN			
CITY OF TULSA, OKLAHOMA TULSA METROPOLITAN UTILITY AUTHORITY ENGINEERING SERVICES DEPARTMENT			
PLANS AND ESTIMATES PREPARED BY:			
BLACK & VEATCH Building a world of difference	Holloway, Updegraff and Ballen Consulting Engineers Washington - Union Arrow	BNGATES Engineering Services	
PLANS AND ESTIMATES PREPARED BY:			
REVISION BY DATE	PLAN SCALE: DRAWN DESIGNED SURVEY FIELD MGR. SECT. MGR. PROJ. MGR. RECOMMENDED	APPROVED: DIRECTOR	DATE 10/28/2011 SHEET 196 OF 261 SHEETS
FILE: TA-02 DRAWING: TS-1 ATLAS PAGE NO:			

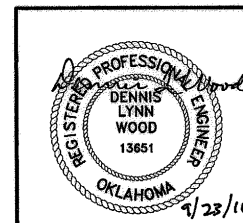

FD145120
PLOTTED DATE: CH453303, 6/10/2011 11:27:59 AM
SAVED DATE: MC02672, 9/21/2011 10:06:56 AM
C:\GNET ID: 145120-3000-S-B0000W420

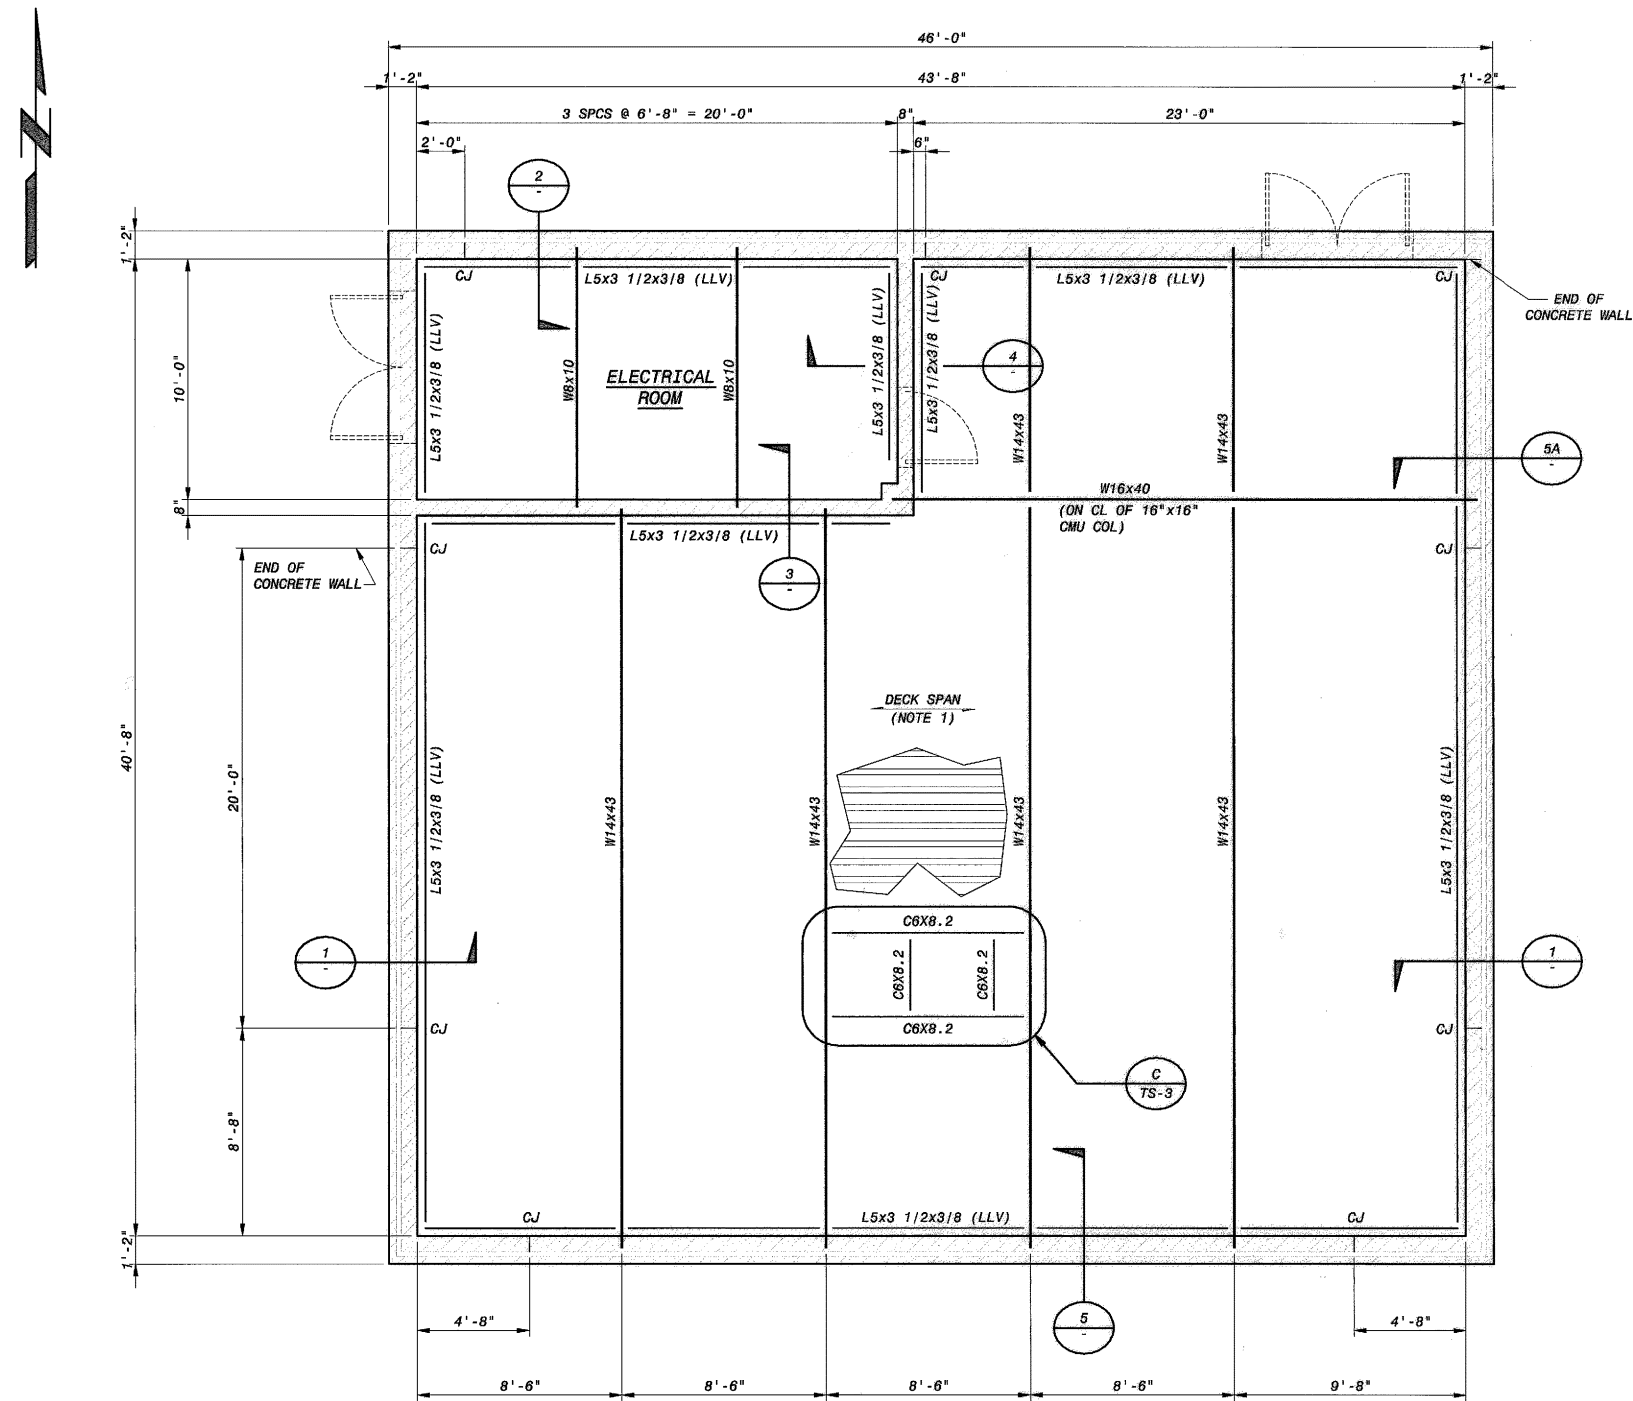


SLUDGE TRANSFER PUMP STATION
ROOF FRAMING PLAN @ TOS EL 593.83 (UNO)
CMU CONTROL JOINT LOCATION PLAN
1/4" = 1'-0"

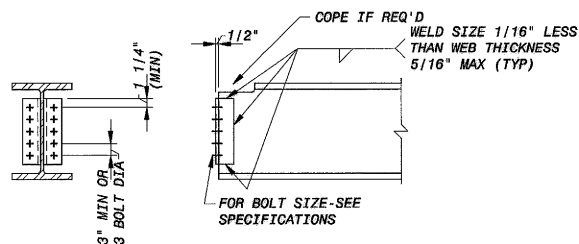

SHOP WELDED - FIELD BOLTED		
BEAM SIZE (ALL WEIGHTS)	NO OF BOLTS IN OSL	ANGLE SIZE
W16 & W18, S15 & S18 C15, MC18	8	2L'S 4x3x3/8
W12 & W14, M12 & M14, S12 C12, MC12 & MC13	6	2L'S 4x3x3/8
W8 & W10, M8 & M10, S8 & S10 C8, C9 & C10, MC8, MC9 & MC10	4	2L'S 4x3x3/8
W6, M6, S6 & S7 C6 & C7, MC6 & MC7	2	2L'S 4x3x3/8

NOTE: FABRICATOR SHALL PROVIDE ADDITIONAL CLIPS,
SEATS, BOLTS, ETC AS REQUIRED TO COMPLY
WITH OSHA SAFETY STANDARDS FOR STEEL ERECTION.

STANDARD FRAMING CONNECTIONS

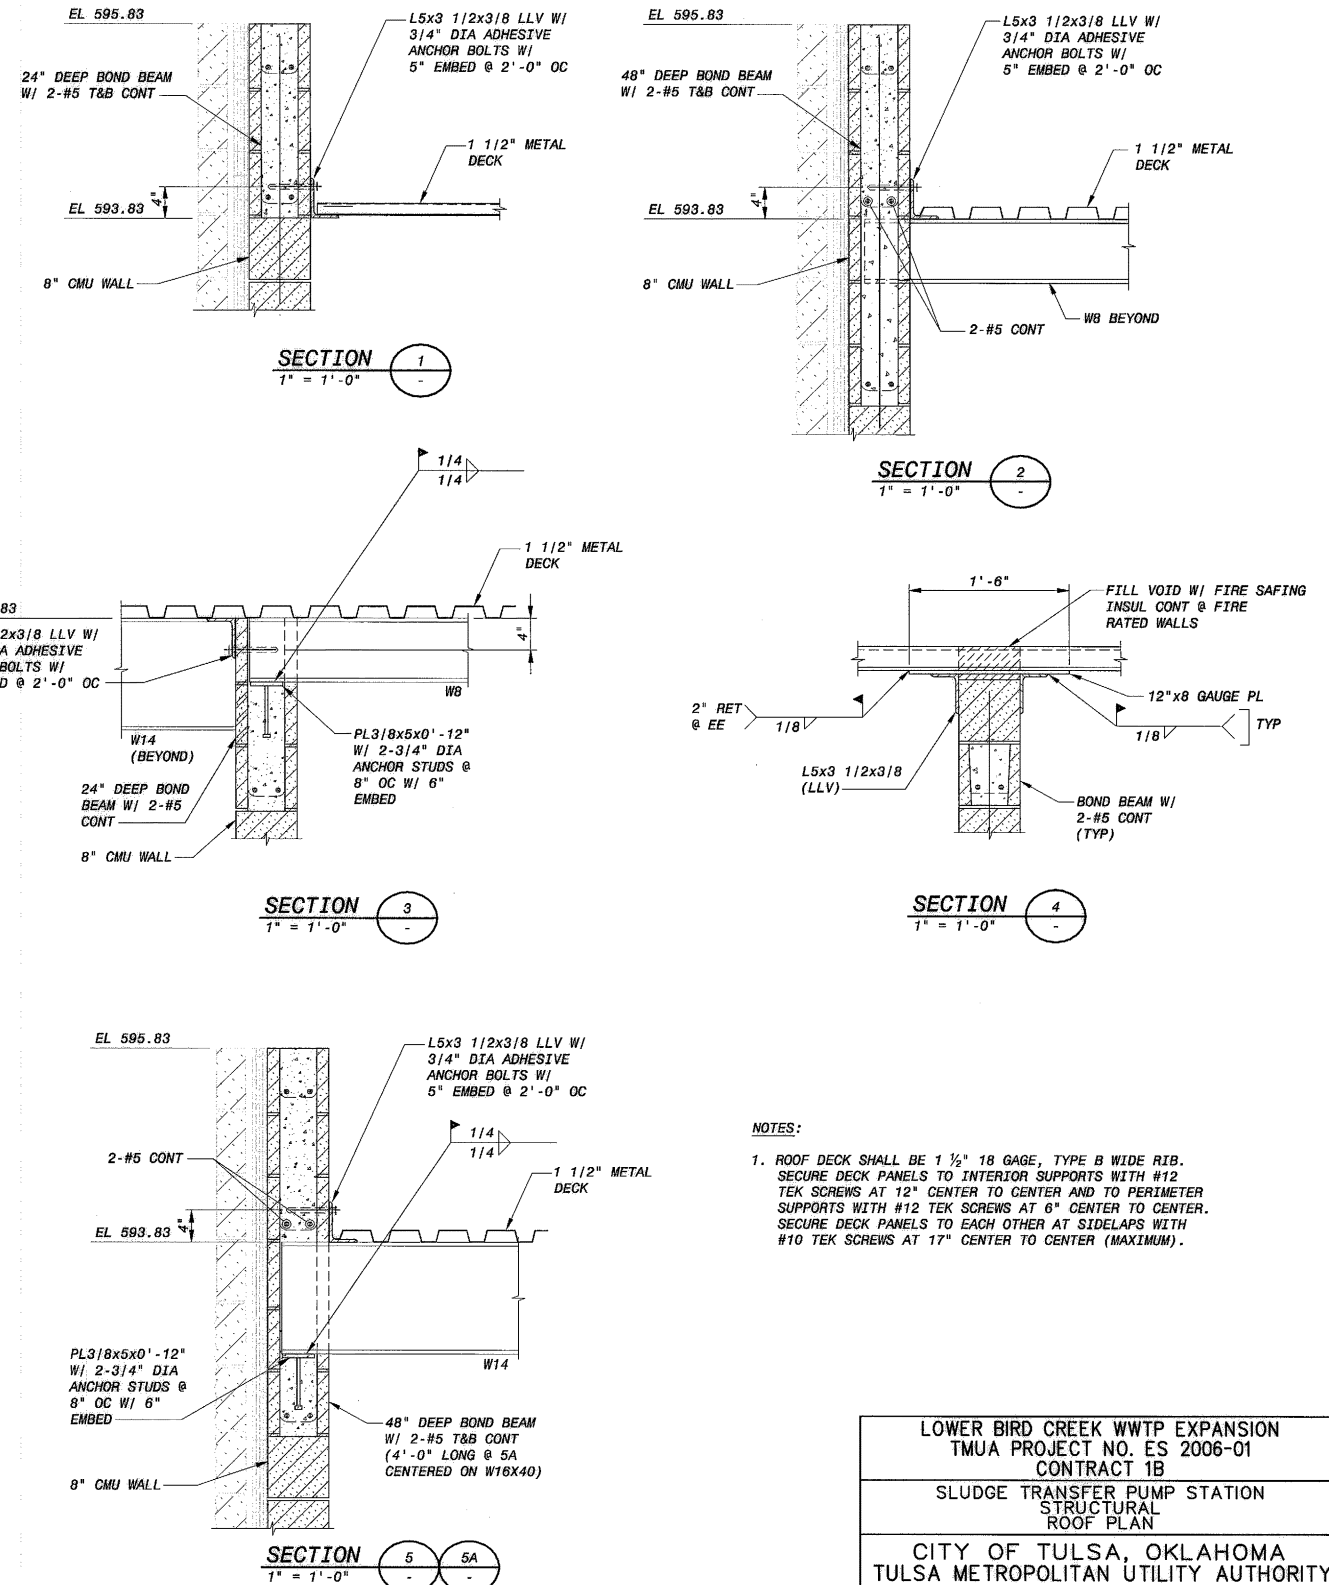



LOWER BIRD CREEK WWTP EXPANSION
TMUA PROJECT NO. ES 2006-01
CONTRACT 1B
SLUDGE TRANSFER PUMP STATION
STRUCTURAL
ROOF PLAN
CITY OF TULSA, OKLAHOMA
TULSA METROPOLITAN UTILITY AUTHORITY
ENGINEERING SERVICES DEPARTMENT

PLANS AND ESTIMATES PREPARED BY:



REVISION	BY	DATE	PLAN SCALE:	DRAWN	RR	APPROVED:
				DESIGNED	DLW	
				SURVEY		
			PROFILE SCALE:	FIELD MGR.	TS 10/11	
			HORIZONTAL:	SECT. MGR.	TS 10/11	
			1" =	PROJ. MGR.	TS 10/11	
			VERTICAL:	RECOMMENDED	TS 10/11	
			1" =			
			FILE:	DRAWING: TS-2		DATE 10/28/2011
			ATLAS PAGE NO:			SHEET 197 OF 261 SHEETS

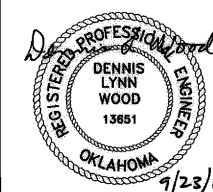

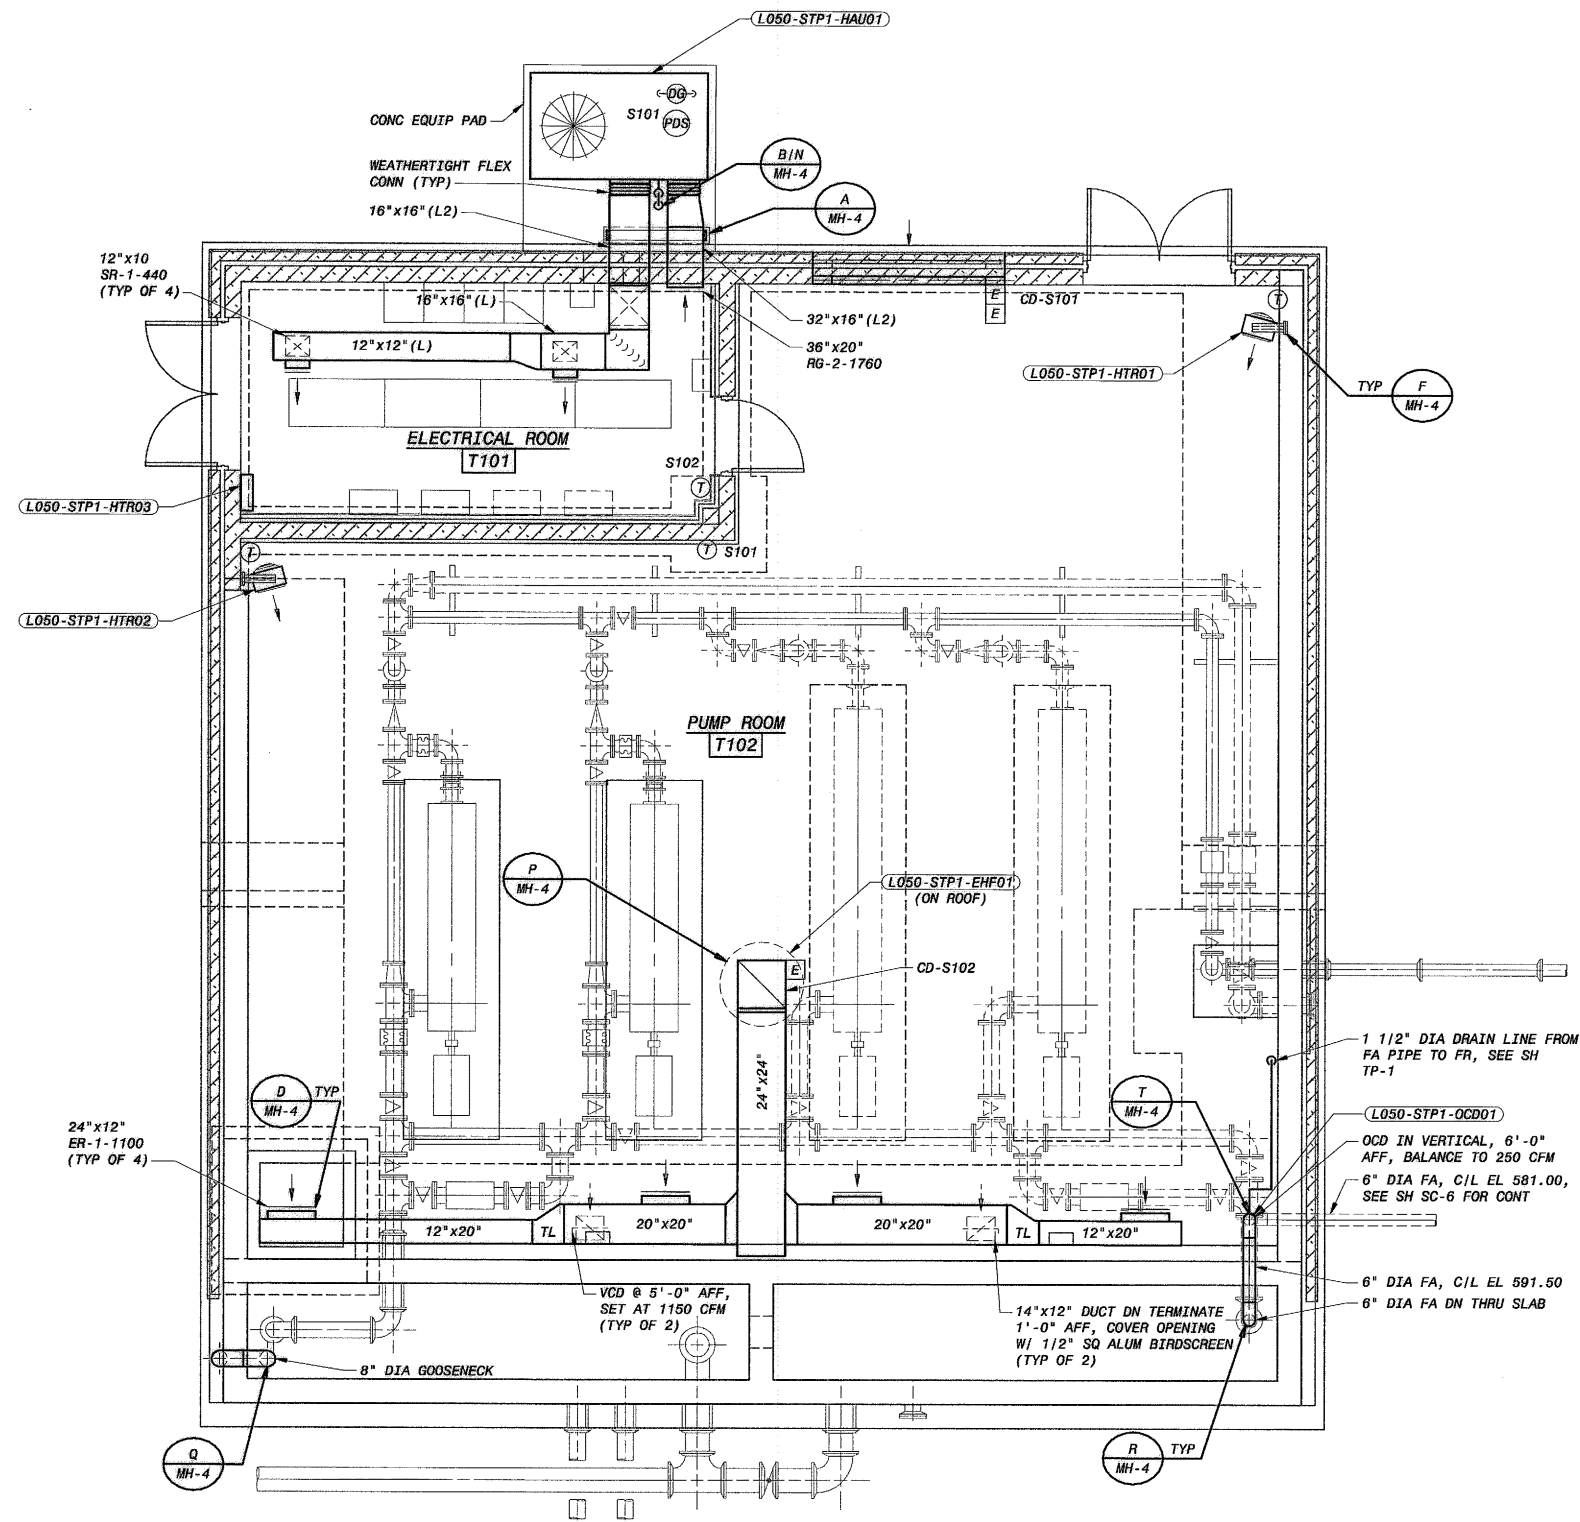


OPERATING FLOOR PLAN
1/4" = 1'-0"

LOWER BIRD CREEK WWTP EXPANSION
TMUA PROJECT NO. ES 2006-01
CONTRACT 1B
SLUDGE TRANSFER PUMP STATION
HVAC
OPERATING FLOOR PLAN
CITY OF TULSA, OKLAHOMA
TULSA METROPOLITAN UTILITY AUTHORITY
ENGINEERING SERVICES DEPARTMENT

PLANS AND ESTIMATES PREPARED BY:
BLACK & VEATCH
Building a world of difference
Black & Veatch Corporation
Kansas City, Missouri
Holloway, Upfine and Solen
Consulting Engineers
Muskogee - Broken Arrow
OKGATES
Engineering Services



REVISION	BY	DATE	PLAN SCALE:	DRAWN	AEC	APPROVED:
			1/4" = 1'-0"	DESIGNED	AEC	
				SURVEY		
			PROFILE SCALE:	FIELD MGR.	708 10/11	
			HORIZONTAL:	SECT. MGR.	231 10/3/11	
			1" =	PROJ. MGR.		
			VERTICAL	RECOMMENDED:	HAS 10/3/11	
			1" =			
			FILE: TH-01.DWG	DRAWING: TH-1	DATE 10/26/2011	
			ATLAS PAGE NO:		SHEET 200 OF 261 SHEETS	

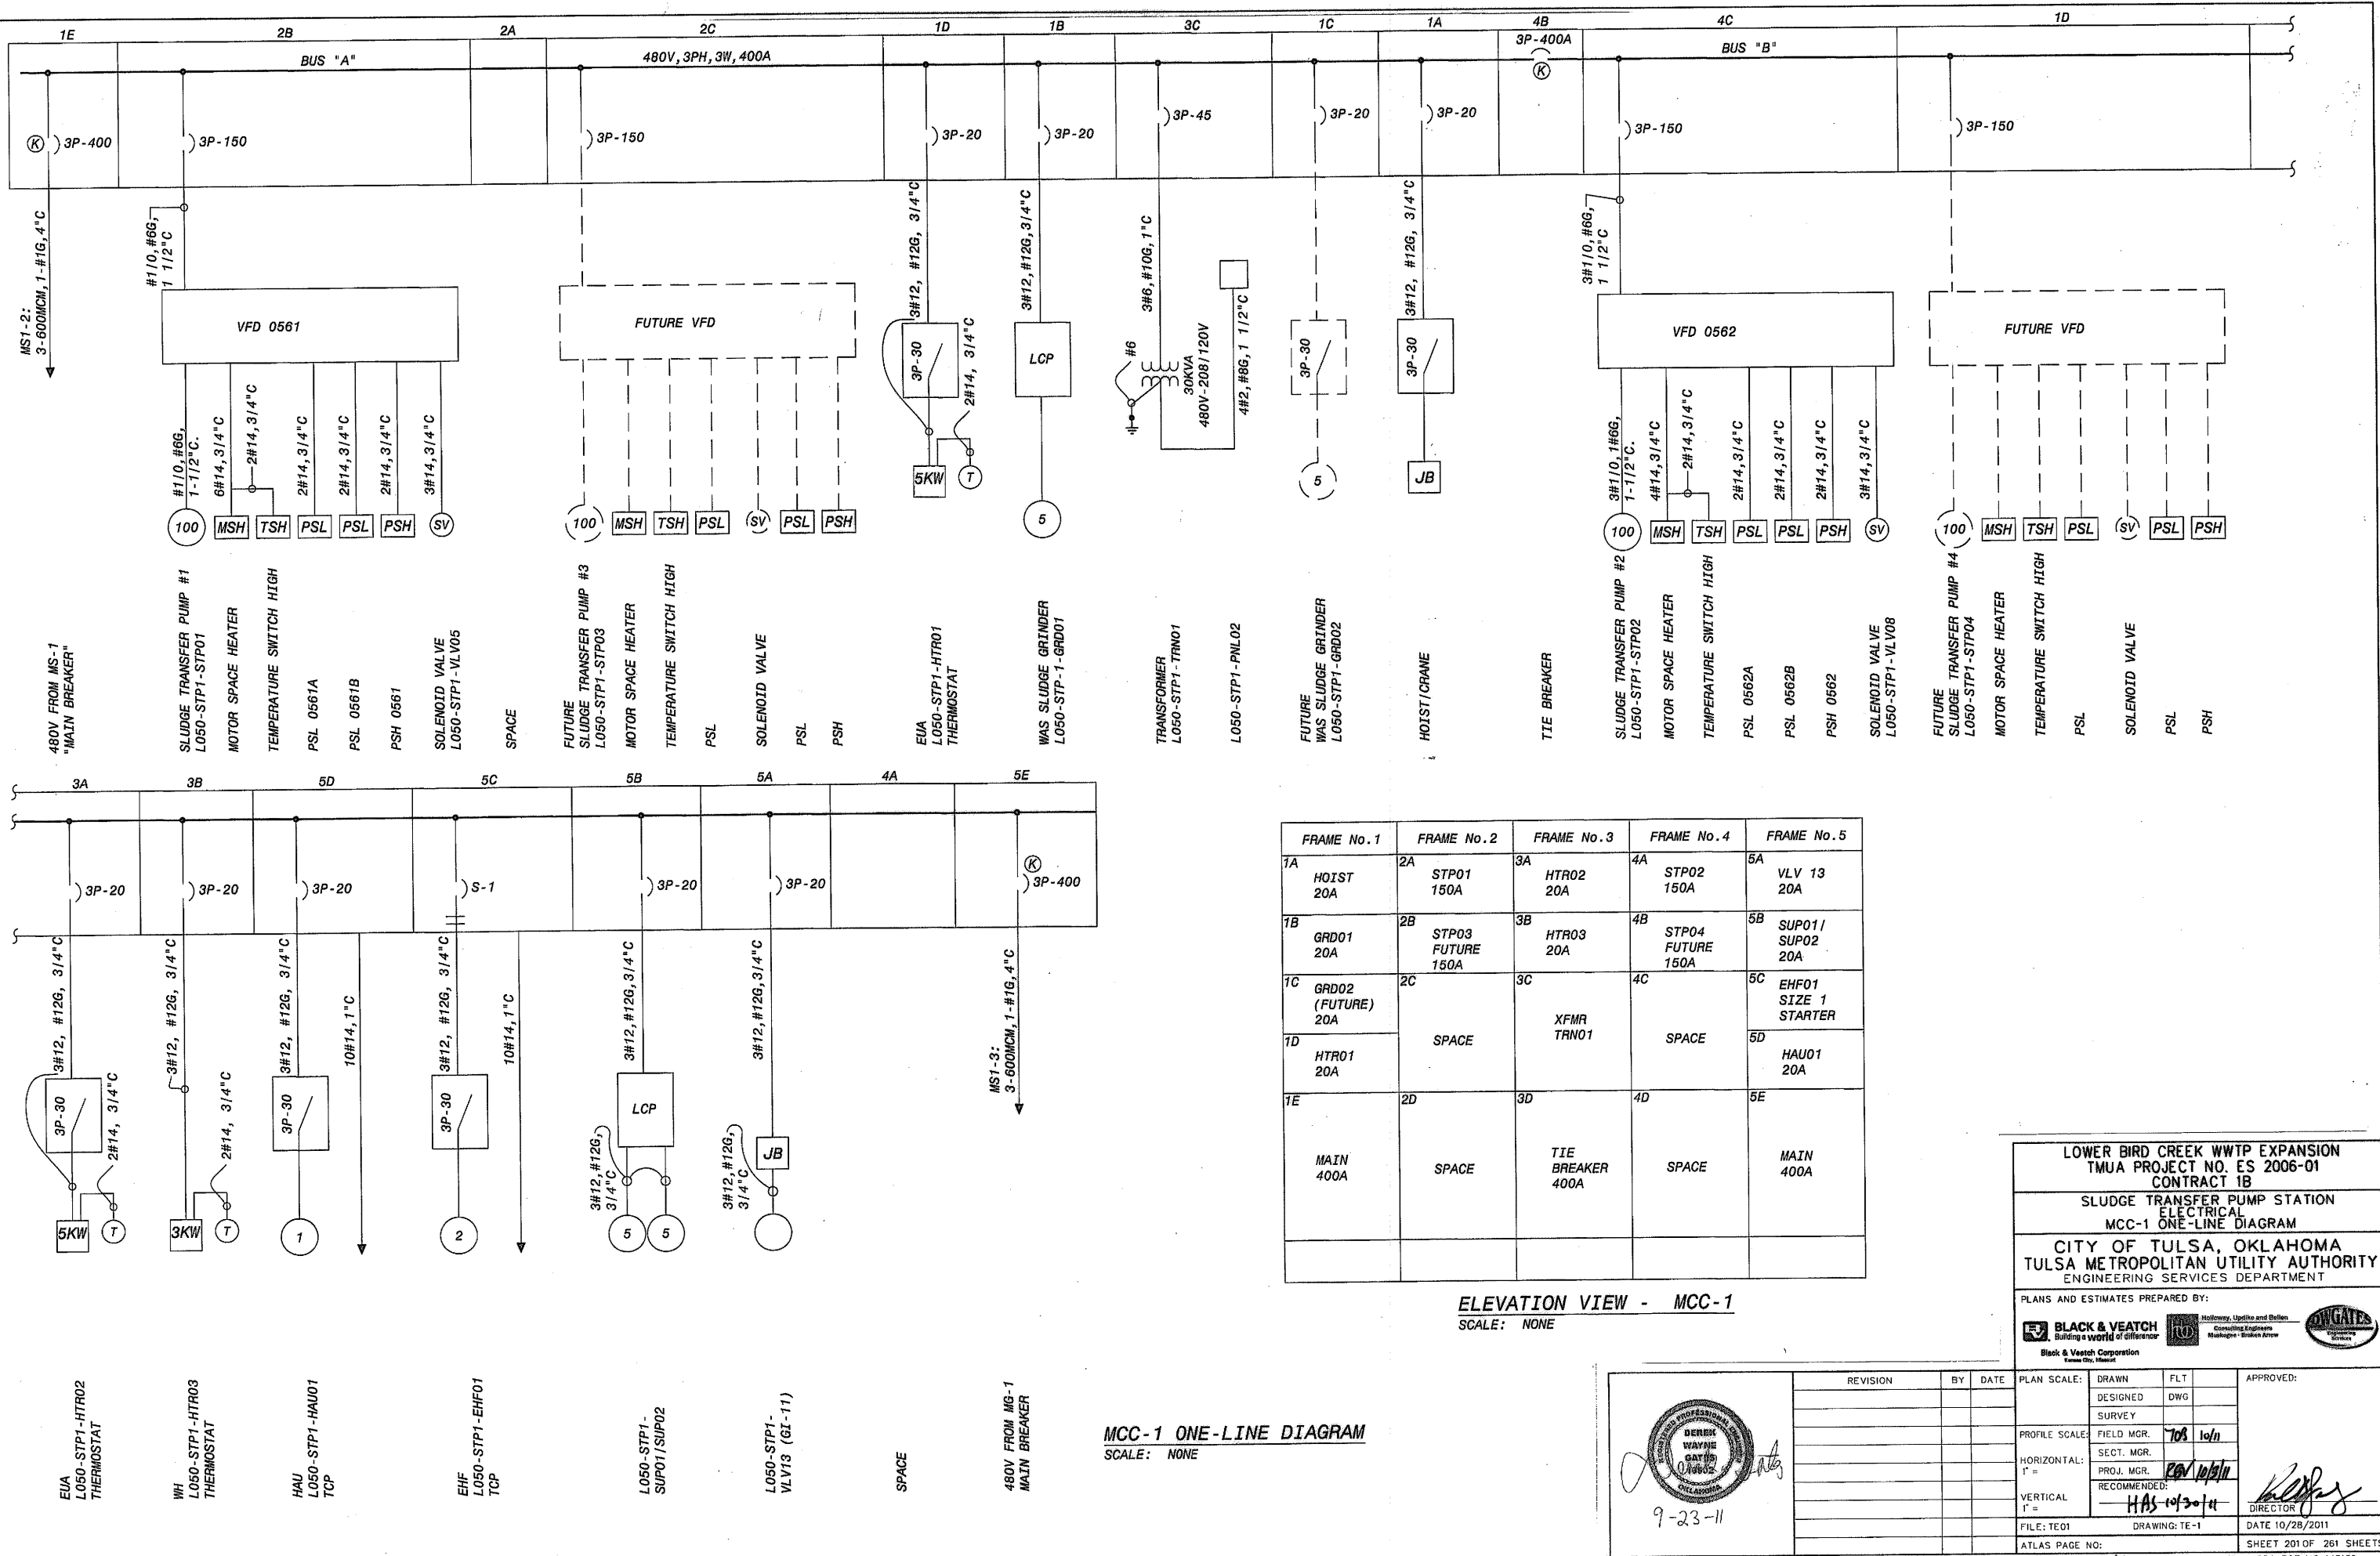


FRAME No. 1	FRAME No. 2	FRAME No. 3	FRAME No. 4	FRAME No. 5
1A HOIST 20A	2A STP01 150A	3A HTR02 20A	4A STP02 150A	5A VLV 13 20A
1B GRD01 20A	2B STP03 FUTURE 150A	3B HTR03 20A	4B STP04 FUTURE 150A	5B SUP01/ SUP02 20A
1C GRD02 (FUTURE) 20A	2C SPACE	3C XFMR TRN01	4C SPACE	5C EHF01 SIZE 1 STARTER
1D HTR01 20A	2D SPACE	3D TIE BREAKER 400A	4D SPACE	5D HAU01 20A
1E MAIN 400A	2E SPACE	3E SPACE	4E SPACE	5E MAIN 400A

ELEVATION VIEW - MCC-1
 SCALE: NONE

MCC-1 ONE-LINE DIAGRAM
 SCALE: NONE

LOWER BIRD CREEK WWTP EXPANSION
 TMAA PROJECT NO. ES 2006-01
 CONTRACT 1B
 SLUDGE TRANSFER PUMP STATION
 ELECTRICAL
 MCC-1 ONE-LINE DIAGRAM
 CITY OF TULSA, OKLAHOMA
 TULSA METROPOLITAN UTILITY AUTHORITY
 ENGINEERING SERVICES DEPARTMENT

PLANS AND ESTIMATES PREPARED BY:
 BLACK & VEATCH
 Building a world of difference
 Holloway, Updegraff and Bell
 Consulting Engineers
 Redwood - Broken Arrow
 Black & Veatch Corporation
 Tulsa, Oklahoma

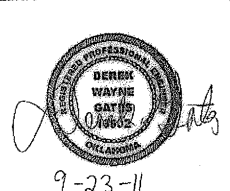

REVISION	BY	DATE	PLAN SCALE:	DRAWN	FLT	APPROVED:
				DESIGNED	DWG	
				SURVEY		
			PROFILE SCALE:	FIELD MGR.	708 10/11	
			HORIZONTAL:	PROJ. MGR.	10/11/11	
			VERTICAL:	RECOMMENDED:	HAS 10/30/11	
			FILE: TE01	DRAWING: TE-1		
			ATLAS PAGE NO:			

